

CONSULTANTS:

- CIVIL ENGINEER:  
MCCLELLAND ENGINEERS
- LANDSCAPE ARCHITECT:  
LARSON BURNS SMITH
- STRUCTURAL ENGINEER:  
CROMWELL ENGINEERS INC.
- MECH., ELEC., PLUMB. ENG  
CROMWELL ENGINEERS INC.
- GLOBAL VILLAGE CONSULTING  
CAMBRIDGE SEVEN ASSOCIATES
- INTERIOR DESIGNER:  
POLK STANLEY ROWLAND  
CURZON PORTER ARCHITECTS
- GENERAL CONTRACTOR:  
CDI CONTRACTORS, INC.

NOTES:


ISSUE DATE:  
17 SEPTEMBER 2008

REVISIONS:

#	DATE	DESCRIPTION
1	09/27/07	ADDENDUM 01
2	01/28/08	CITY OF LR
3	06/19/08	ASI #16

MURPHY - KELLER  
EDUCATIONAL CENTER



HEIFER  
INTERNATIONAL  
CENTER

LITTLE ROCK, ARKANSAS

PSRCP JOB NUMBER:  
431E

CONTENTS:  
MECHANICAL  
FLOOR PLAN

SHEET NUMBER:  
M101

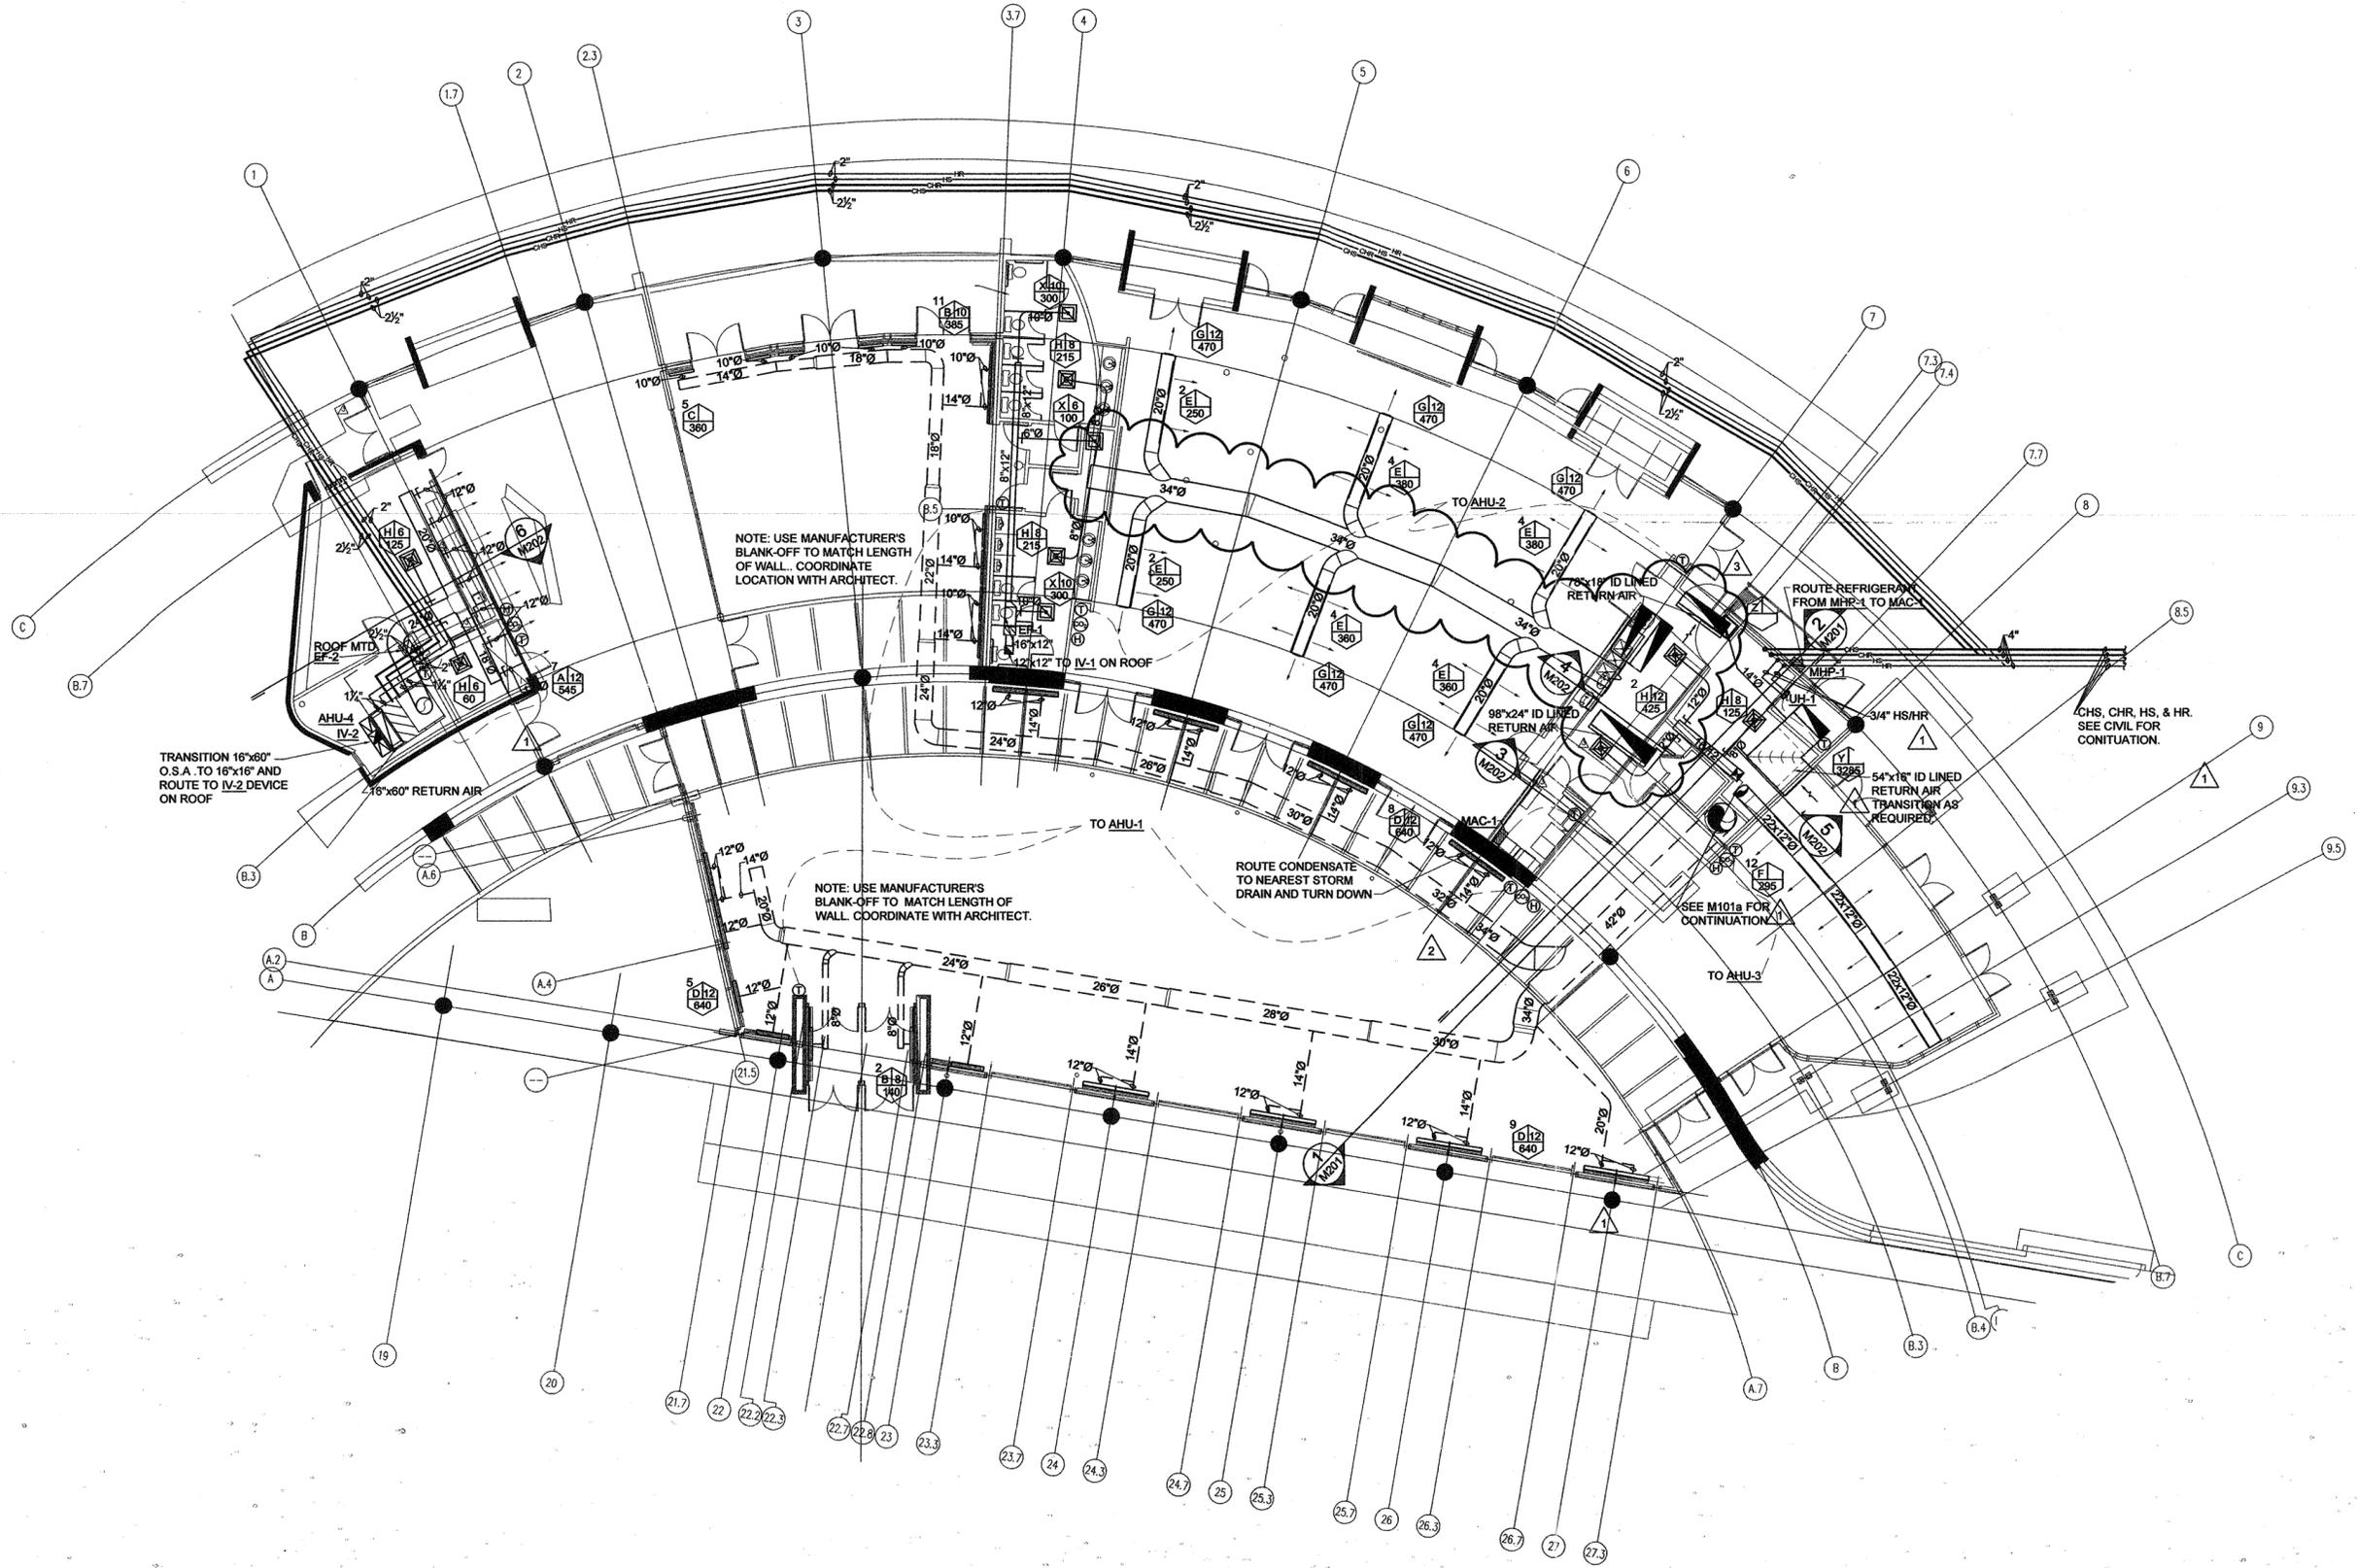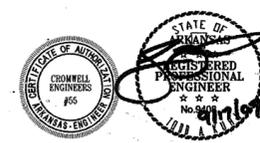

FIRST FLOOR MECHANICAL FLOOR PLAN  
SCALE: 1/8"=1'-0"