

- CONSULTANTS:
- CIVIL ENGINEER:
MCLELLAND ENGINEERS
 - LANDSCAPE ARCHITECT:
LARSON BURNS SMITH
 - STRUCTURAL ENGINEER:
CROMWELL ENGINEERS INC
 - MECH., ELEC., PLUMB. EN
CROMWELL ENGINEERS INC
 - GLOBAL VILLAGE CONSULT.
CAMBRIDGE SEVEN ASSOCI
 - INTERIOR DESIGNER:
POLK STANLEY ROWLAND
CURZON PORTER ARCHITECTS
 - GENERAL CONTRACTOR:
CDI CONTRACTORS, INC.

NOTES:

ISSUE DATE:
17 SEPTEMBER 2

REVISIONS:

#	DATE	DESCRIPTION
1	09/27/07	ADDENDUM 01
2	06/19/08	ASI #16

**MURPHY - KELLEI
EDUCATIONAL CENTER**


**HEIFER
INTERNATIONAL
CENTER**

LITTLE ROCK, ARKANSAS


PSRCP JOB NUMBER:
431E
CONTENTS:

MECHANICAL MEZZAI
FLOOR PLAN
SHEET NUMBER:

M101a

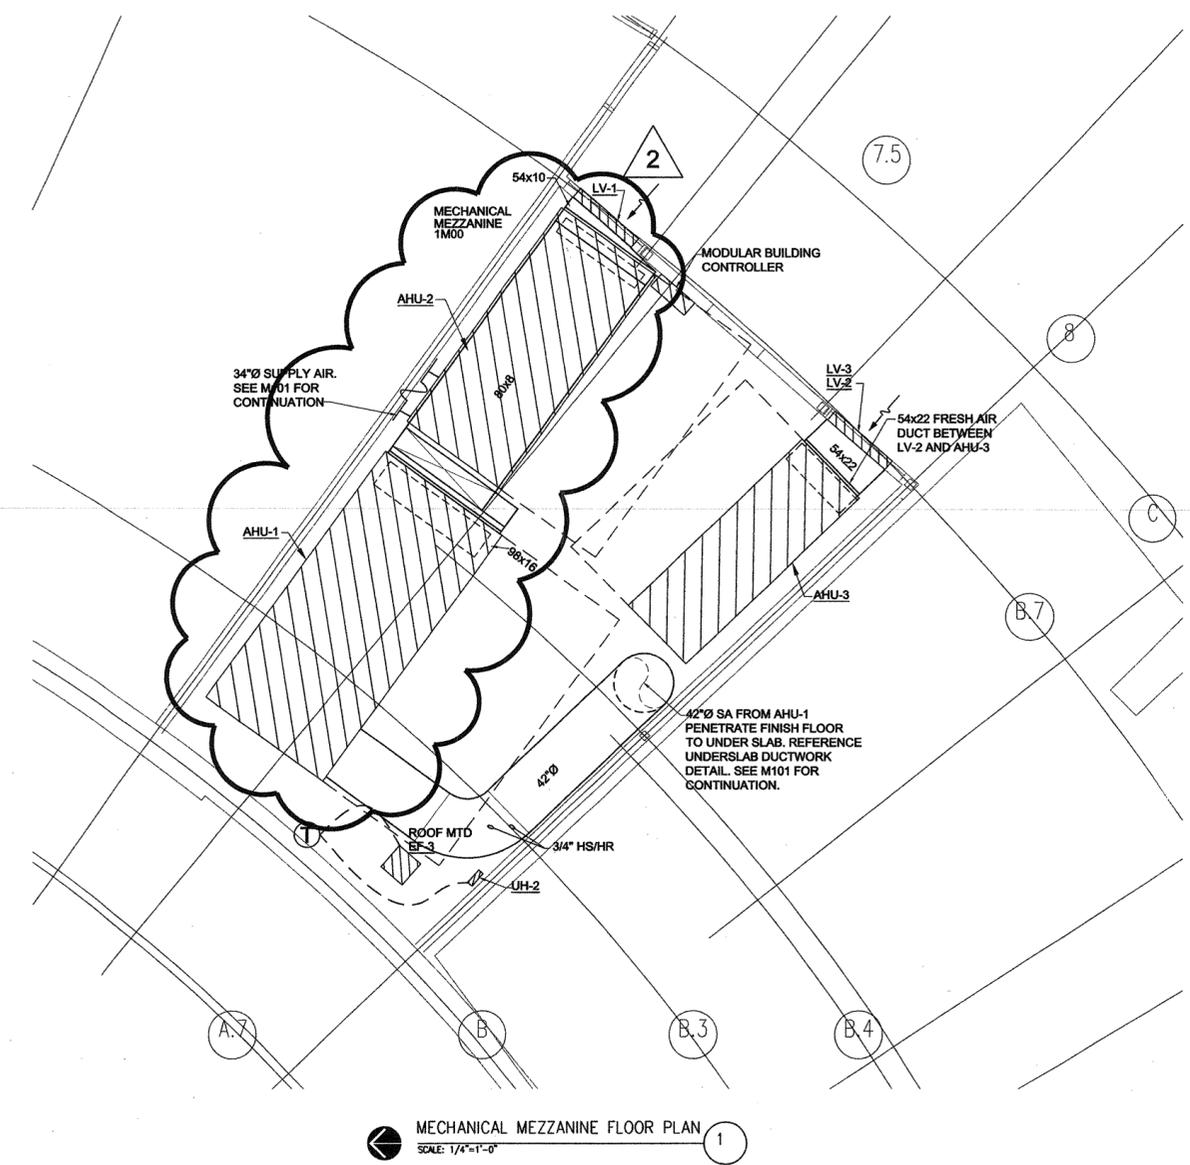

MECHANICAL MEZZANINE FLOOR PLAN
SCALE: 1/4"=1'-0" 1

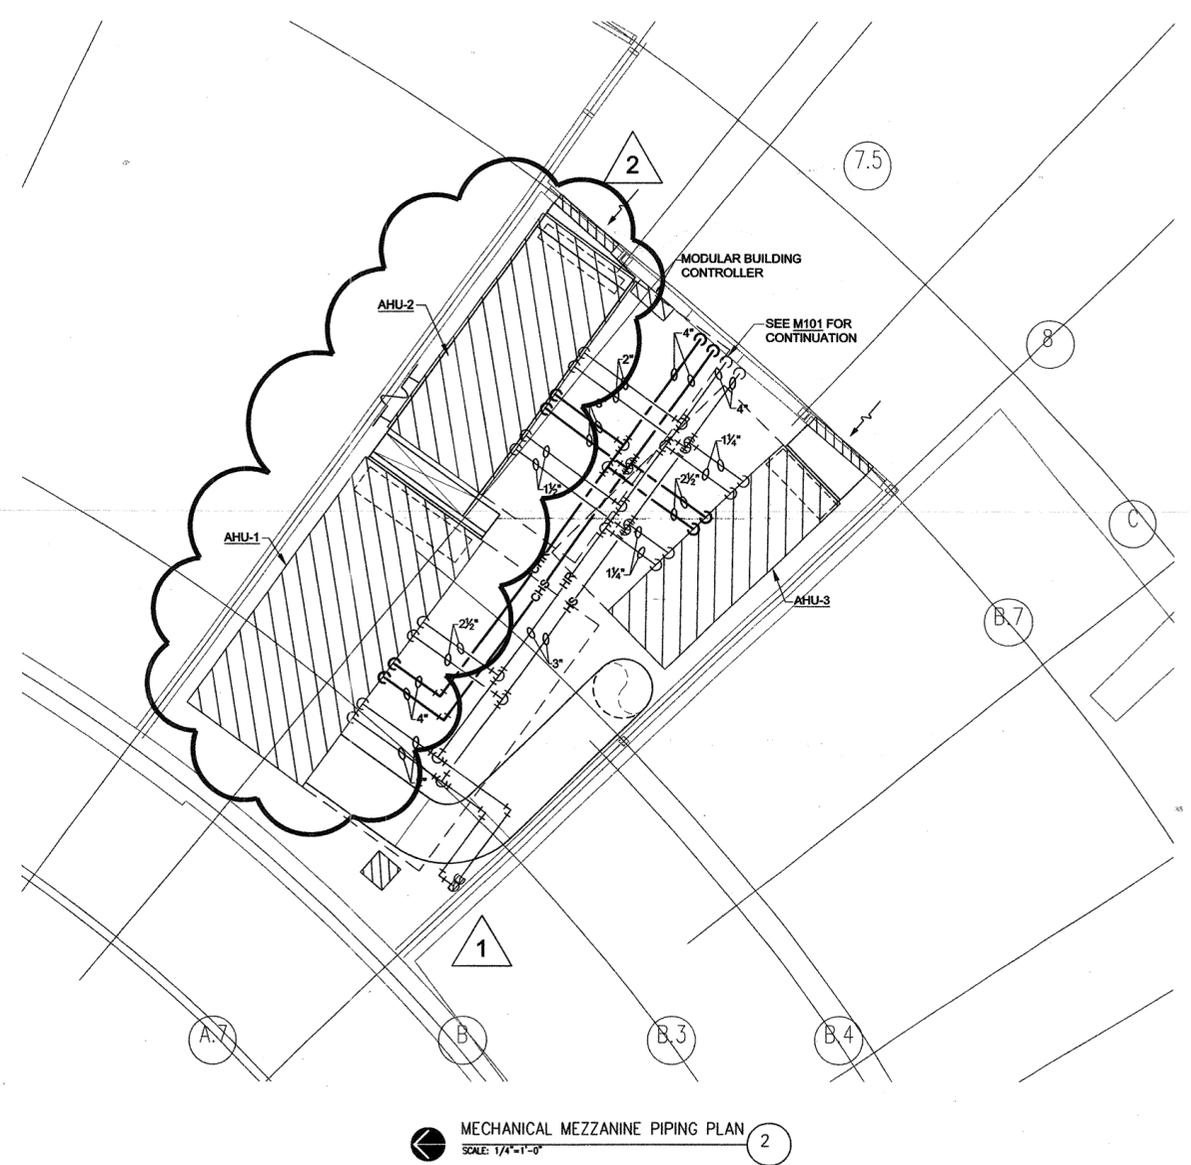

MECHANICAL MEZZANINE PIPING PLAN
SCALE: 1/4"=1'-0" 2

