

CONSULTANTS:

CIVIL ENGINEER:
MCLELLAND ENGINEERS

LANDSCAPE ARCHITECT:
LARSON BURNS SMITH

STRUCTURAL ENGINEER:
CROMWELL ENGINEERS INC.

MECH., ELEC., PLUMB. ENGINEER:
CROMWELL ENGINEERS INC.

GLOBAL VILLAGE CONSULTANT:
CAMBRIDGE SEVEN ASSOCIATES

INTERIOR DESIGNER:
POLK STANLEY ROWLAND
CURZON PORTER ARCHITECTS

GENERAL CONTRACTOR:
CDI CONTRACTORS, INC.

NOTES:

ISSUE DATE:

17 SEPTEMBER 2007

REVISIONS:

#	DATE	DESCRIPTION

Revision
#4 3/4/08
AS1 #06
loose in file
drawer

**INTERNATIONAL
CENTER**

LITTLE ROCK, ARKANSAS

PSRCP JOB NUMBER:


431E

CONTENTS:

MECHANICAL DETAILS

SHEET NUMBER:

M102

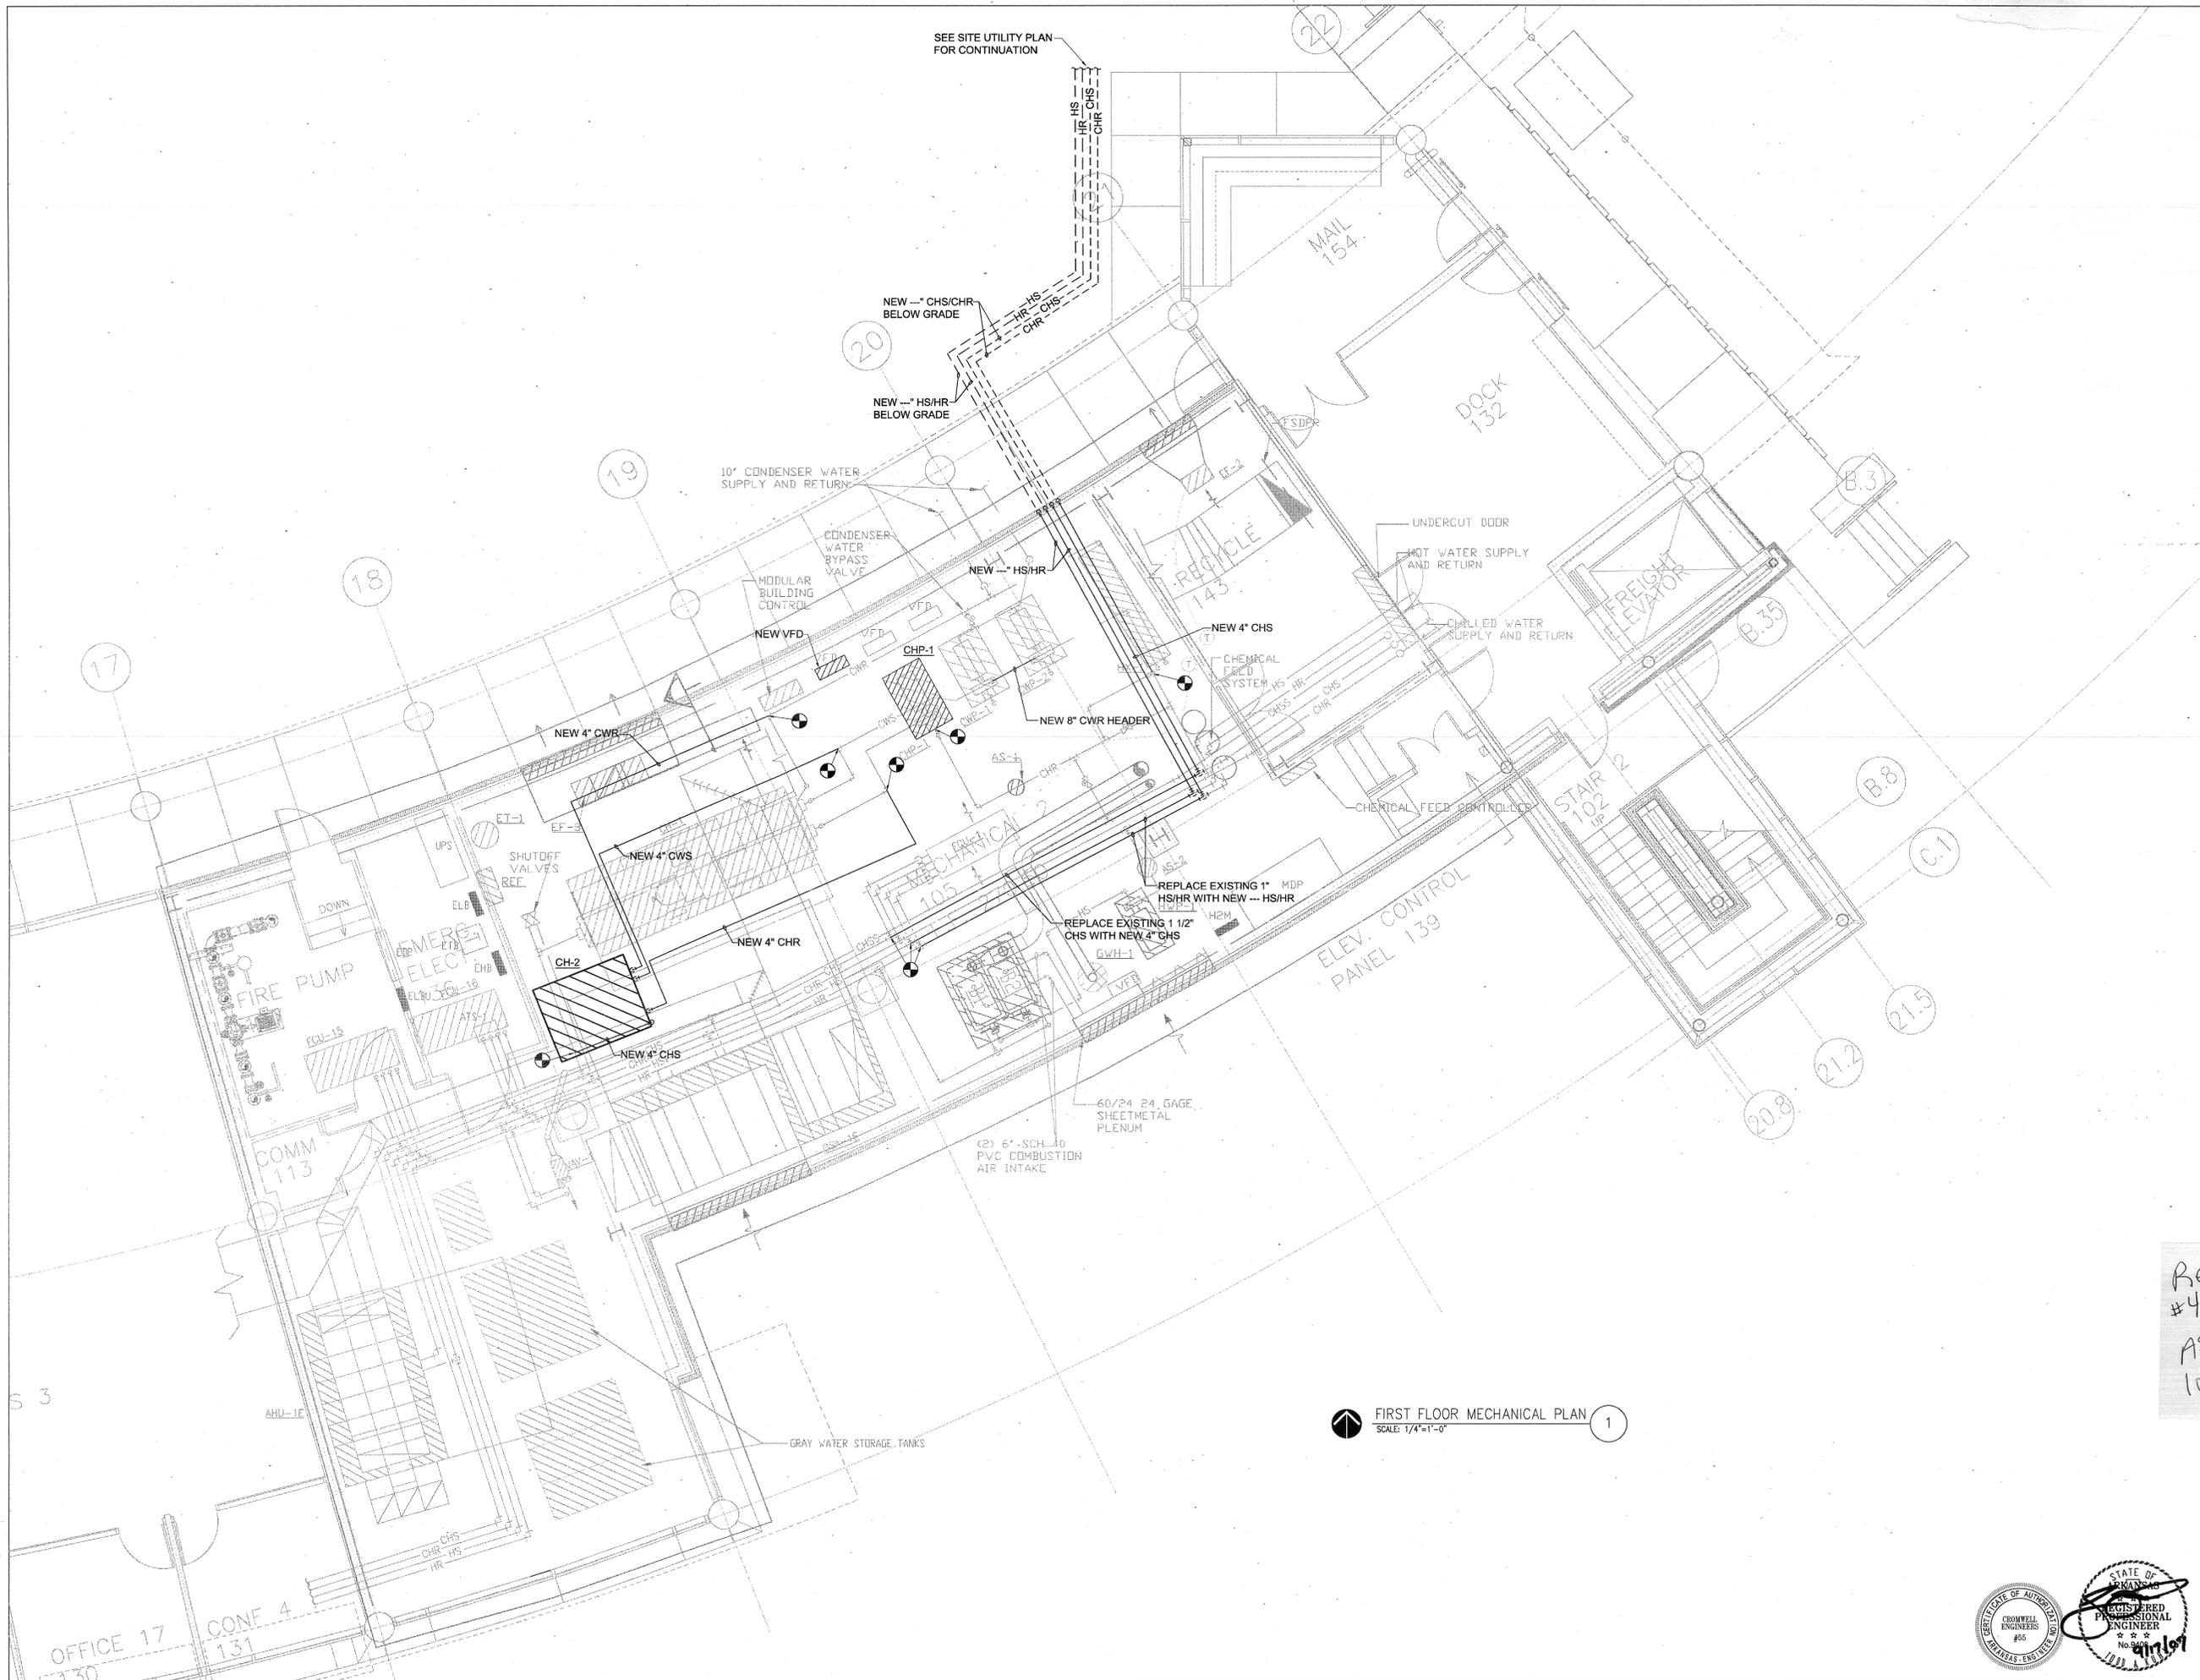

FIRST FLOOR MECHANICAL PLAN
SCALE: 1/4"=1'-0" 1

