

CONSULTANTS:

CIVIL ENGINEER:
MCLELLAND ENGINEERS

LANDSCAPE ARCHITECT:
LARSON BURNS SMITH

STRUCTURAL ENGINEER:
CROMWELL ENGINEERS INC.

MECH., ELEC., PLUMB. ENGINEER:
CROMWELL ENGINEERS INC.

GLOBAL VILLAGE CONSULTANT
CAMBRIDGE SEVEN ASSOCIATES

INTERIOR DESIGNER:
POLK STANLEY ROWLAND
CURZON PORTER ARCHITECTS

GENERAL CONTRACTOR:
CDI CONTRACTORS, INC.

NOTES:

ISSUE DATE:

17 SEPTEMBER 2007

REVISIONS:

#	DATE	DESCRIPTION

MURPHY - KELLER
EDUCATIONAL CENTER

HEIFER
INTERNATIONAL
CENTER

LITTLE ROCK, ARKANSAS

PSRCP JOB NUMBER:


431E

CONTENTS:

MECHANICAL DETAILS


SHEET NUMBER:

M201

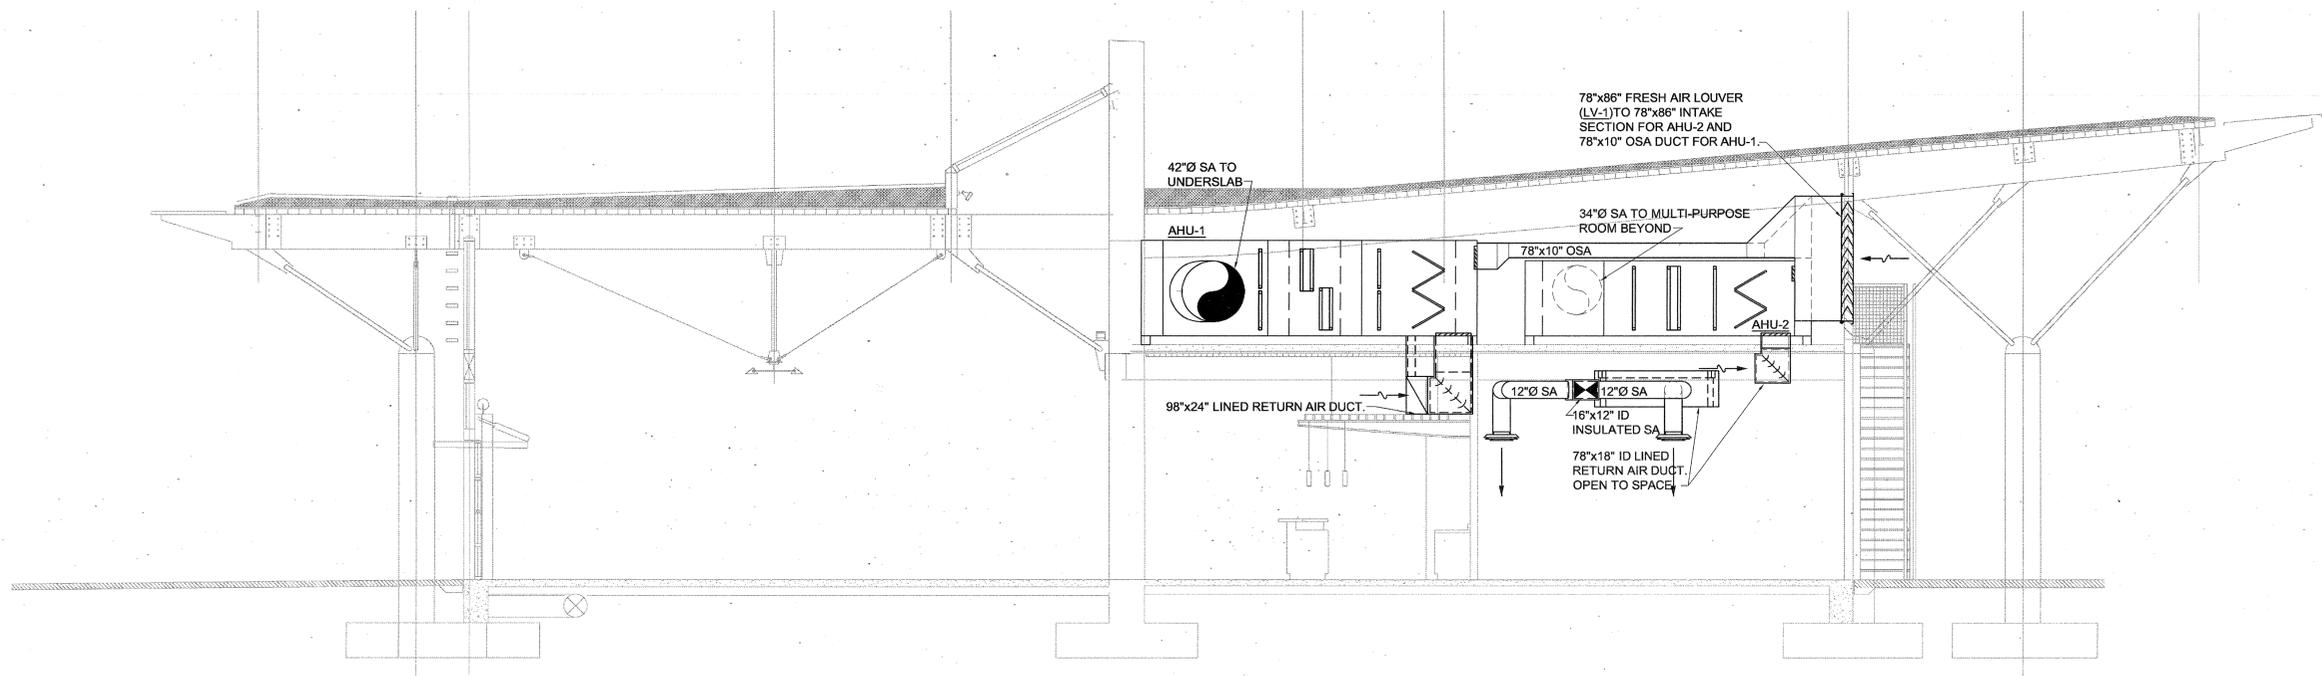

MECHANICAL SECTION THRU MEZZANINE 2

SCALE: 1/4"=1'-0"

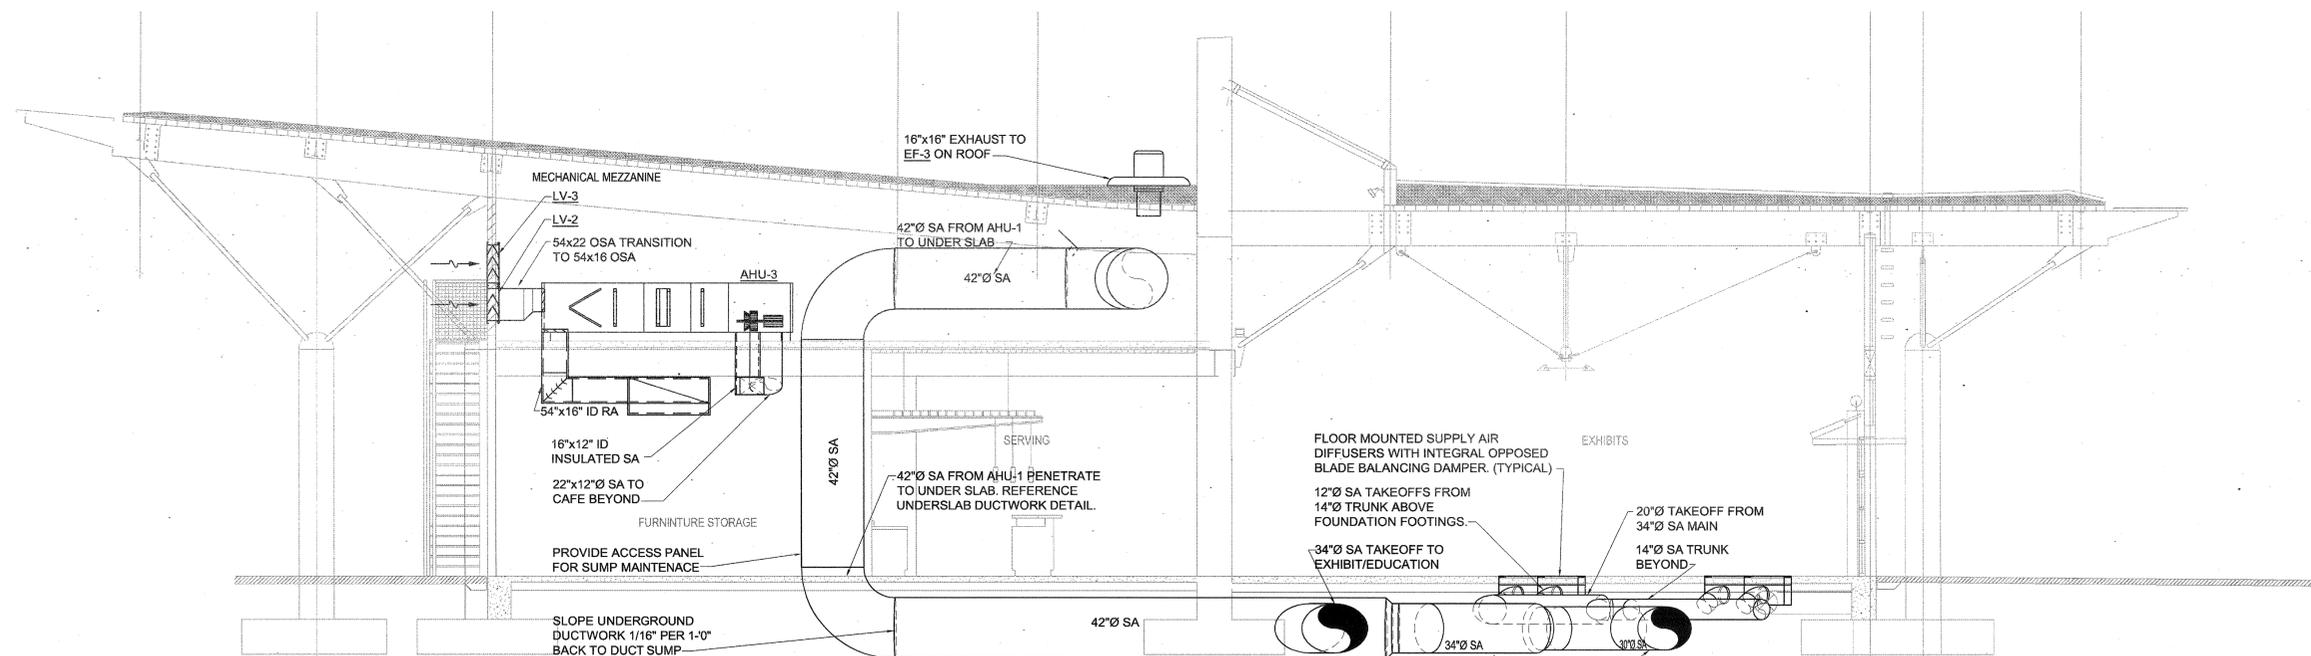

MECHANICAL SECTION THRU MEZZANINE 1

SCALE: 1/4"=1'-0"

NOTE: ELEVATION MAY BE EXAGGERATED. COORDINATE LOCATION OF UNDERGROUND DUCTWORK WITH STRUCTURAL. LOCATE 14"Ø TRUNKS, TAKEOFFS, AND SUPPLY DIFFUSERS ABOVE FOUNDATION FOOTINGS.

