

CONSULTANTS:

CIVIL ENGINEER:
MCCLELLAND ENGINEERS

LANDSCAPE ARCHITECT:
LARSON BURNS SMITH

STRUCTURAL ENGINEER:
CROMWELL ENGINEERS INC.

MECH., ELEC., PLUMB. ENGINEER:
CROMWELL ENGINEERS INC.

GLOBAL VILLAGE CONSULTANT
CAMBRIDGE SEVEN ASSOCIATES

INTERIOR DESIGNER:
POLK STANLEY ROWLAND
CURZON PORTER ARCHITECTS

GENERAL CONTRACTOR:
CDI CONTRACTORS, INC.

NOTES:

ISSUE DATE:
17 SEPTEMBER 2007

REVISIONS:

#	DATE	DESCRIPTION
1	09/27/07	ADDENDUM 01
2	06/19/08	ASI #16
3	02/27/09	ASI #37

MURPHY - KELLER
EDUCATIONAL CENTER

HEIFER
INTERNATIONAL
CENTER



LITTLE ROCK, ARKANSAS

PSRCP JOB NUMBER:
431E

CONTENTS:
MECHANICAL DETAILS

SHEET NUMBER:

M201

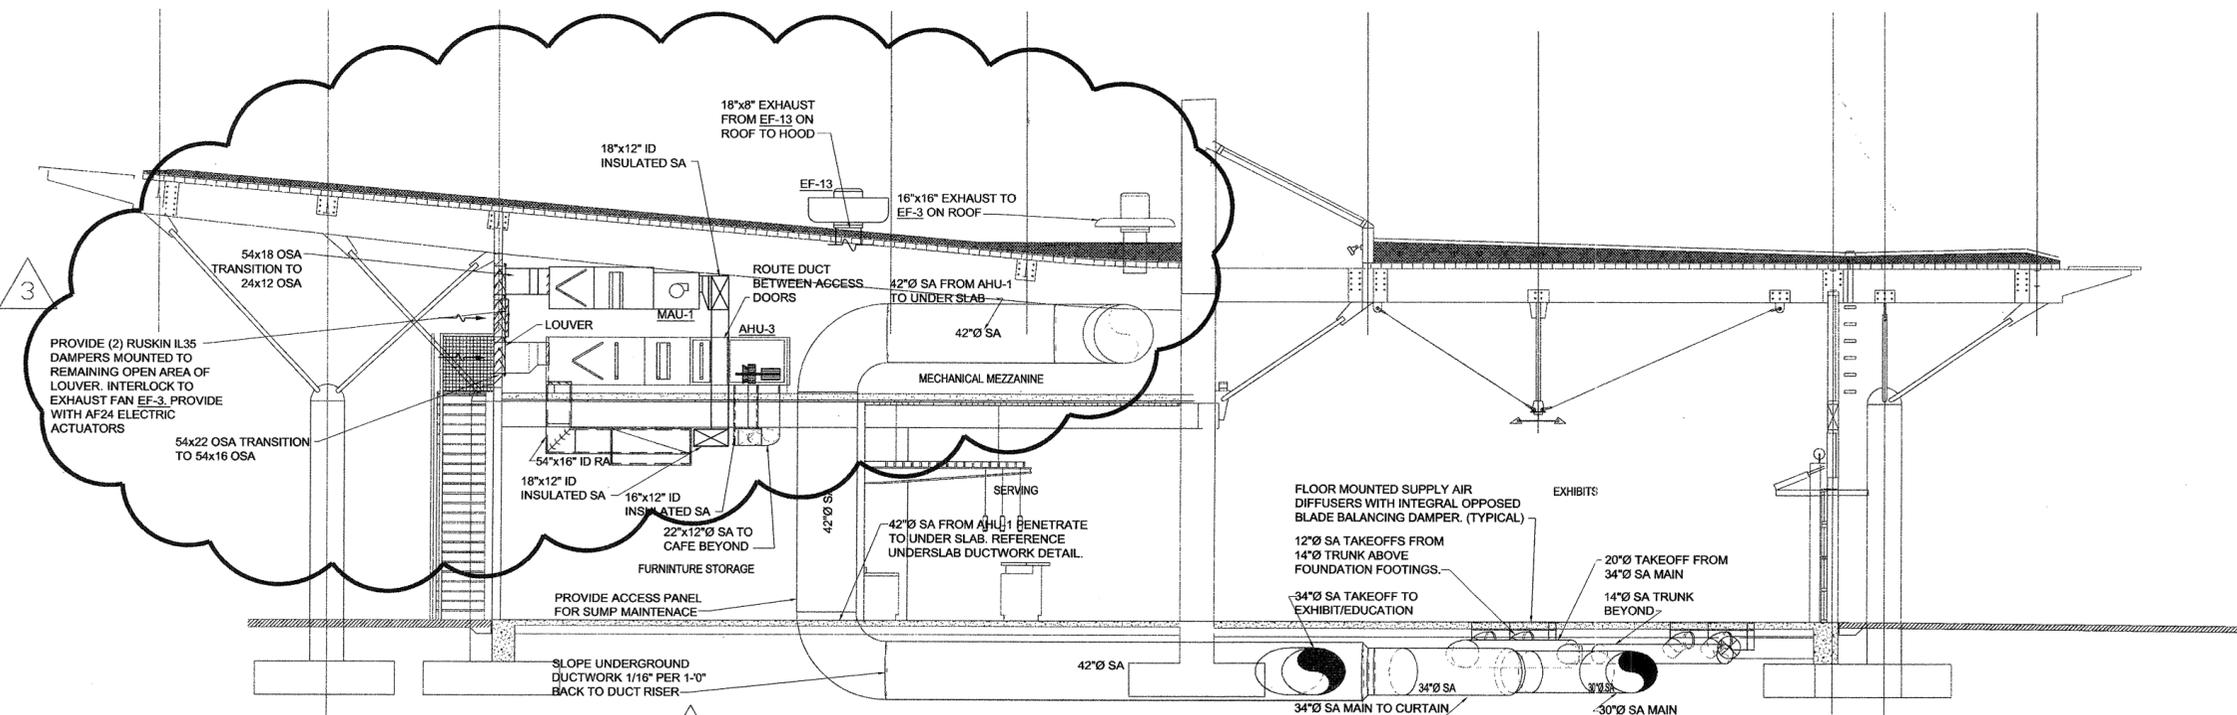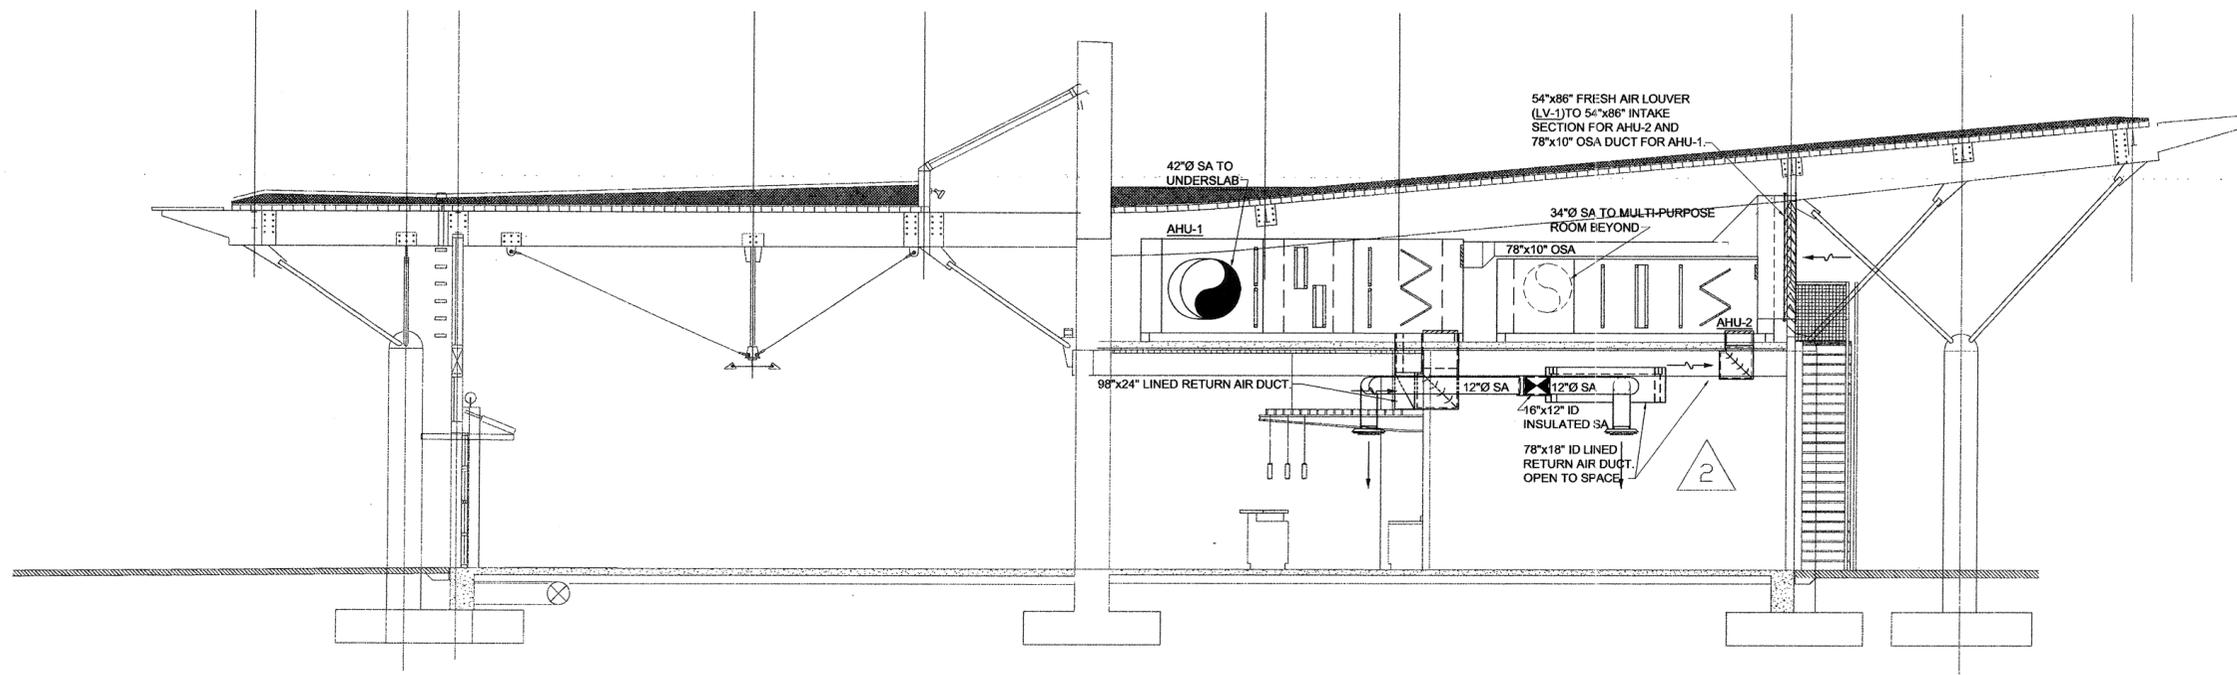

NOTE: ELEVATION MAY BE EXAGGERATED. COORDINATE LOCATION OF UNDERGROUND DUCTWORK WITH STRUCTURAL. LOCATE 14"Ø TRUNKS, TAKEOFFS, AND SUPPLY DIFFUSERS ABOVE FOUNDATION FOOTINGS.

