


GENERAL NOTES:

1. PROVIDE TRAP PRIMER GUARD INSERTS FOR FLOOR DRAINS IN TOILETS, MECHANICAL ROOMS AND KITCHEN AREA.
2. ALL DOMESTIC WATER PIPING SHALL BE INSULATED.
3. PROVIDE INSULATION FOR ALL HORIZONTAL AND VERTICAL STORM PIPING ABOVE GRADE INSIDE THE BUILDING.
4. RUN ALL GAS PIPING IN VENTILATED AREA OR CEILING SPACE.

KEYED NOTES:

- ① 6" STORM DRAIN (SD) DOWN BELOW FLOOR.
- ② 1" COLD & HOT WATER DOWN TO AND FROM ELECTRIC WATER HEATER (EWH-2).
- ③ 1/2" COLD & HOT WATER DOWN IN WALL TO SERVE JANITOR SINK (P-4).
- ④ 6" SD AND 3" FLUE AND UP TO MEZZANINE, SEE PLAN 1/P501. 8" SD DS DOWN BELOW FLOOR.
- ⑤ EWH-1, (40 GALLON WATER HEATER) MOUNTED ON FLOOR WITH 1" CW & HW AND 1/2" GAS CONNECTIONS, SEE DETAIL 7/P501.
- ⑥ 3" VENT UP TO MEZZANINE, SEE PLAN 1/P-501.
- ⑦ 6" DOWNSPOUT NOZZLE (EQUAL TO MIFAB #R1946-3 CAST STAINLESS STEEL, TYPE 304 NOZZLE) SEE ARCH. PLANS FOR ELEVATION.
- ⑧ 6" ASD UP TO MEZZANINE, SEE PLAN 1/P501.
- ⑨ 2" DOWNSPOUT NOZZLE (EQUAL TO MIFAB #R1942-3 CAST STAINLESS STEEL, TYPE 304 NOZZLE) SEE ARCH. PLANS FOR ELEVATION.
- ⑩ 1" GAS MOUNTED AT STRUCTURE, CAPPED FOR FUTURE.
- ⑪ 3/4" CW DOWN WITH TWO-WAY VALVE TO SERVE SINK & ICE MACHINE 3/4" HW DOWN WITH TWO-WAY VALVE TO SERVE SINK & DISHWASHER.
- ⑫ 3/4" CW & HW DOWN TO LAVATORIES (P-3) (TYPICAL OF 3).

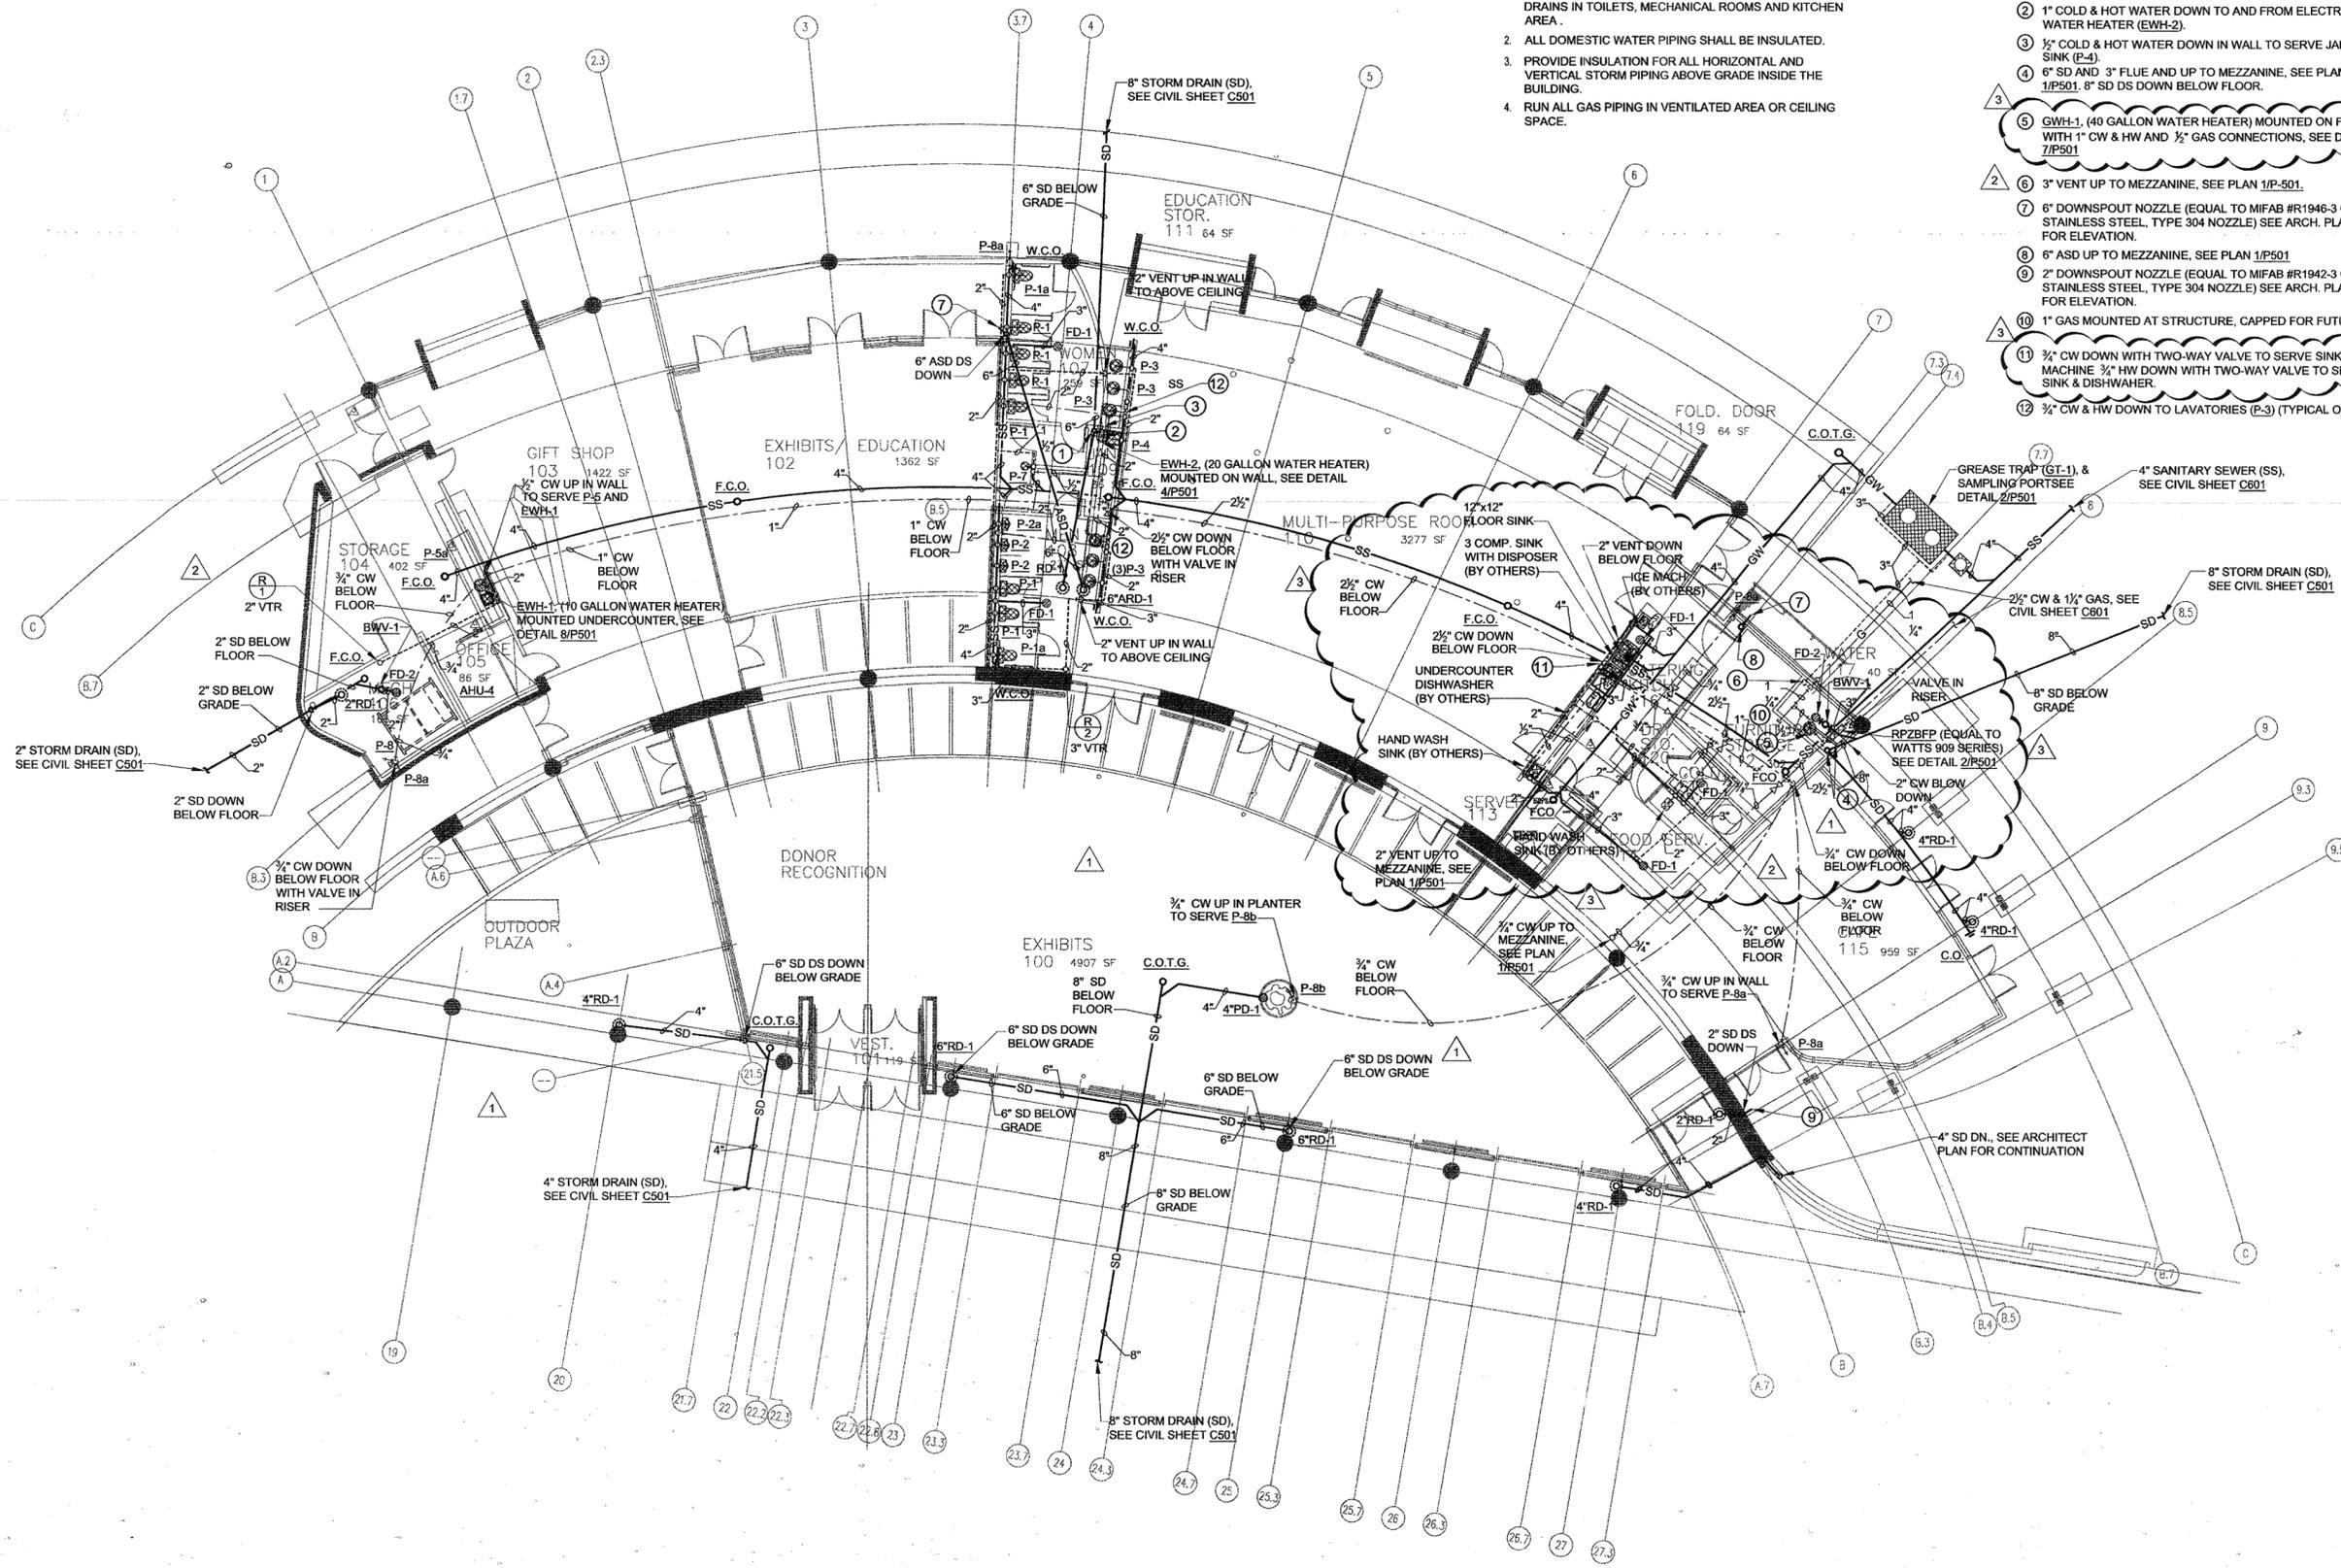

POLK STANLEY ROWLAND CURZON PORTER ARCHITECTS, LTD.

700 SOUTH SCHILLER
LITTLE ROCK, AR 72201
501.378.0878 office
501.372.7629 fax
509 W. SPRING STREET,
SUITE 150
FAYETTEVILLE, AR 72701
479.444.0473 office
473.251.7216 fax
www.polkstanley.com

CONSULTANTS:
CIVIL ENGINEER:
MCCLELLAND ENGINEERS
LANDSCAPE ARCHITECT:
LARSON BURNS SMITH
STRUCTURAL ENGINEER:
CROMWELL ENGINEERS INC.
MECH., ELEC., PLUMB. ENGINEER:
CROMWELL ENGINEERS INC.
GLOBAL VILLAGE CONSULTANT
CAMBRIDGE SEVEN ASSOCIATES
INTERIOR DESIGNER:
POLK STANLEY ROWLAND
CURZON PORTER ARCHITECTS
GENERAL CONTRACTOR:
CDI CONTRACTORS, INC.

NOTES:

ISSUE DATE:
17 SEPTEMBER 2007

REVISIONS:

#	DATE	DESCRIPTION
1	01/07/08	ASI #1
2	02/06/08	ASI #2
3	05/16/08	ASI # 14

MURPHY - KELLER
EDUCATIONAL CENTER

HEIFER
INTERNATIONAL
CENTER

LITTLE ROCK, ARKANSAS

PSRCP JOB NUMBER:
431E

CONTENTS:
PLUMBING PLAN

SHEET NUMBER:
P101

NORTH
PLUMBING PLAN
SCALE: 1/8"=1'-0"



CONSULTANTS:

CIVIL ENGINEER:
MCLELLAND ENGINEERS

LANDSCAPE ARCHITECT:
LARSON BURNS SMITH

STRUCTURAL ENGINEER:
CROMWELL ENGINEERS INC.

MECH., ELEC., PLUMB. ENGINEER:
CROMWELL ENGINEERS INC.

GLOBAL VILLAGE CONSULTANT
CAMBRIDGE SEVEN ASSOCIATES

INTERIOR DESIGNER:
POLK STANLEY ROWLAND
CURZON PORTER ARCHITECTS

GENERAL CONTRACTOR:
CDI CONTRACTORS, INC.

ISSUE DATE:
17 SEPTEMBER 2007

REVISIONS:

DATE: DESCRIPTION:

Δ 02/27/09 ASI #37

Δ

Δ


Δ

Δ


Δ

Δ

GENERAL NOTE:
1. REMOVE EXISTING SITE REGULATOR TO INCHES W.C. AND
INSTALL NEW REGULATOR TO 5 PSI. INSTALL NEW
REGULATOR AT ENTRY TO EXISTING BUILDING FROM 5 PSI TO
INCHES W.C. AT SAME CAPACITY OF EXISTING REGULATOR.
2. HAND SINK AND THREE COMPARTMENT SINK PIPING FROM
MAIN TO FIXTURE MAY ALREADY BE INSTALLED.
CONTRACTOR TO VERIFY PRIOR TO BID.

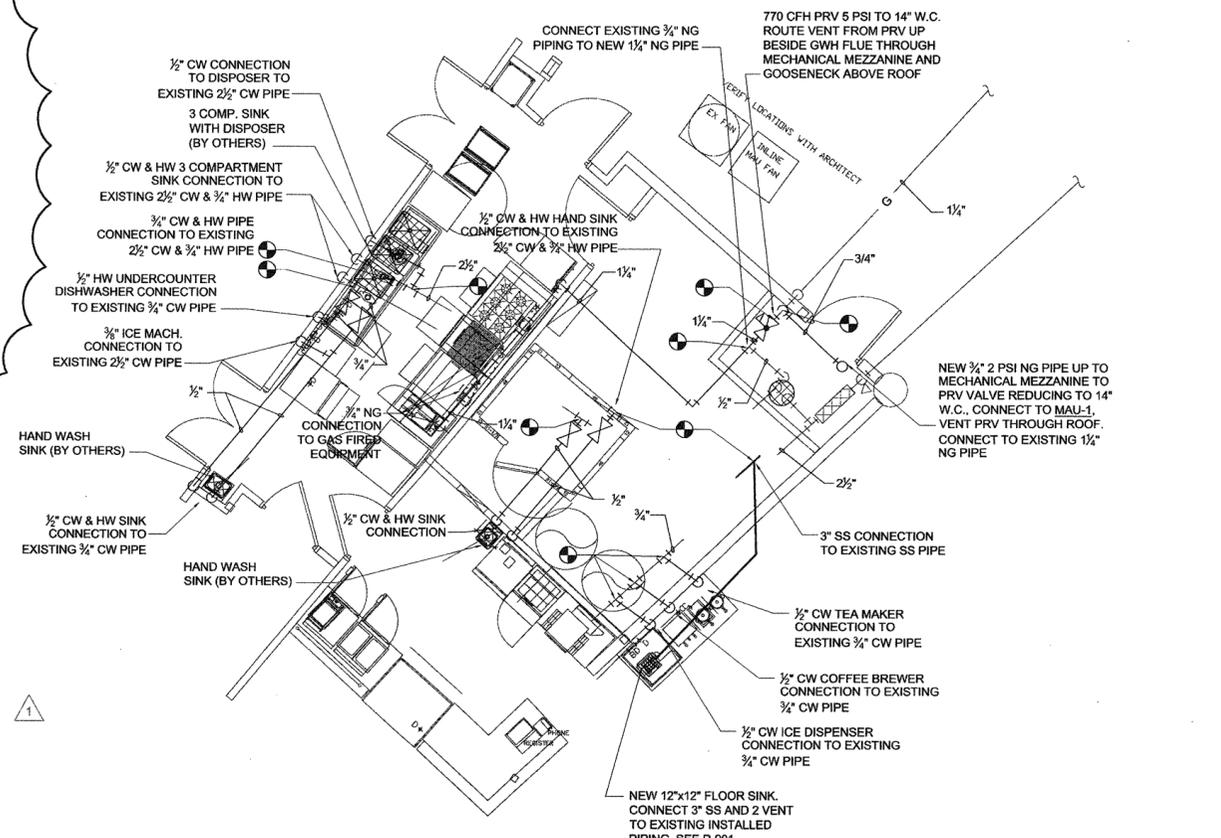

ENLARGED KITCHEN EQUIPMENT PLUMBING FIRST FLOOR PLAN
SCALE: 1/4"=1'-0"

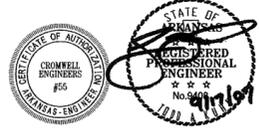

- CONSULTANTS:
- CIVIL ENGINEER:
MCCLELLAND ENGINEERS
 - LANDSCAPE ARCHITECT:
LARSON BURNS SMITH
 - STRUCTURAL ENGINEER:
CROMWELL ENGINEERS INC.
 - MECH., ELEC., PLUMB. ENGINEER:
CROMWELL ENGINEERS INC.
 - GLOBAL VILLAGE CONSULTANT
CAMBRIDGE SEVEN ASSOCIATES
 - INTERIOR DESIGNER:
POLK STANLEY ROWLAND
CURZON PORTER ARCHITECTS
 - GENERAL CONTRACTOR:
CDI CONTRACTORS, INC.

NOTES:

ISSUE DATE:
17 SEPTEMBER 2007

REVISIONS:

#	DATE	DESCRIPTION
1	02/06/08	ASI # 2
2	05/16/08	ASI # 14

MURPHY - KELLER
EDUCATIONAL CENTER




HEIFER
INTERNATIONAL
CENTER

LITTLE ROCK, ARKANSAS

PSRCP JOB NUMBER:
431E

CONTENTS:
PLUMBING RISER
DIAGRAMS

SHEET NUMBER:
P901

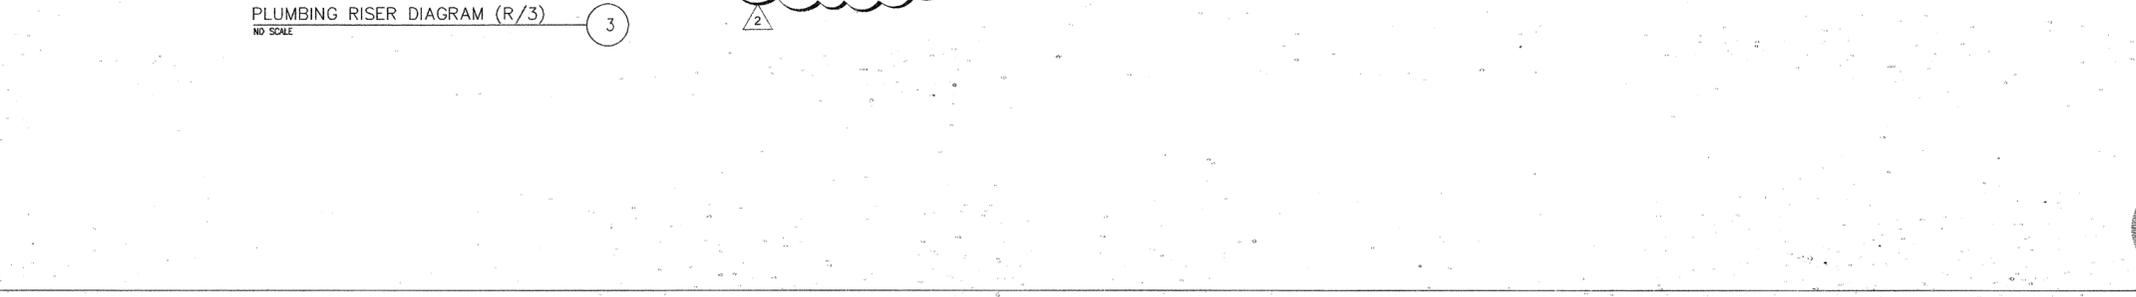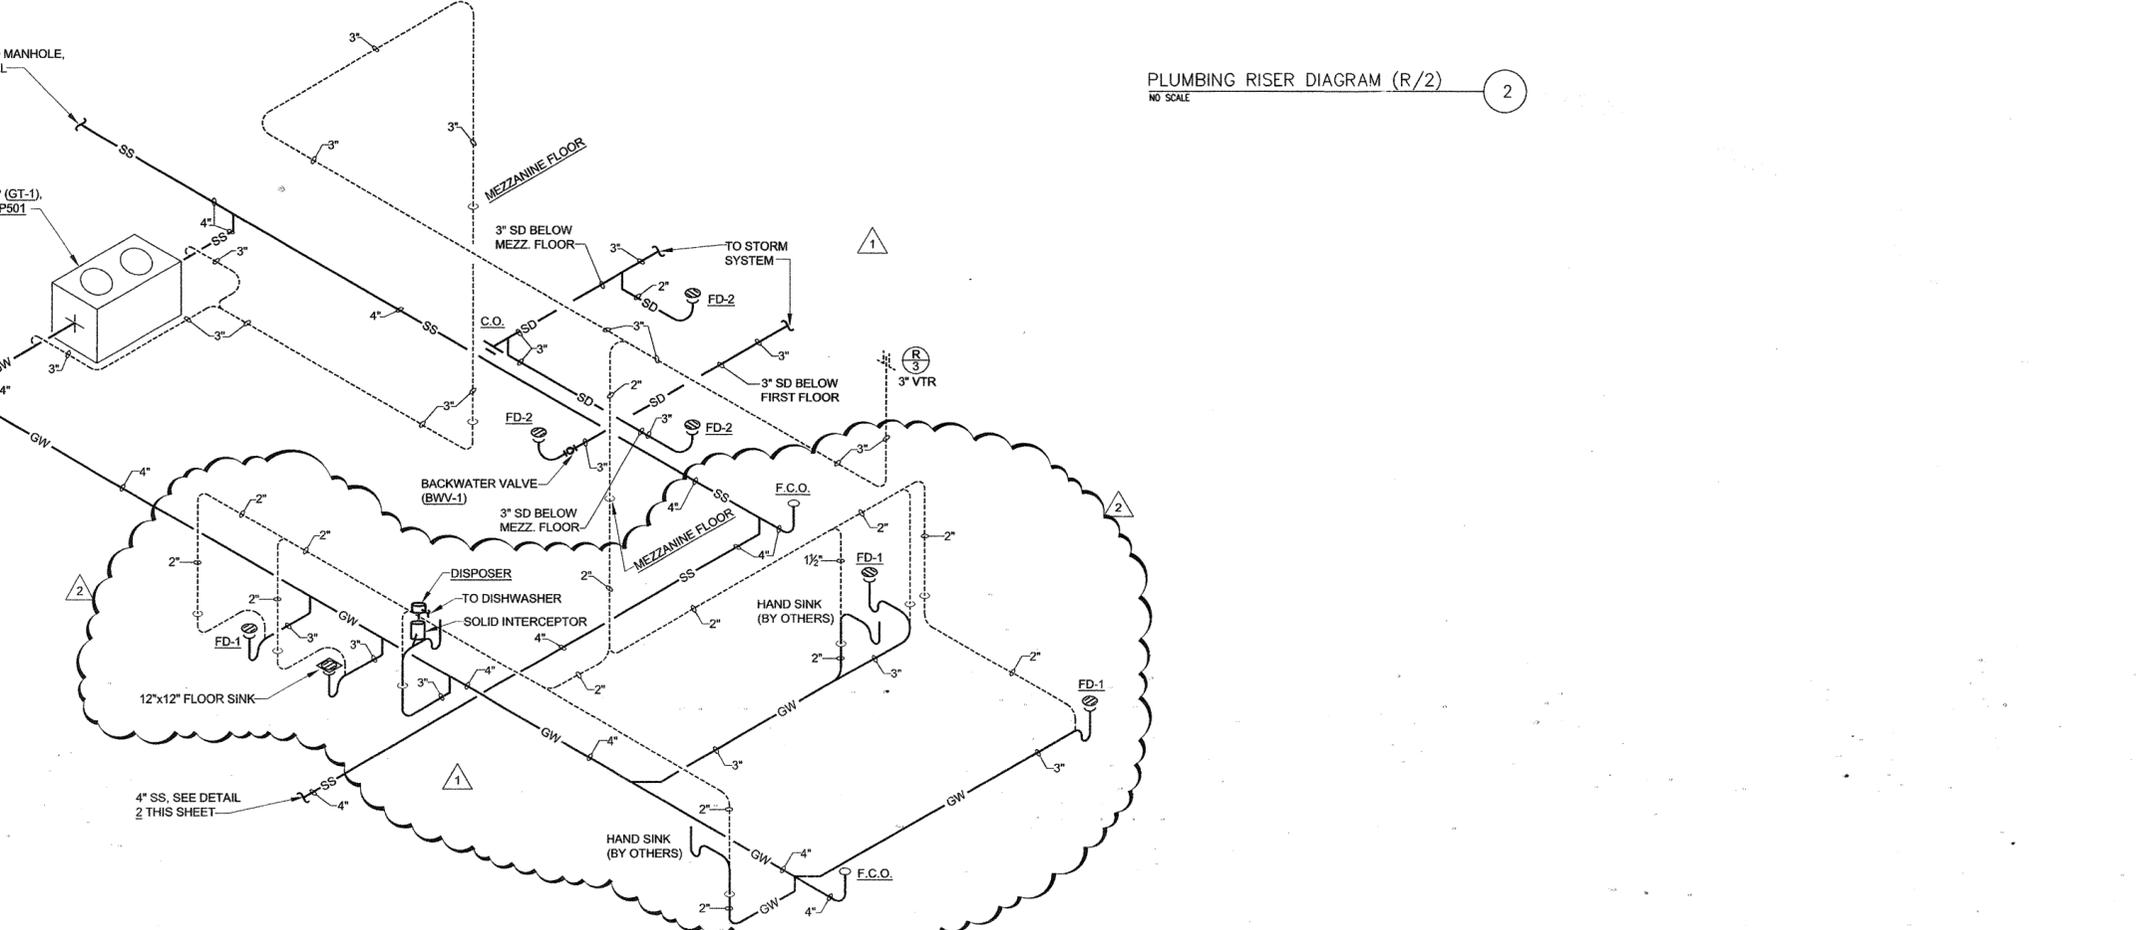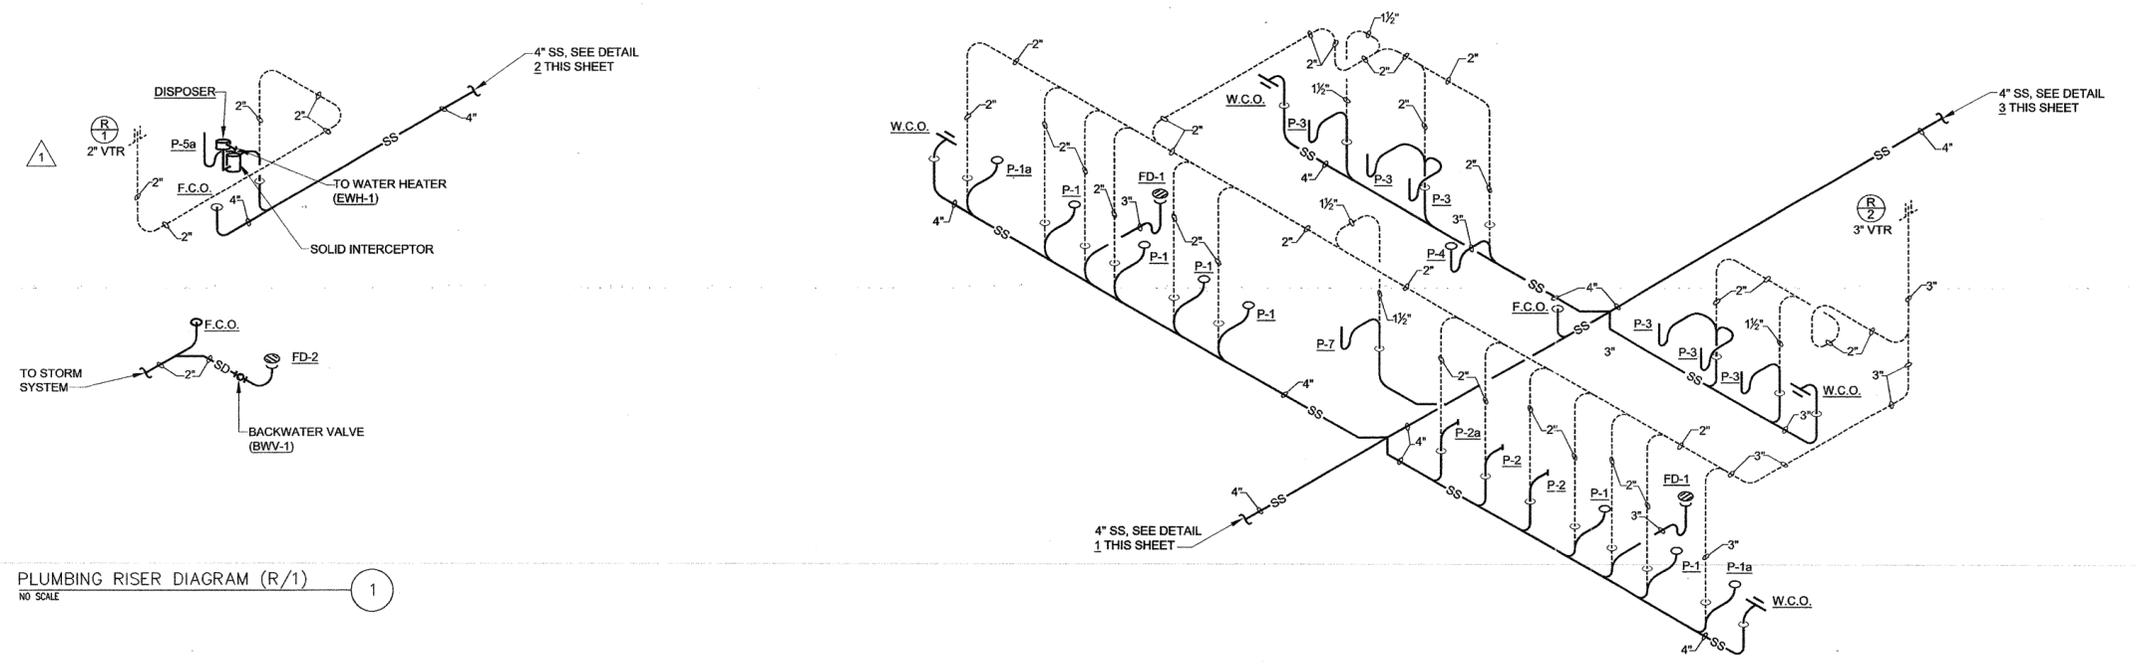

700 SOUTH SCHILLER
LITTLE ROCK, AR 72201
501.378.0878 office
501.372.7629 fax

509 W. SPRING STREET,
SUITE 150
FAYETTEVILLE, AR 72701
479.444.0473 office
473.251.7216 fax

www.polkstanley.com

- CONSULTANTS:
- CIVIL ENGINEER:
MCCELLELAND ENGINEERS
 - LANDSCAPE ARCHITECT:
LARSON BURNS SMITH
 - STRUCTURAL ENGINEER:
CROMWELL ENGINEERS INC.
 - MECH., ELEC., PLUMB. ENGINEER:
CROMWELL ENGINEERS INC.
 - GLOBAL VILLAGE CONSULTANT
CAMBRIDGE SEVEN ASSOCIATES
 - INTERIOR DESIGNER:
POLK STANLEY ROWLAND
CURZON PORTER ARCHITECTS
 - GENERAL CONTRACTOR:
CDI CONTRACTORS, INC.

NOTES:

ISSUE DATE:
17 SEPTEMBER 2007

REVISIONS:

#	DATE:	DESCRIPTION:
1	02/06/08	ASI #2
2	05/16/08	ASI #13
3	02/27/09	ASI #37

MURPHY - KELLER
EDUCATIONAL CENTER


HEIFER
INTERNATIONAL
CENTER

LITTLE ROCK, ARKANSAS

PSRCP JOB NUMBER:
431E

CONTENTS:
PLUMBING RISER
DIAGRAMS

SHEET NUMBER:
P901

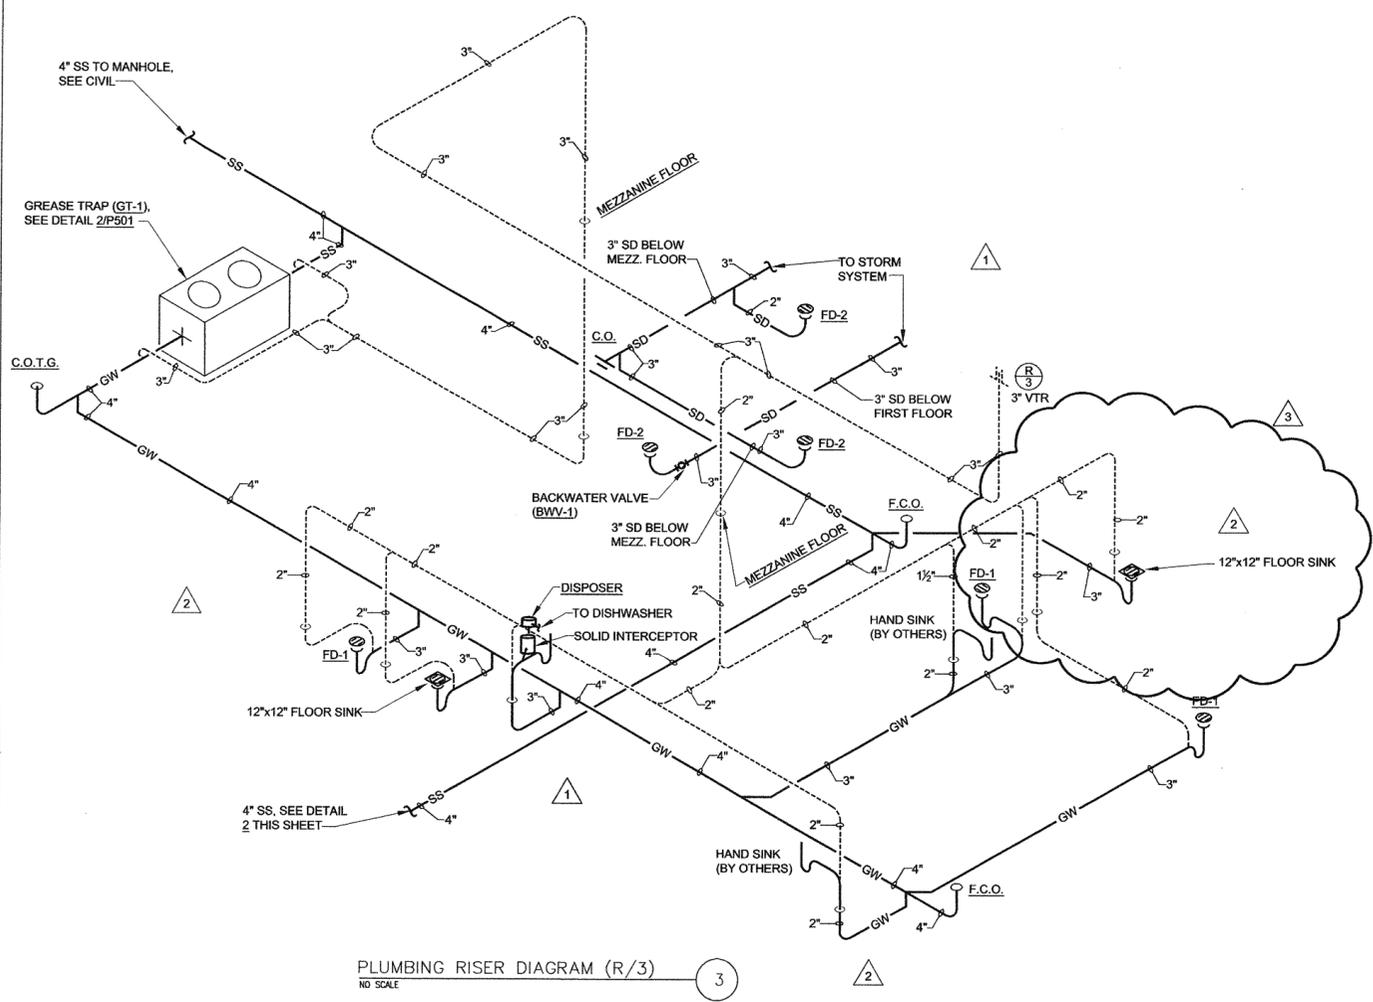

PLUMBING RISER DIAGRAM (R/3)
NO SCALE

