


**GENERAL NOTES:**

1. PROVIDE TRAP PRIMER GUARD INSERTS FOR FLOOR DRAINS IN TOILETS, MECHANICAL ROOMS AND KITCHEN AREA.
2. ALL DOMESTIC WATER PIPING SHALL BE INSULATED.
3. PROVIDE INSULATION FOR ALL HORIZONTAL AND VERTICAL STORM PIPING ABOVE GRADE INSIDE THE BUILDING.
4. RUN ALL GAS PIPING IN VENTILATED AREA OR CEILING SPACE.

**KEYED NOTES:**

- ① 6" STORM DRAIN (SD) DOWN BELOW FLOOR.
- ② 1" COLD & HOT WATER DOWN TO AND FROM ELECTRIC WATER HEATER (EWH-2).
- ③ 1/2" COLD & HOT WATER DOWN IN WALL TO SERVE JANITOR SINK (P-4).
- ④ 6" SD AND 3" FLUE AND UP TO MEZZANINE, SEE PLAN 1/P501. 8" SD DS DOWN BELOW FLOOR.
- ⑤ EWH-1, (40 GALLON WATER HEATER) MOUNTED ON FLOOR WITH 1" CW & HW AND 1/2" GAS CONNECTIONS, SEE DETAIL 7/P501.
- ⑥ 3" VENT UP TO MEZZANINE, SEE PLAN 1/P-501.
- ⑦ 6" DOWNSPOUT NOZZLE (EQUAL TO MIFAB #R1946-3 CAST STAINLESS STEEL, TYPE 304 NOZZLE) SEE ARCH. PLANS FOR ELEVATION.
- ⑧ 6" ASD UP TO MEZZANINE, SEE PLAN 1/P501.
- ⑨ 2" DOWNSPOUT NOZZLE (EQUAL TO MIFAB #R1942-3 CAST STAINLESS STEEL, TYPE 304 NOZZLE) SEE ARCH. PLANS FOR ELEVATION.
- ⑩ 1" GAS MOUNTED AT STRUCTURE, CAPPED FOR FUTURE.
- ⑪ 3/4" CW DOWN WITH TWO-WAY VALVE TO SERVE SINK & ICE MACHINE 3/4" HW DOWN WITH TWO-WAY VALVE TO SERVE SINK & DISHWASHER.
- ⑫ 3/4" CW & HW DOWN TO LAVATORIES (P-3) (TYPICAL OF 3).

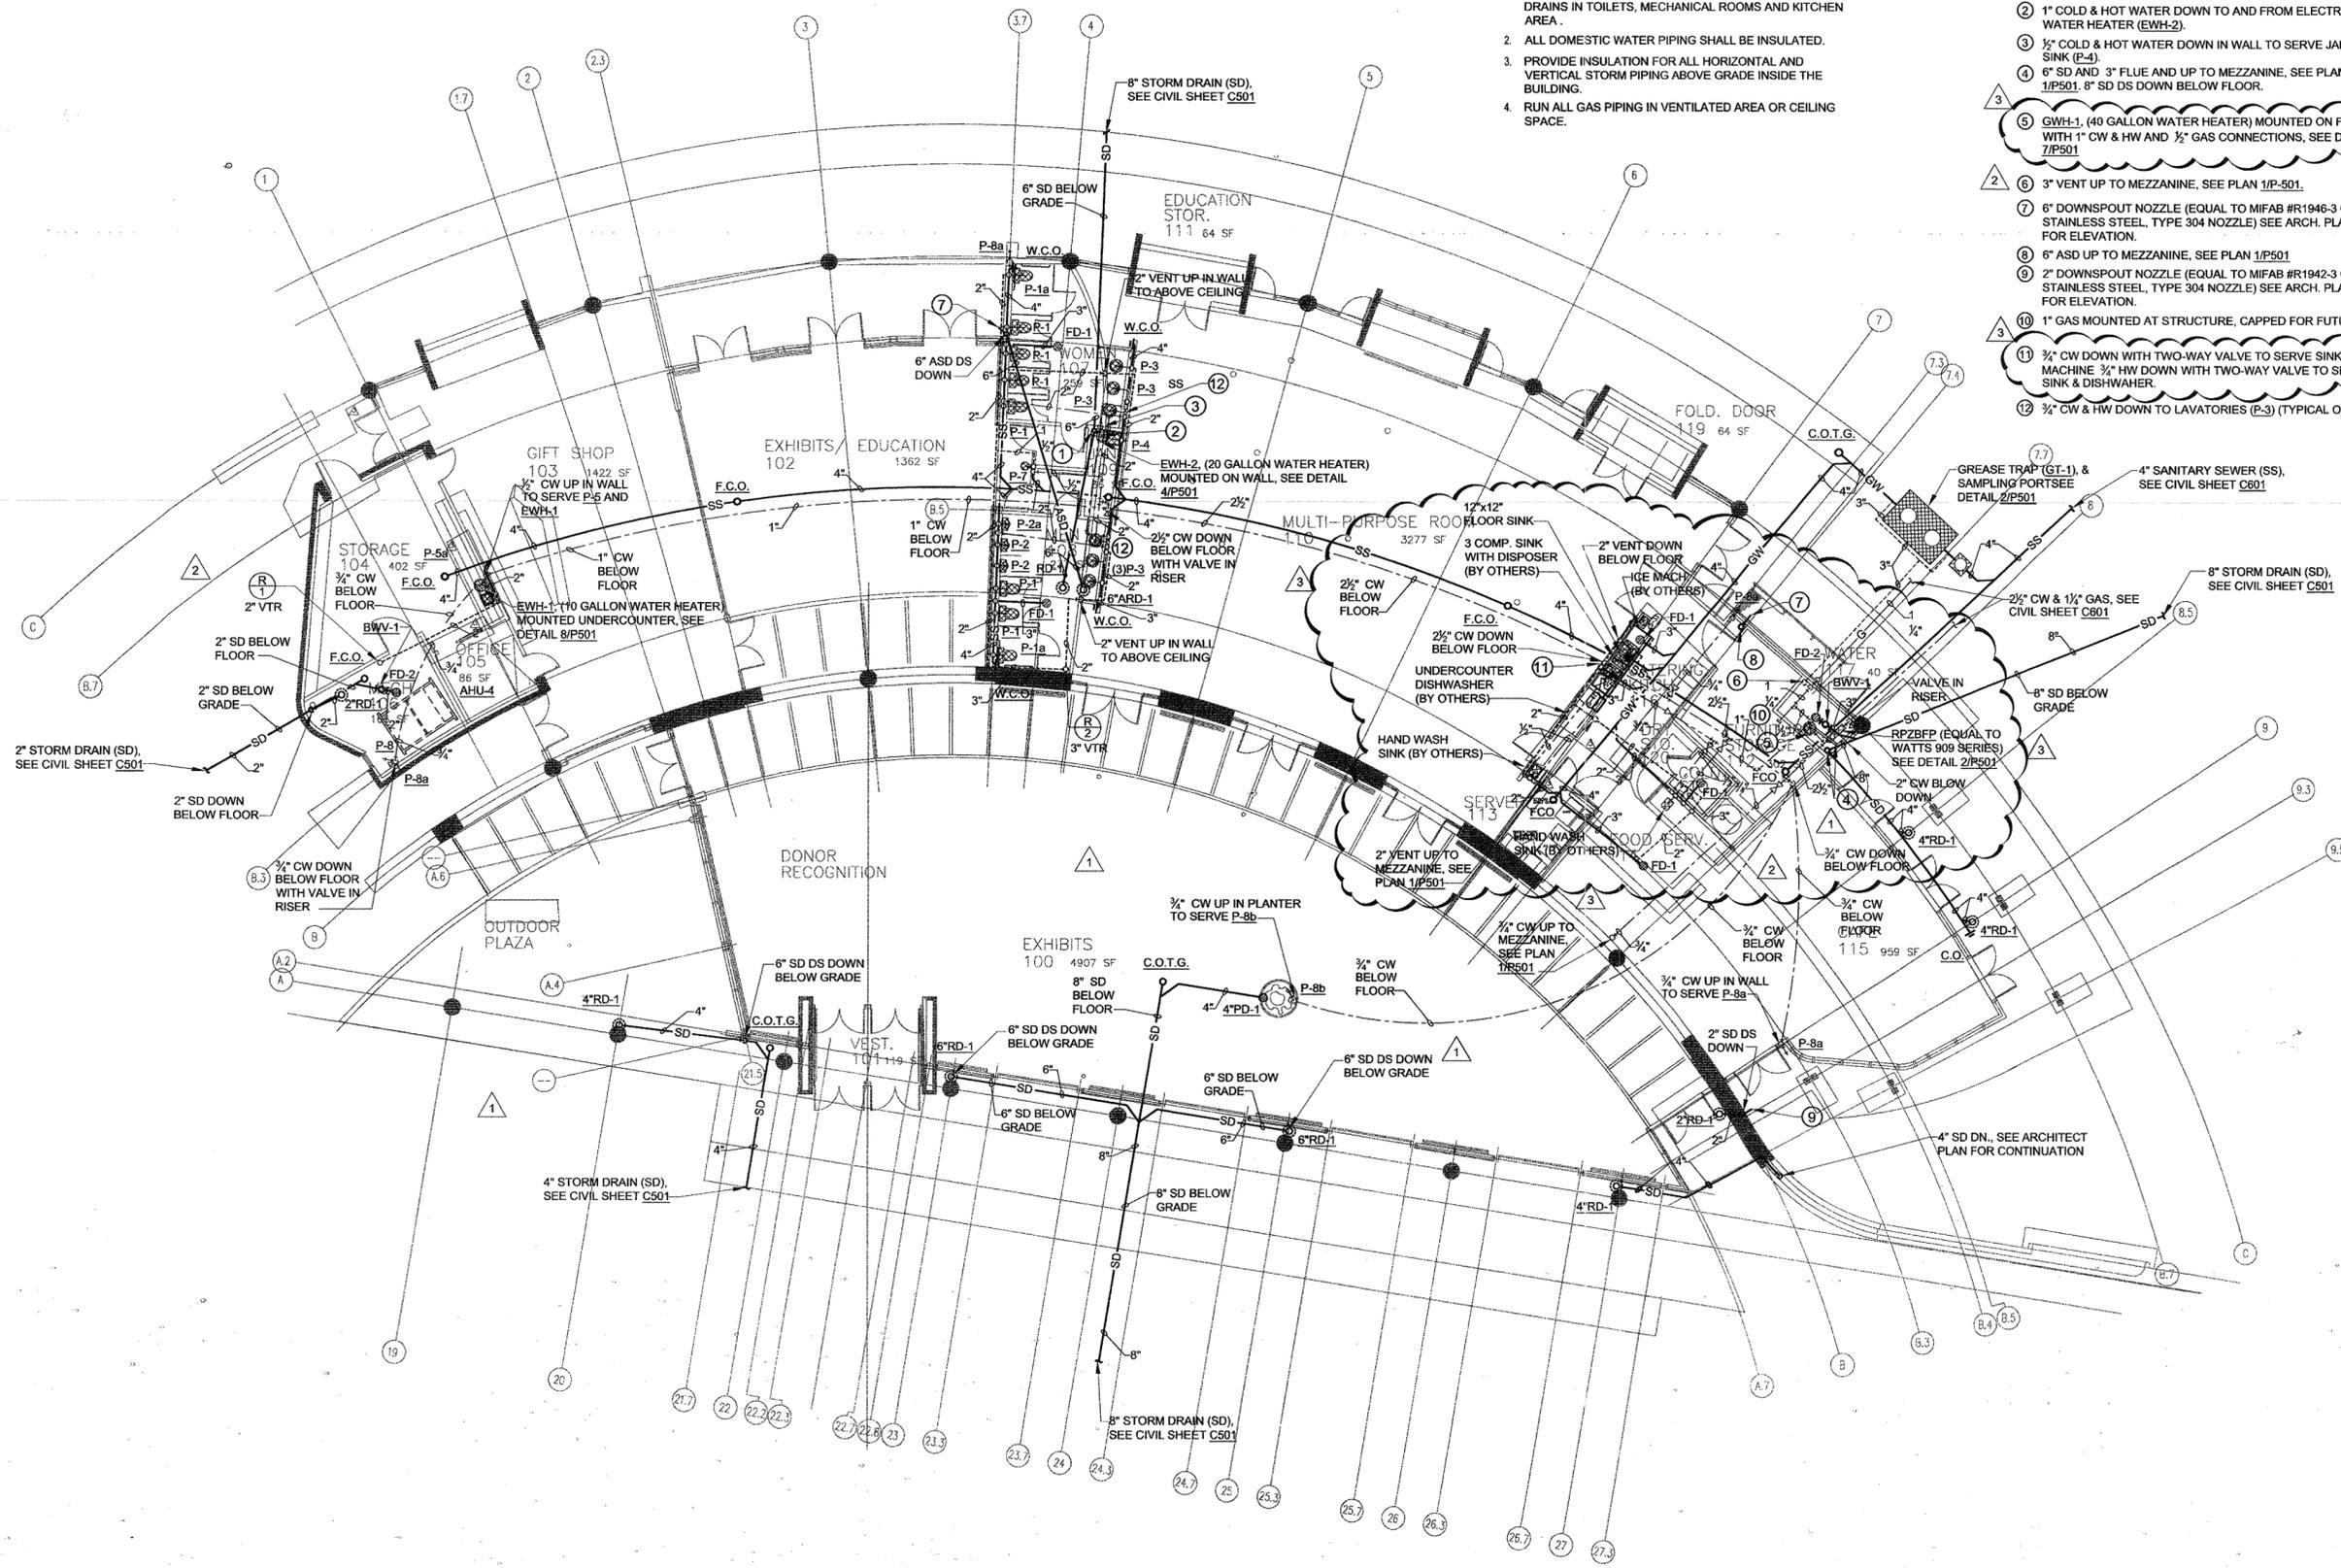

**POLK STANLEY ROWLAND CURZON PORTER ARCHITECTS, LTD.**

700 SOUTH SCHILLER  
LITTLE ROCK, AR 72201  
501.378.0878 office  
501.372.7629 fax  
509 W. SPRING STREET,  
SUITE 150  
FAYETTEVILLE, AR 72701  
479.444.0473 office  
473.251.7216 fax  
www.polkstanley.com

CONSULTANTS:  
CIVIL ENGINEER:  
MCLELLAND ENGINEERS  
LANDSCAPE ARCHITECT:  
LARSON BURNS SMITH  
STRUCTURAL ENGINEER:  
CROMWELL ENGINEERS INC.  
MECH., ELEC., PLUMB. ENGINEER:  
CROMWELL ENGINEERS INC.  
GLOBAL VILLAGE CONSULTANT  
CAMBRIDGE SEVEN ASSOCIATES  
INTERIOR DESIGNER:  
POLK STANLEY ROWLAND  
CURZON PORTER ARCHITECTS  
GENERAL CONTRACTOR:  
CDI CONTRACTORS, INC.

NOTES:  
\_\_\_\_\_  
\_\_\_\_\_  
\_\_\_\_\_  
\_\_\_\_\_  
\_\_\_\_\_

ISSUE DATE:  
17 SEPTEMBER 2007

REVISIONS:

#	DATE	DESCRIPTION
1	01/07/08	ASI #1
2	02/06/08	ASI #2
3	05/16/08	ASI # 14

MURPHY - KELLER  
EDUCATIONAL CENTER

HEIFER  
INTERNATIONAL  
CENTER

LITTLE ROCK, ARKANSAS

PSRCP JOB NUMBER:  
431E

CONTENTS:  
PLUMBING PLAN

SHEET NUMBER:  
P101

NORTH  
PLUMBING PLAN  
SCALE: 1/8"=1'-0"

