

- CONSULTANTS:
- CIVIL ENGINEER: MCCLELAND ENGINEERS
 - LANDSCAPE ARCHITECT: LARSON BURNS SMITH
 - STRUCTURAL ENGINEER: CROMWELL ENGINEERS INC.
 - MECH., ELEC., PLUMB ENGINEER: CROMWELL ENGINEERS INC.
 - GLOBAL VILLAGE CONSULTANT: CAMBRIDGE SEVEN ASSOCIATES
 - INTERIOR DESIGNER: POLK STANLEY ROWLAND CURZON PORTER ARCHITECTS
 - GENERAL CONTRACTOR: CDI CONTRACTORS, INC.

NOTES:


ISSUE DATE:
17 SEPTEMBER 07

REVISIONS:

#	DATE	DESCRIPTION
1	10 OCT 07	ADDENDUM 02
2	7 JAN 08	ASI 01
3	30 APR 08	ASI 11

MURPHY KELLER
EDUCATION CENTER
HEIFER
INTERNATIONAL
CENTER
LITTLE ROCK, ARKANSAS

PSRCP JOB NUMBER:
431E
CONTENTS:
SKYLIGHT FRAMING
PLAN
SHEET NUMBER:
S106

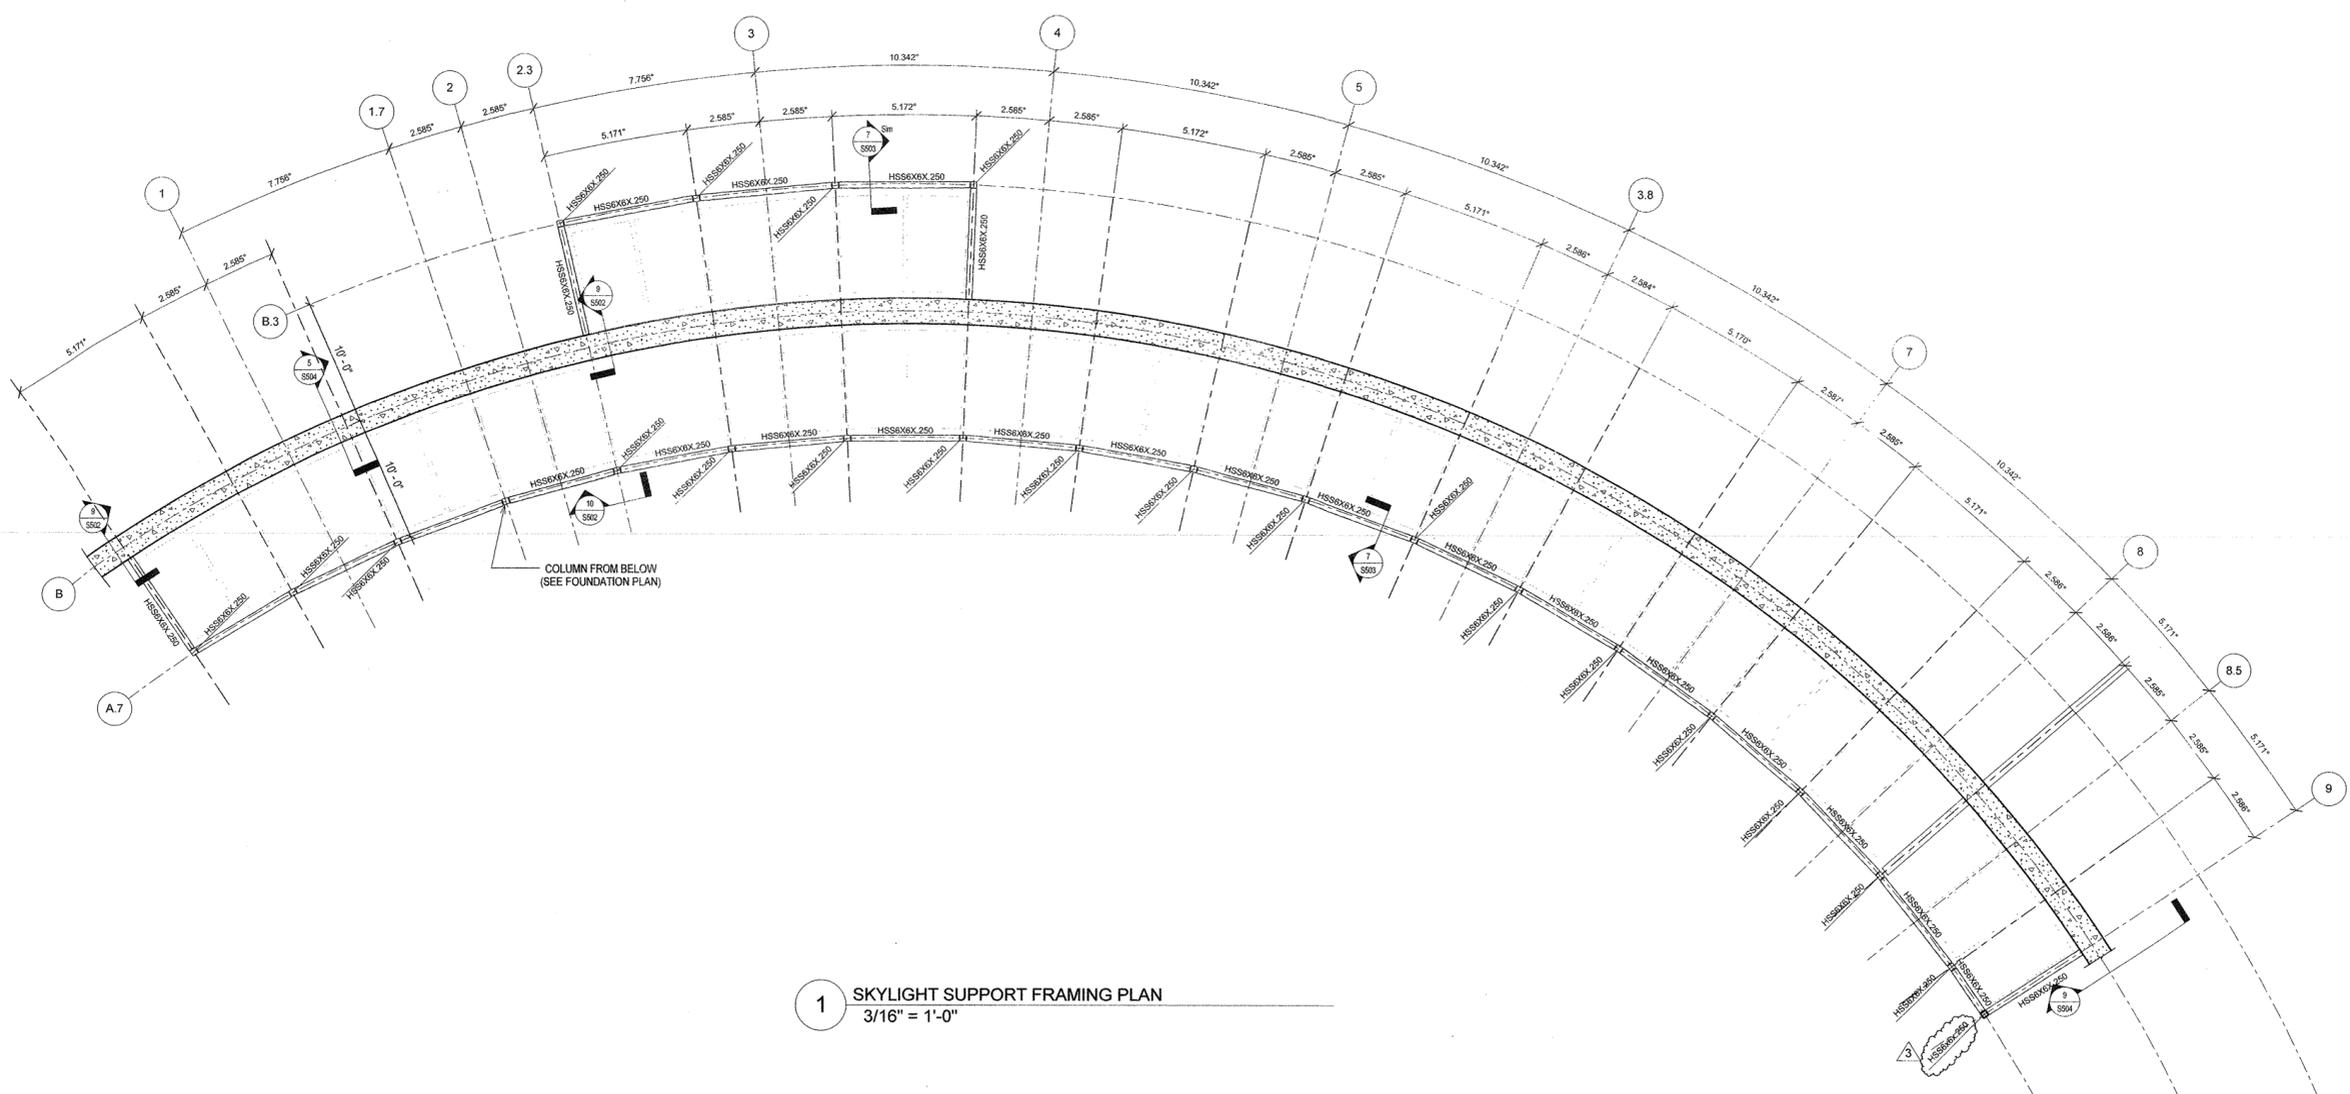

1 SKYLIGHT SUPPORT FRAMING PLAN
3/16" = 1'-0"

