



NEW LIBRARY/NARA HEATING HOT WATER PUMPED BLDG. SKID

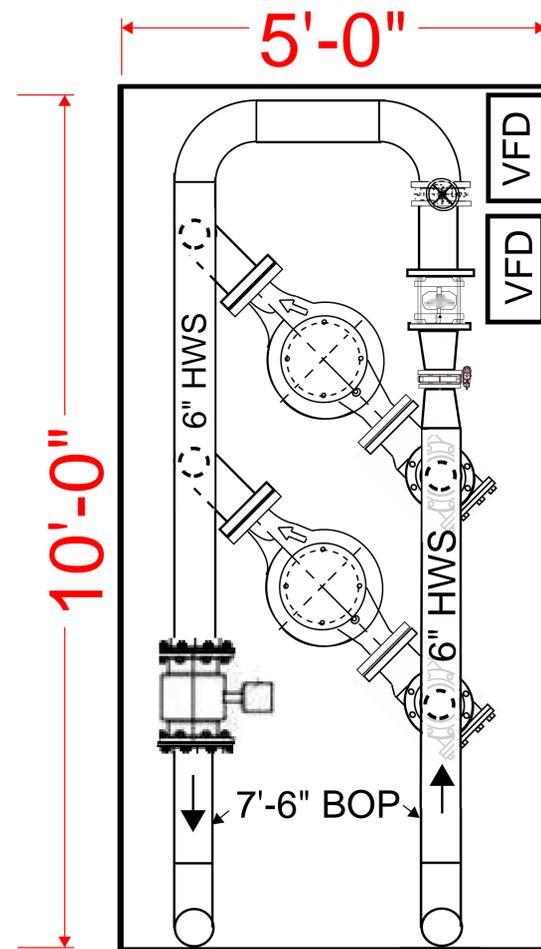

NEW LIBRARY/NARA CHILL WATER PUMPED BLDG. SKID

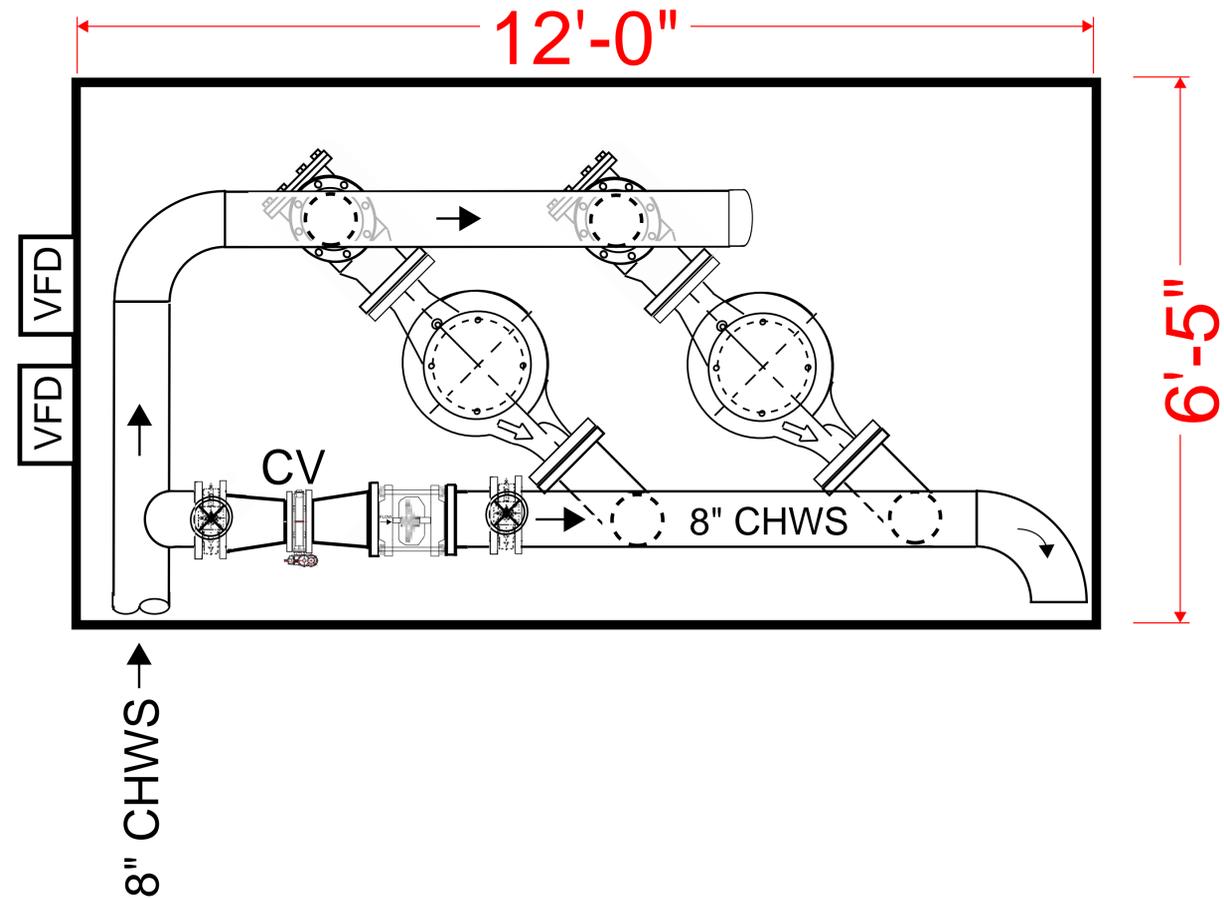

1"=1'-0"

CLINTON SUSTAINABLE ENERGY DISTRICT

CLINTON FOUNDATION
LITTLE ROCK, ARKANSAS

MARK	DATE	DESCRIPTION
ISSUE DATE:		7-9-25
PROJECT NUMBER:		
SHEET TITLE:		WILLIAM J. CLINTON - CENTRAL UTILITY PLANT - BLDG. ENTRY SKIDS

SHEET NUMBER:
M-2