


GENERAL SHEET NOTES


KEYED NOTES

 AIR MOBILITY COMMAND 19TH CIVIL ENGINEER SQUADRON LITTLE ROCK, ARKANSAS	DATE: JULY 2026 DESIGNED BY: Designer DRAWN BY: Author BUILDING NO.: PROJECT NO.: SHEET REF.: A-111		LEVEL TWO REFLECTED CEILING PLAN		APPROVED CHIEF ENGINEER APPROVED CIVIL ENGINEER	REV # DATE	DESCRIPTION	APP D
	DATE: JULY 2026 DESIGNED BY: Designer DRAWN BY: Author BUILDING NO.: PROJECT NO.: SHEET REF.: A-111		LEVEL TWO REFLECTED CEILING PLAN		APPROVED CHIEF ENGINEER APPROVED CIVIL ENGINEER	REV # DATE	DESCRIPTION	APP D
	DATE: JULY 2026 DESIGNED BY: Designer DRAWN BY: Author BUILDING NO.: PROJECT NO.: SHEET REF.: A-111		LEVEL TWO REFLECTED CEILING PLAN		APPROVED CHIEF ENGINEER APPROVED CIVIL ENGINEER	REV # DATE	DESCRIPTION	APP D
	DATE: JULY 2026 DESIGNED BY: Designer DRAWN BY: Author BUILDING NO.: PROJECT NO.: SHEET REF.: A-111		LEVEL TWO REFLECTED CEILING PLAN		APPROVED CHIEF ENGINEER APPROVED CIVIL ENGINEER	REV # DATE	DESCRIPTION	APP D

 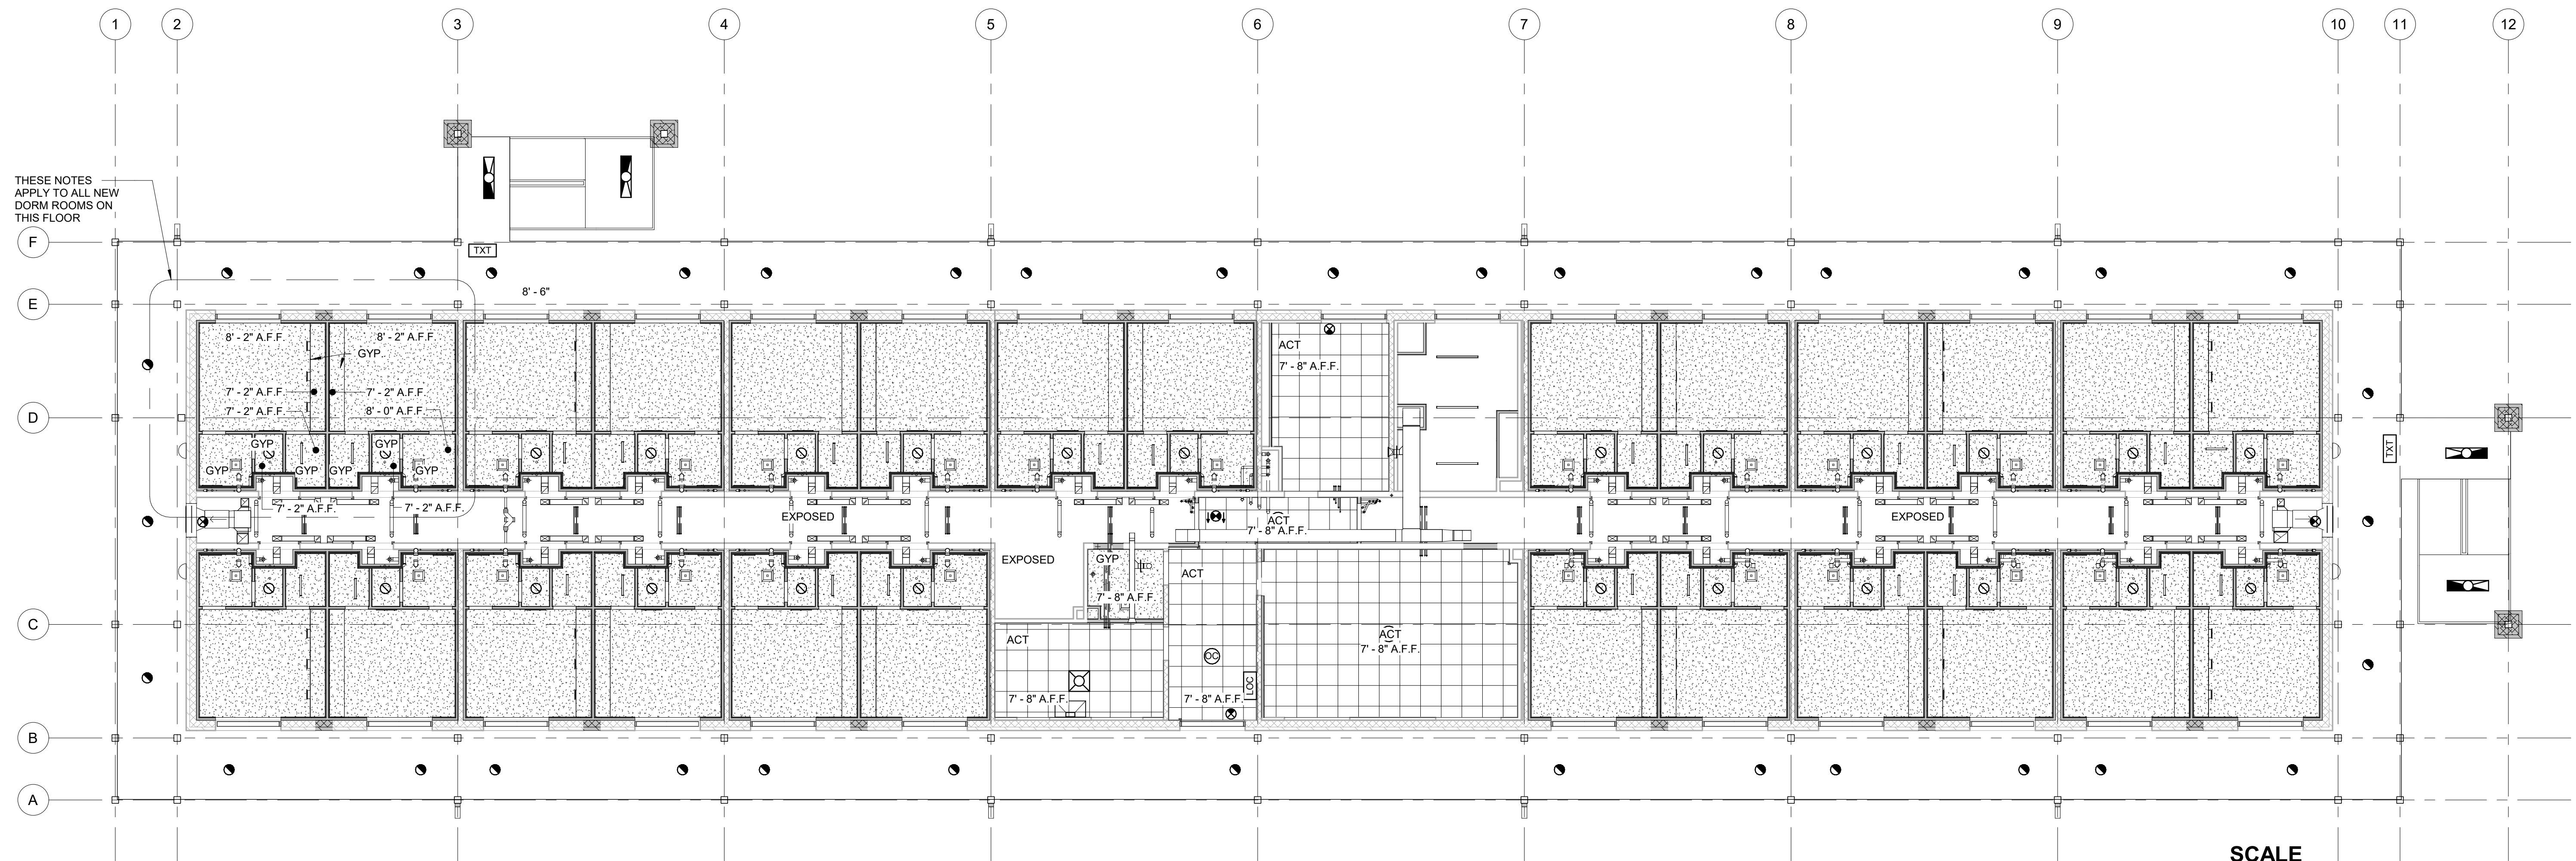


THESE NOTES
APPLY TO ALL NEW
DORM ROOMS ON
THIS FLOOR

SCALE

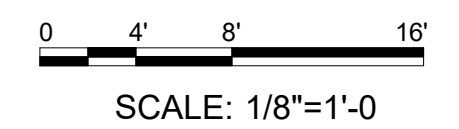

1 CP02 - SECOND FLOOR REFLECTED CEILING PLAN
SCALE: 1/8" = 1'-0"

AIR MOBILITY COMMAND 19TH CIVIL ENGINEER SQUADRON LITTLE ROCK, ARKANSAS	
	
DATE:	JULY 2026
DESIGNED BY:	Designer
DRAWN BY:	Author
BUILDING NO.:	
PROJECT NO.:	
SHEET REF.:	
A-111	
SHEET NO.	1 OF XX