


GENERAL SHEET NOTES


KEYED NOTES

07.08 CEILING ACCESS PANEL

 AIR MOBILITY COMMAND 19TH CIVIL ENGINEER SQUADRON LITTLE ROCK, ARKANSAS										LEVEL THREE REFLECTED CEILING PLAN		NKAK 22-1076 B718 DORM LITTLE ROCK AFB		APPROVED CHIEF ENGINEER APPROVED CIVIL ENGINEER		REV # DATE		DESCRIPTION		APP'D	
										DETAILS (1)											
DATE: JULY 2026 DESIGNED BY: Designer DRAWN BY: Author BUILDING NO.: PROJECT NO.: SHEET NO.: REF.: A-112 SHEET NO.: 1 OF XX																					

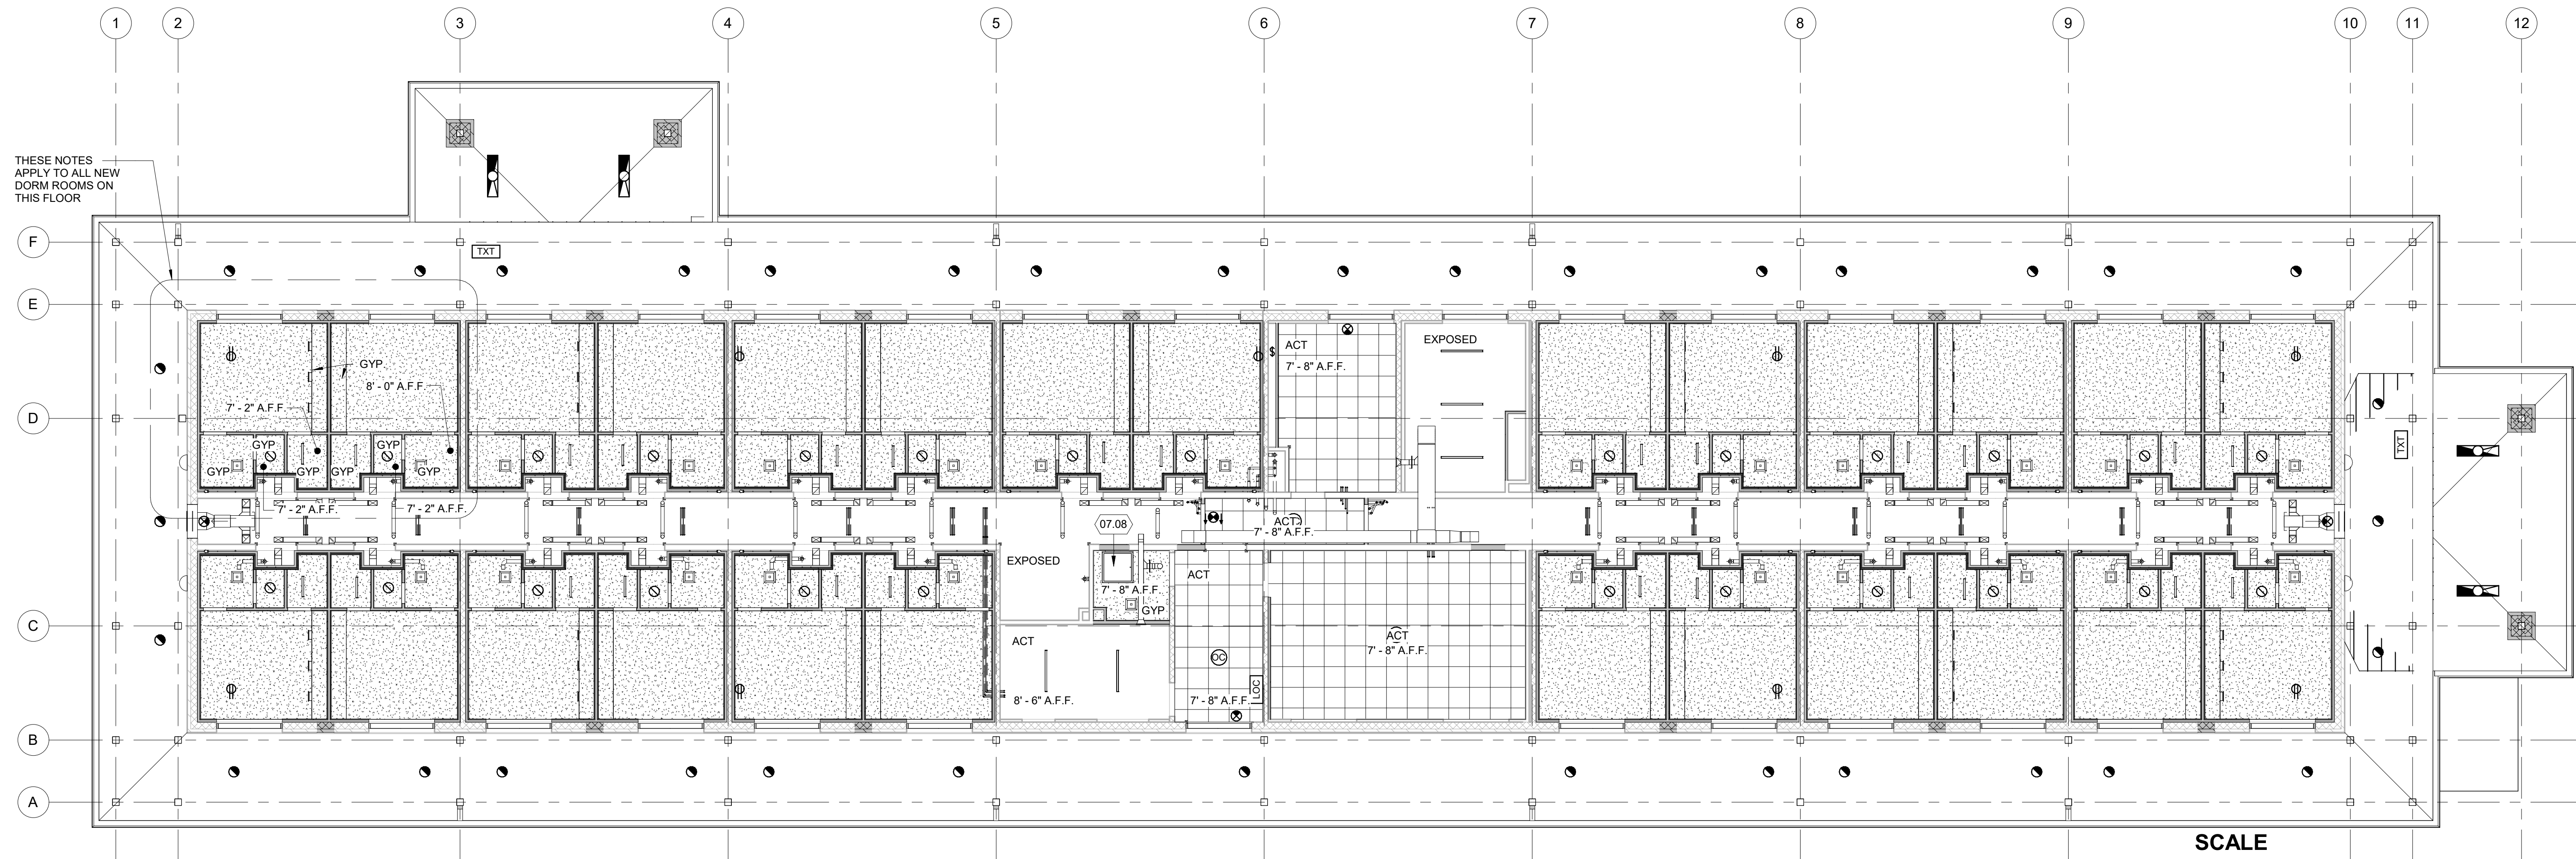

SCALE

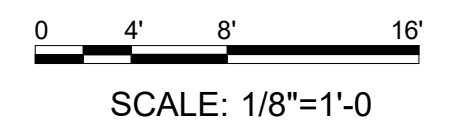

1 CP03 - THIRD FLOOR REFLECTED CEILING PLAN
SCALE: 1/8" = 1'-0"

AIR MOBILITY COMMAND
19TH CIVIL ENGINEER SQUADRON
LITTLE ROCK, ARKANSAS



DATE:	JULY 2026
DESIGNED BY:	Designer
DRAWN BY:	Author
BUILDING NO.:	
PROJECT NO.:	
SHEET REF.:	
A-112	
SHEET NO.:	
1 OF XX	