



ARCHITECT:

CONSULTANTS

Project Status

NOT FOR
CONSTRUCTION

[illegible]

PROJECT TITLE
CCR For Repair Airmen
Dormitory B718

SHEET TITLE

PROPOSED THIRD FLOOR
REFLECTED CEILING PLAN -
RENOVATION

TECH REVIEWER	
---------------	--

PROJECT NUMBER	NKAK 22-1076
----------------	--------------

DESIGNED BY

 

SHEE

DATE
07-17-2025

A-203

SCALE
1/8" = 1'-0"

19 OF 33

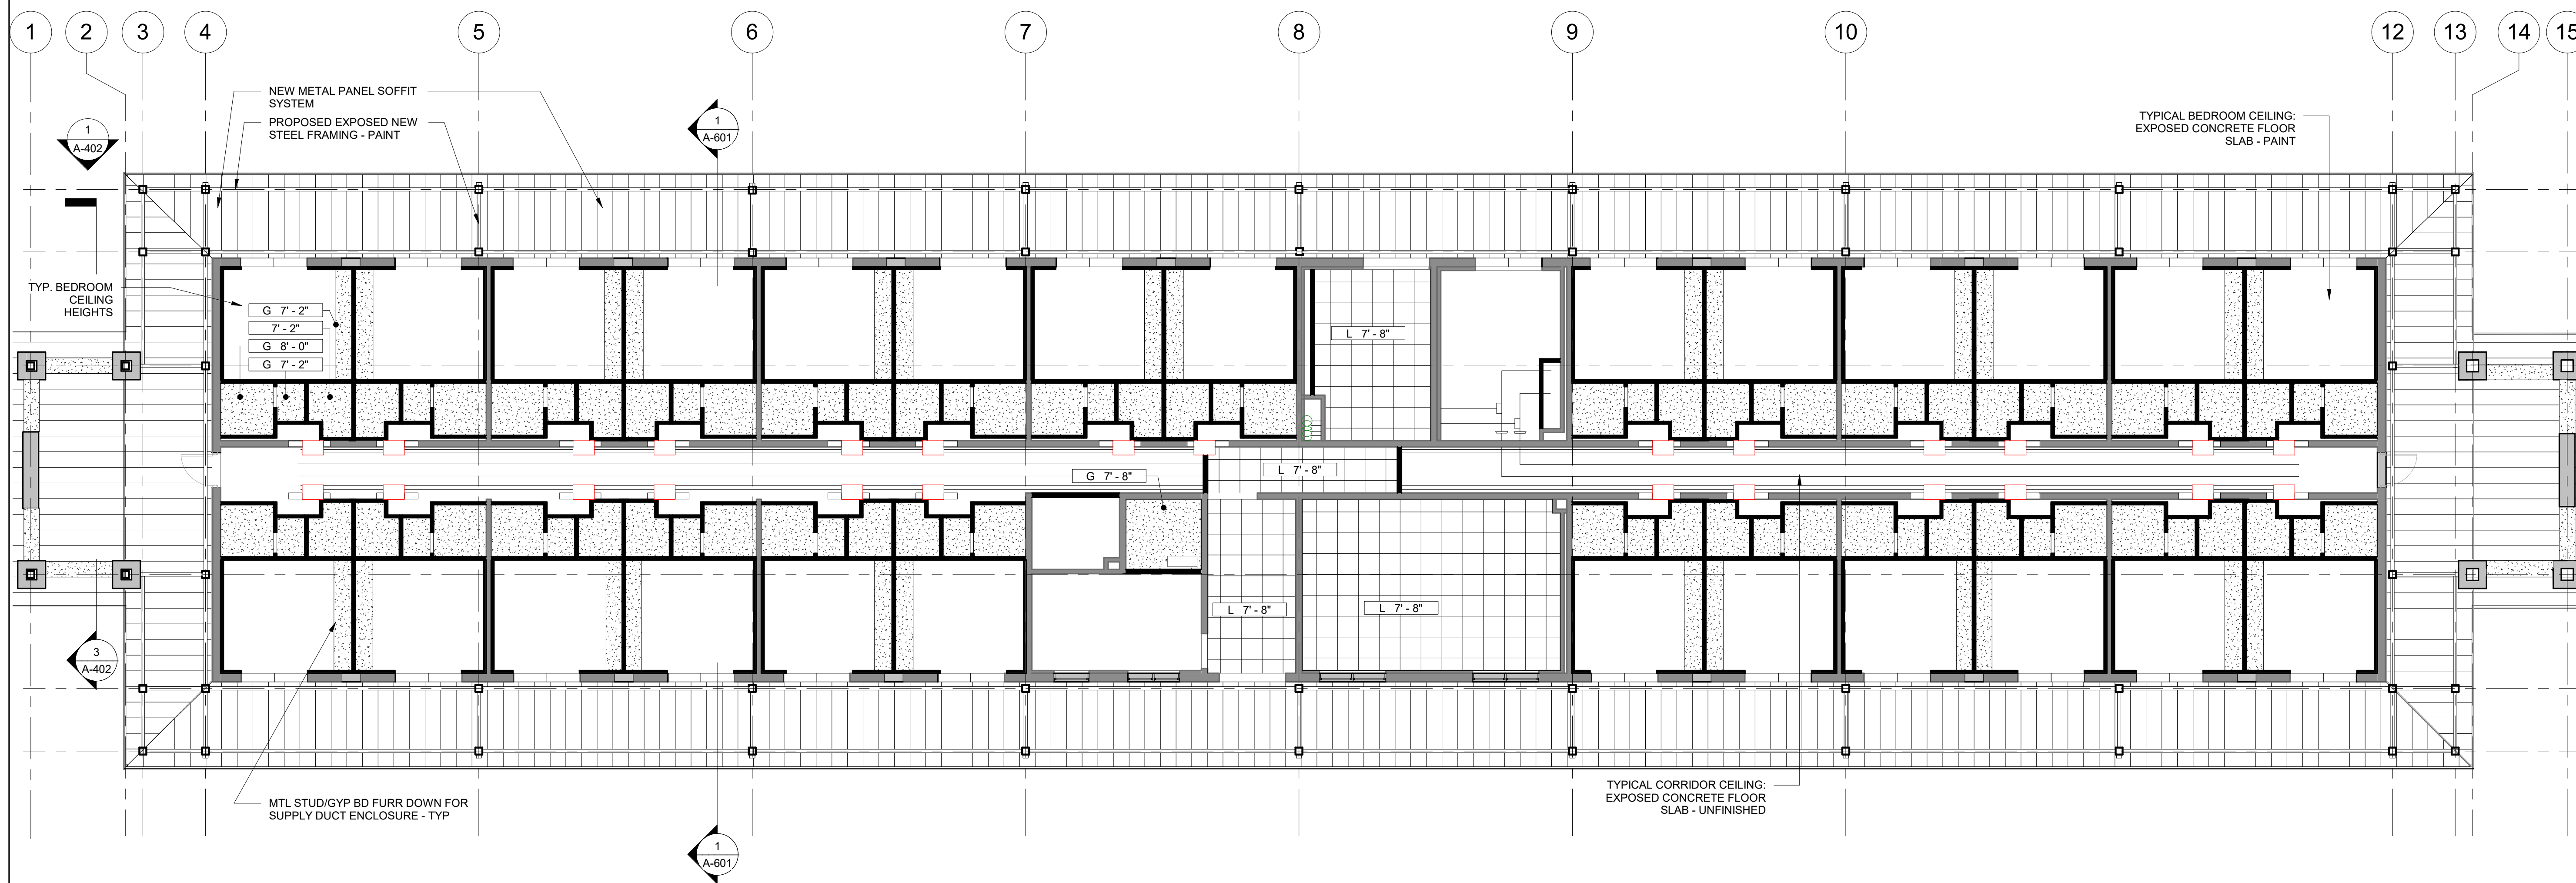

1

THIRD FLOOR REFLECTED CEILING PLAN - RENOVATION

1/8" = 1'-0"

