


GENERAL SHEET NOTES

1. All 20A BRANCH CIRCUITS SUPPLYING OUTLETS IN DORM ROOMS ARE REQUIRED TO BE AFCI PROTECTED PER NEC 210.12(C)

 
KEYED NOTES

E6 RECEPTACLE ADJACENT TO DOOR TO BE DEDICATED FOR PORTABLE AIR CONDITIONING UNIT.

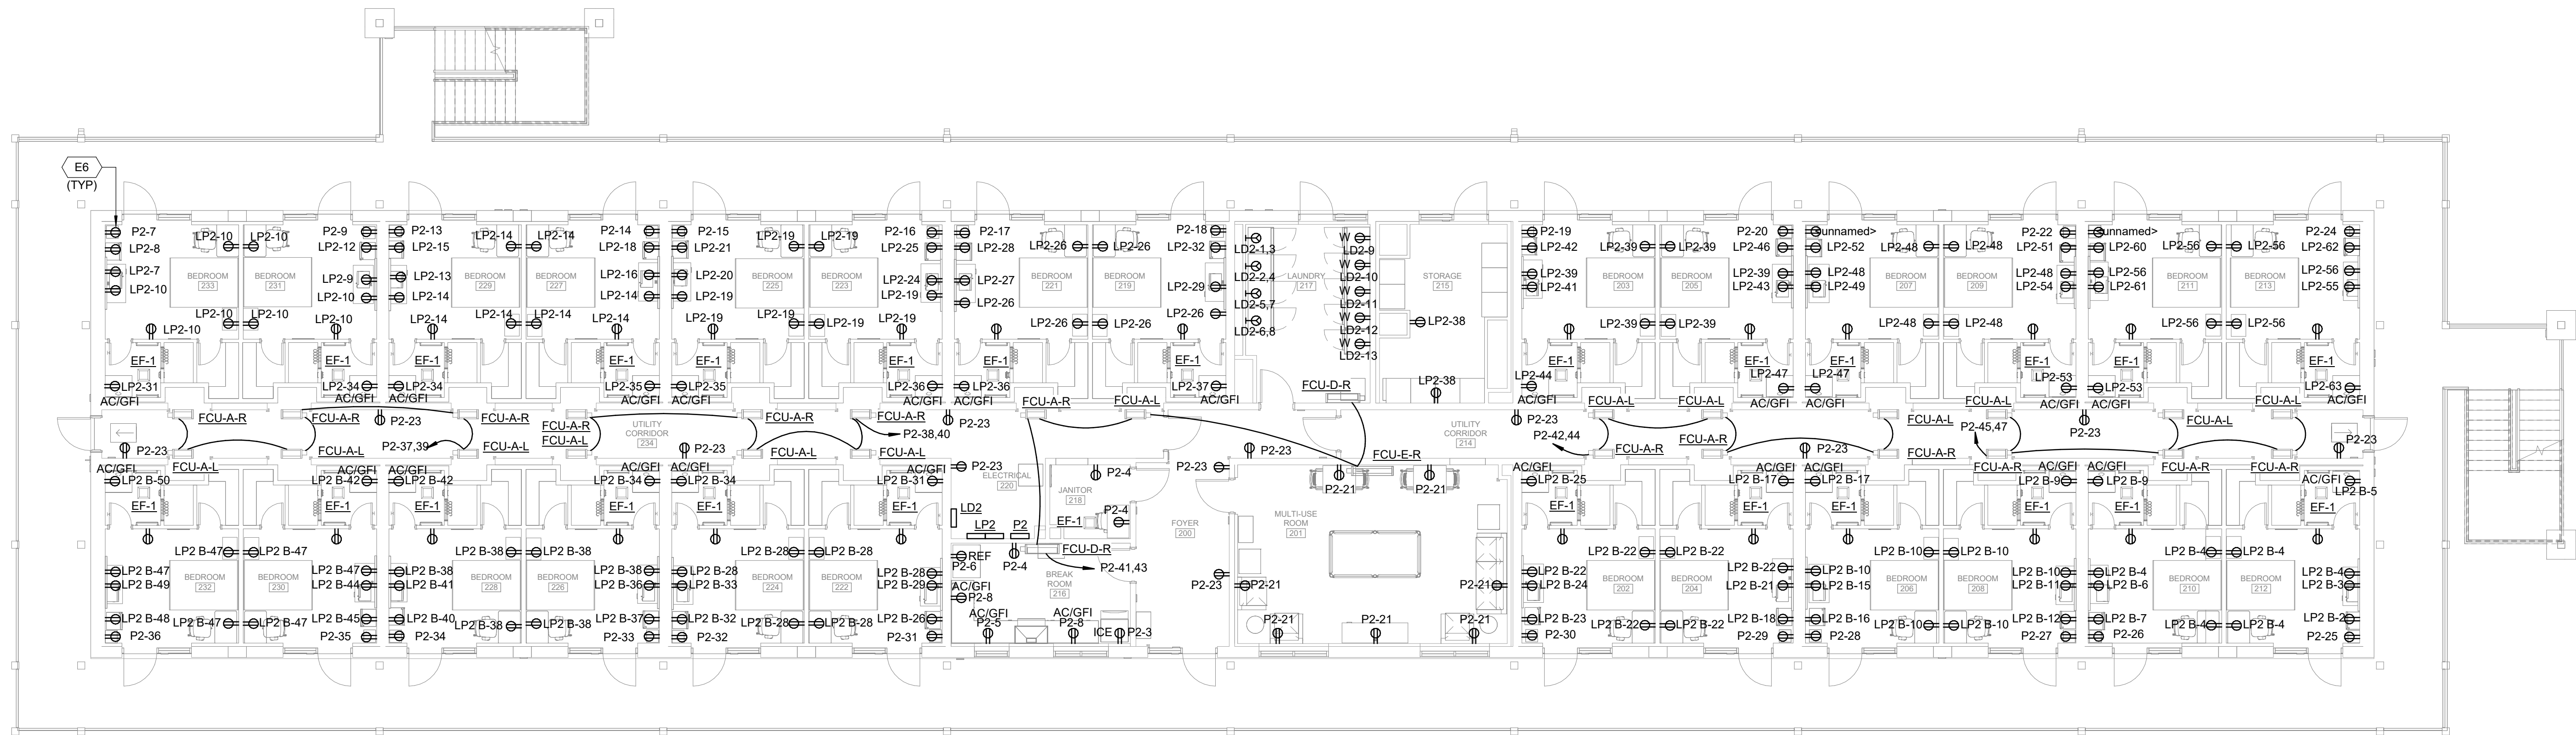

LEVEL 2 POWER PLAN

SCALE: 1/8" = 1'-0"

SCALE

SCALE: 1/8"=1'-0

	AIR MOBILITY COMMAND 19TH CIVIL ENGINEER SQUADRON LITTLE ROCK, ARKANSAS		DATE: JULY 2026 DESIGNED BY: JLS DRAWN BY: MUC BUILDING NO.: PROJECT NO.: SHEET REF.:		SHEET NO.: 1 OF XX
	LEVEL TWO POWER FLOOR PLAN		NKAK 22-1076 B718 DORM LITTLE ROCK AFB		APPROVED CHIEF ENGINEER APPROVED CIVIL ENGINEER
	DETAILS (1)		APPROVED CHIEF ENGINEER APPROVED CIVIL ENGINEER		APPROVED CHIEF ENGINEER APPROVED CIVIL ENGINEER
	DETAILS (1)		APPROVED CHIEF ENGINEER APPROVED CIVIL ENGINEER		APPROVED CHIEF ENGINEER APPROVED CIVIL ENGINEER