
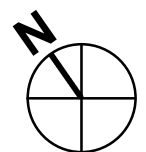


## GENERAL SHEET NOTES

1. All 20A BRANCH CIRCUITS SUPPLYING OUTLETS IN DORM ROOMS ARE REQUIRED TO BE AFCI PROTECTED PER NEC 210.12(C)

## KEYED NOTES

 
E6 RECEPTACLE ADJACENT TO DOOR TO BE DEDICATED FOR PORTABLE AIR CONDITIONING UNIT.

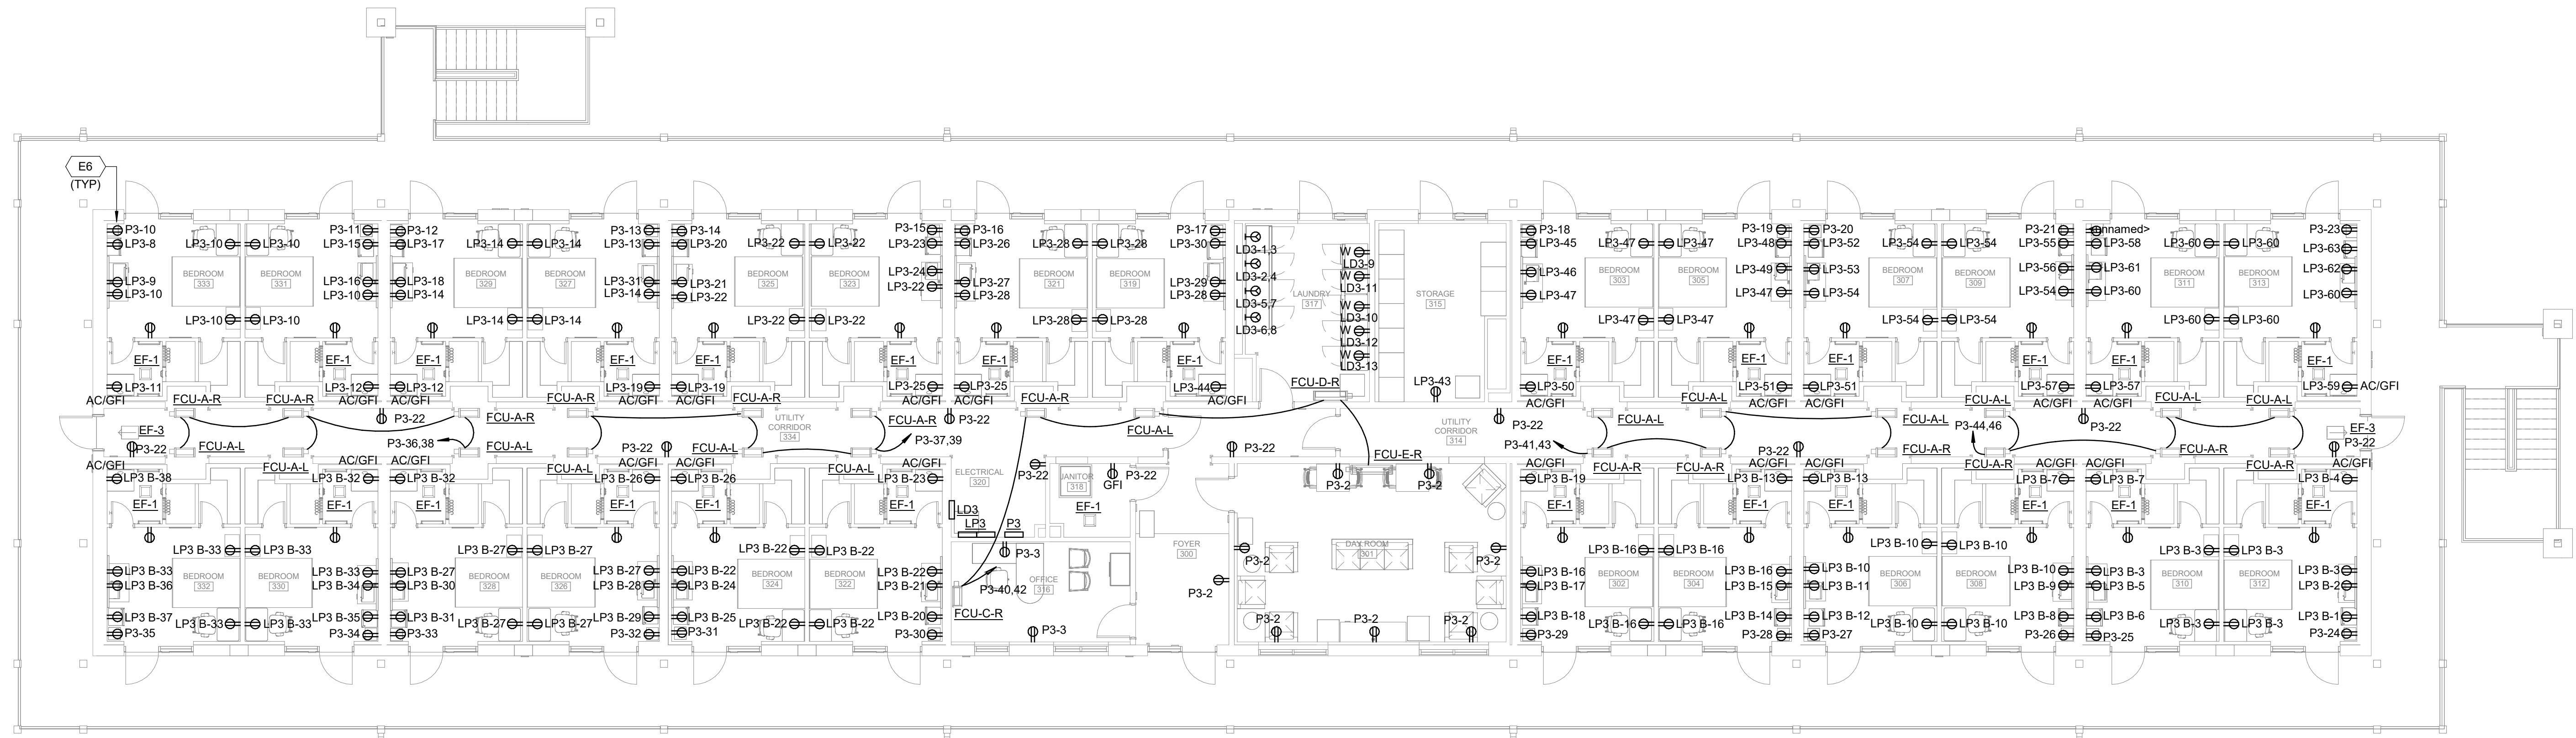

D1

## LEVEL 3 POWER PLAN

SCALE: 1/8" = 1'-0"

**SCALE**

SCALE: 1/8"=1'-0

| DATE                                                                                                                                                                                                                                                                                                                        | DESCRIPTION | REV # | DATE | APPROVED | APP'D |
|-----------------------------------------------------------------------------------------------------------------------------------------------------------------------------------------------------------------------------------------------------------------------------------------------------------------------------|-------------|-------|------|----------|-------|
| JULY 2026                                                                                                                                                                                                                                                                                                                   |             |       |      |          |       |
| DESIGNED BY:                                                                                                                                                                                                                                                                                                                |             |       |      |          |       |
| DRAWN BY:                                                                                                                                                                                                                                                                                                                   |             |       |      |          |       |
| MUC BUILDING NO.:                                                                                                                                                                                                                                                                                                           |             |       |      |          |       |
| PROJECT NO.:                                                                                                                                                                                                                                                                                                                |             |       |      |          |       |
| SHEET REF.:                                                                                                                                                                                                                                                                                                                 |             |       |      |          |       |
| <div>  <div> <div>AIR MOBILITY COMMAND</div> <div>19TH CIVIL ENGINEER SQUADRON</div> <div>LITTLE ROCK, ARKANSAS</div> </div> </div>                                                                                                      |             |       |      |          |       |
| <div> <div> <div>DATE:</div> <div>JULY 2026</div> </div> <div> <div>DESIGNED BY:</div> <div>JLS</div> </div> <div> <div>DRAWN BY:</div> <div>MUC</div> </div> <div> <div>MUC BUILDING NO.:</div> <div></div> </div> <div> <div>PROJECT NO.:</div> <div></div> </div> <div> <div>SHEET REF.:</div> <div></div> </div> </div> |             |       |      |          |       |
| <div> <div>E-103</div> <div>1 OF 10</div> </div>                                                                                                                                                                                                                                                                            |             |       |      |          |       |