


KEYED NOTES

- | | | | | | | | |
|--|-------------------------------|---------|--|-------------------------|-------|------|-------------|
|  <p>AIR MOBILITY COMMAND</p> <p>19TH CIVIL ENGINEER SQUADRON
LITTLE ROCK, ARKANSAS</p> | LEVEL ONE LIGHTING FLOOR PLAN | | | | | | |
| | | | NKAK 22-1076
B718 DORM
LITTLE ROCK AFB | APPROVED | REV # | DATE | DESCRIPTION |
| | | | | CIVIL ENGINEER APPROVED | | | |
| | | | DETAILS (1) | | | | |
| | | | | | | | |
| | | | | | | | |
| DATE: JULY 2026
DESIGNED BY: JLS
DRAWN BY: MUC
BUILDING NO.:

PROJECT NO.:

SHEET REF.: | | E-201 | | | | | |
| SHEET NO. | | 1 OF XX | | | | | |

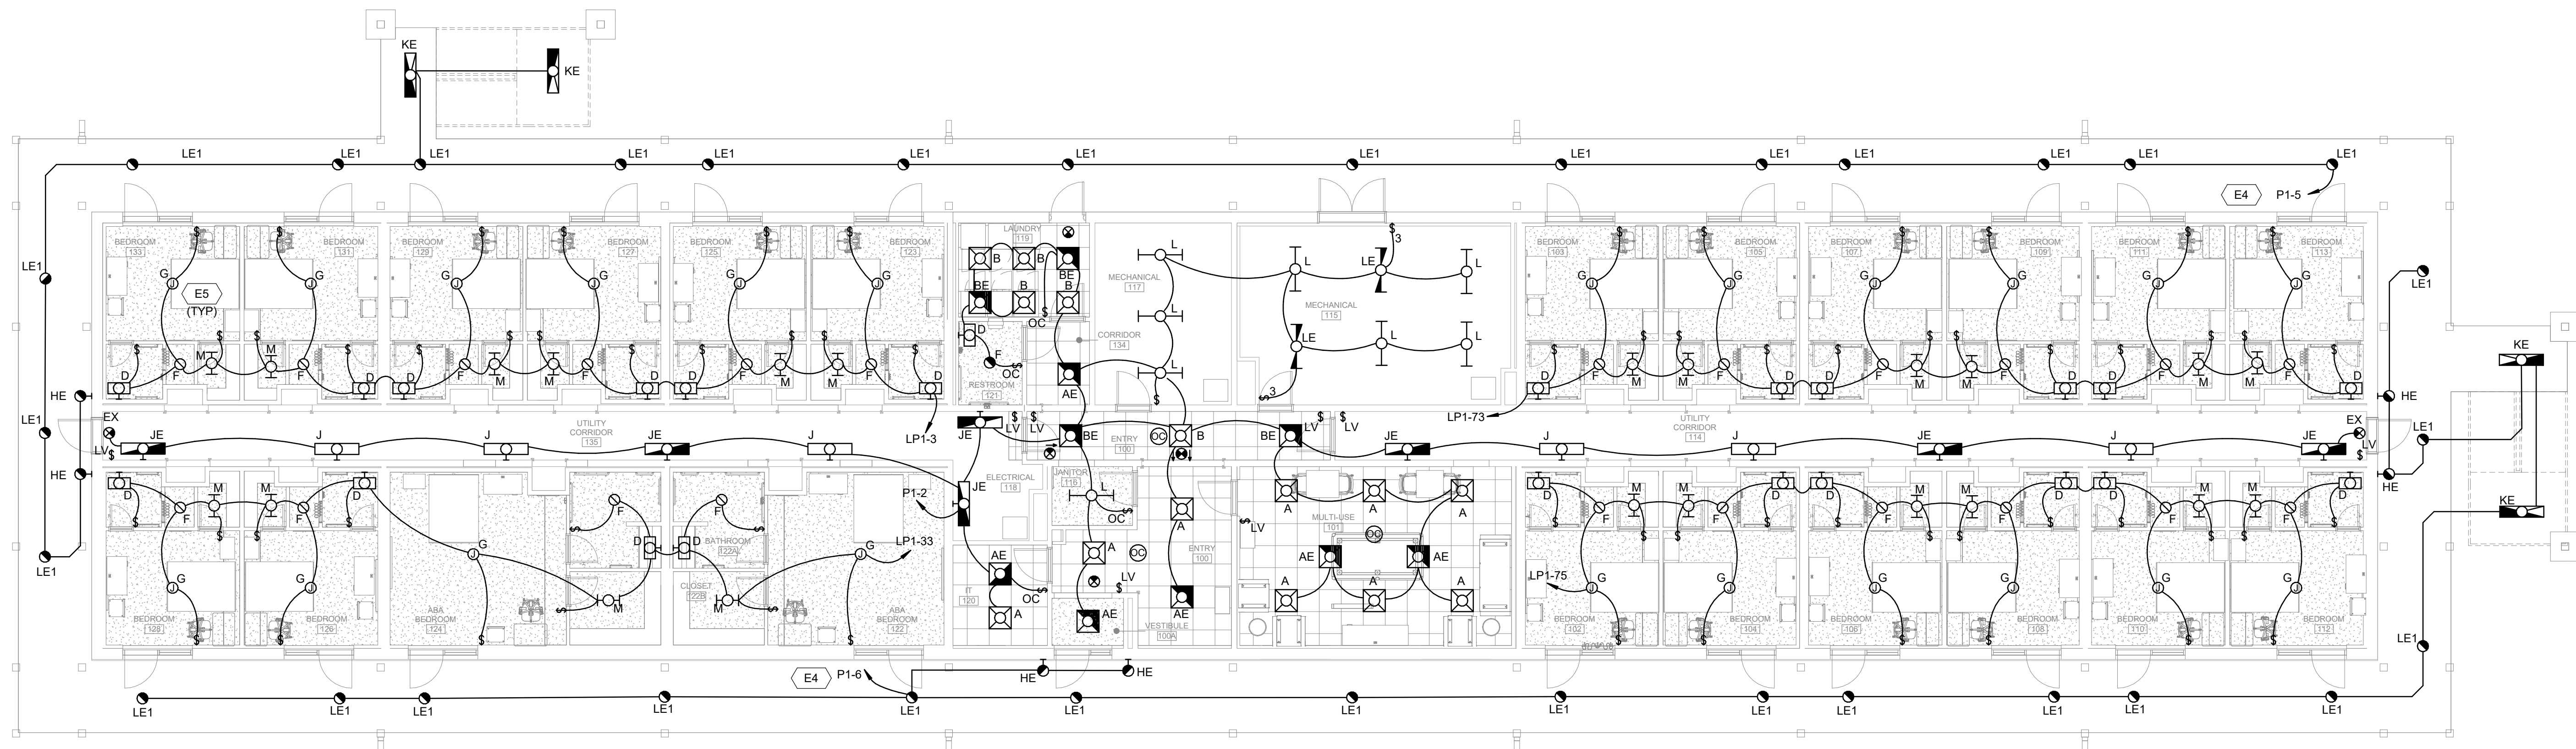

1

SCALE: 1/8" = 1'-0"

0 4' 8' 16'

SCALE: 1/8"=1'-0"