


GENERAL SHEET NOTES


KEYED NOTES

- E4 ROUTE EXTERIOR LIGHTING CIRCUIT THROUGH TIMECLOCK PRIOR TO ROUTING TO EXTERIOR LIGHTING FIXTURES. CIRCUIT TO BE CONTROLLED PHOTOCELL ON/TIMECLOCK OFF. COORDINATE ON/OFF SCHEDULE OF ALL CIRCUITS WITH BASE REPRESENTATIVE.
- E5 PROVIDE CIRCADIAN RHYTHM LIGHTING SYSTEM IN DORMITORY SLEEPING AREA. LIGHTING SHALL UTILIZE TUNABLE-WHITE LED LUMINAIRES WITH HARD-WIRED CONTROLS CAPABLE OF AUTOMATIC COLOR OR TEMPERATURE AND LIGHT OUTPUT ADJUSTMENT BASED ON A PROGRAMMABLE TIME-OF-DAY SCHEDULE. PROVIDE LOCAL OCCUPANT ON/OFF AND DIMMING CONTROL.

 AIR MOBILITY COMMAND 19TH CIVIL ENGINEER SQUADRON LITTLE ROCK, ARKANSAS	LEVEL TWO LIGHTING FLOOR PLAN	NKAK 22-1076 B718 DORM LITTLE ROCK AFB DETAILS (1)	APPROVED	REV #	DATE	DESCRIPTION	APP'D
			CHIEF ENGINEER				
			APPROVED				
			CIVIL ENGINEER				
DATE: JULY 2026 DESIGNED BY: JLS DRAWN BY: MUC BUILDING NO.: PROJECT NO.: SHEET REF.: E-202 SHEET NO.: 1 OF 20							

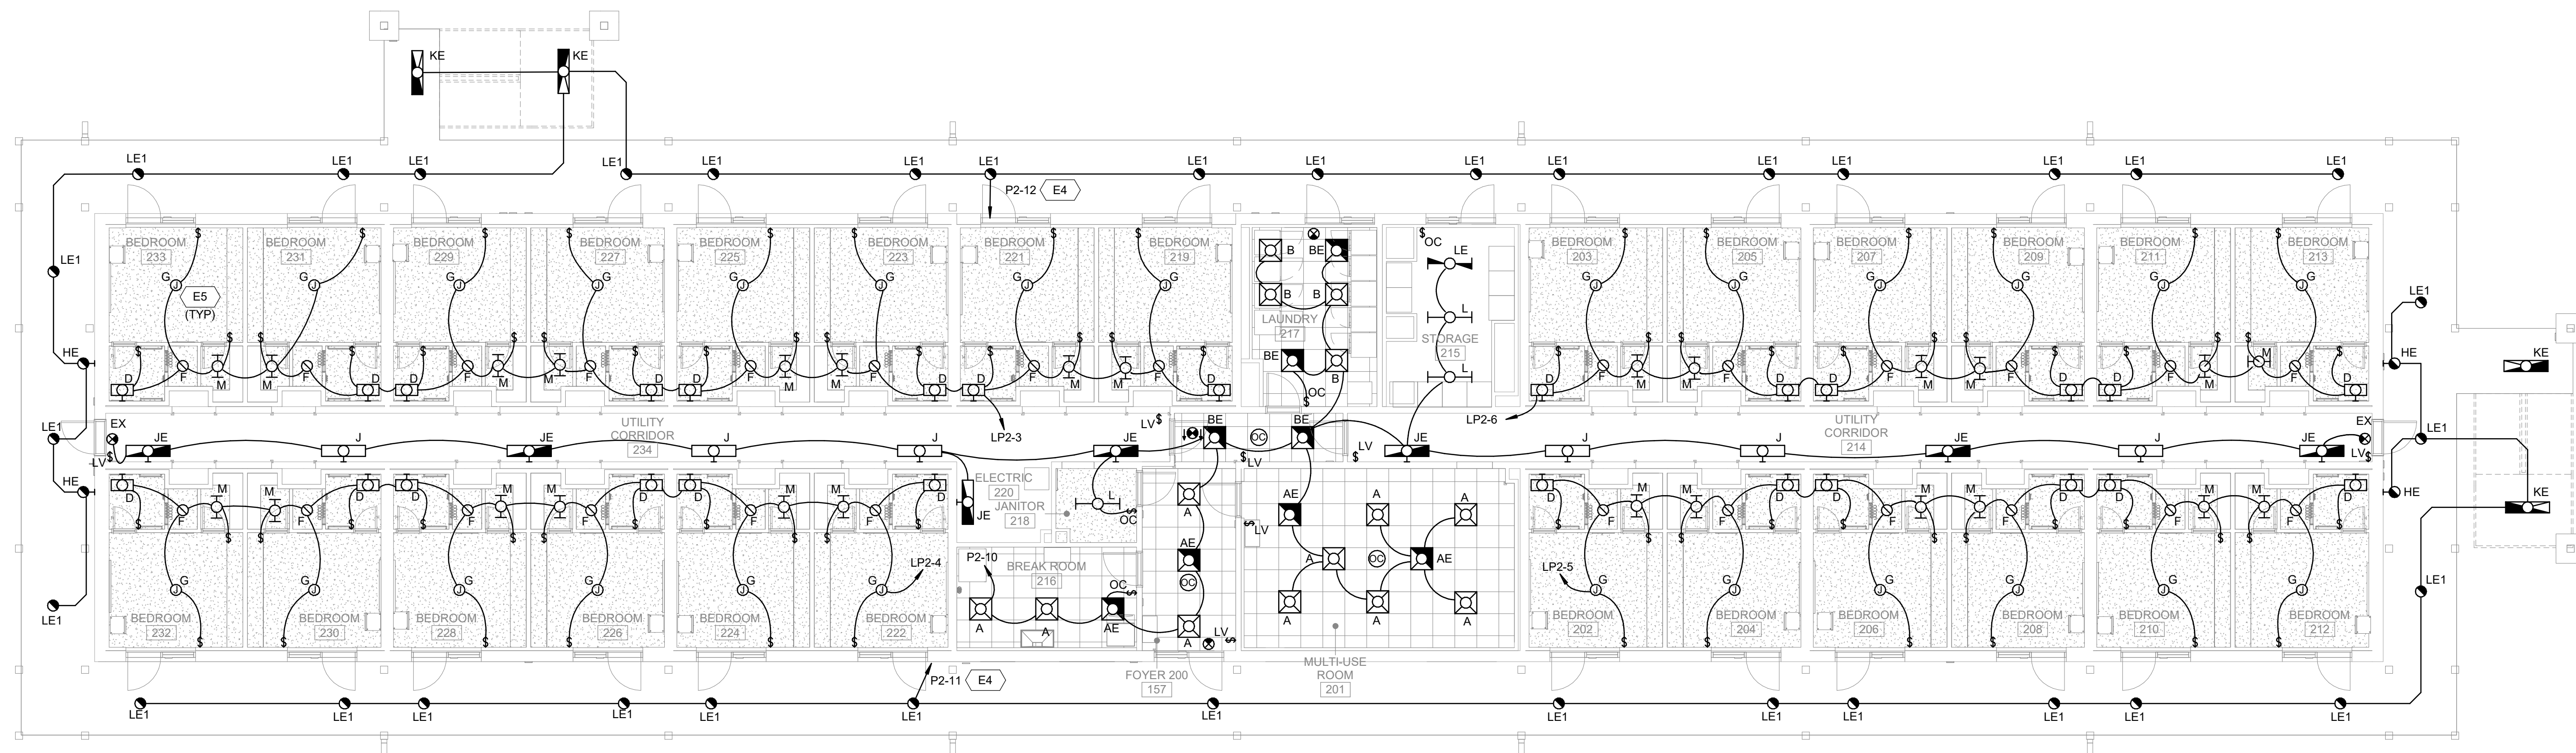

SCALE

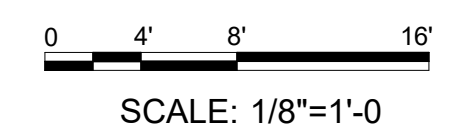

DATE: JULY 2026 DESIGNED
BY: JLS DRAWN
BY: MUC BUILDING
NO.:
PROJECT
NO.:
SHEET
REF.:
E-202
SHEET
NO.: