
 


THIRD FLOOR SIGNAGE SCHEDULE									
RM #	SIGN TYPE	ROOM	MESSAGE TEXT	QTY	RM #	SIGN TYPE	ROOM	MESSAGE TEXT	QTY
300	P2, EX1	FOYER	FOYER	1	320	P1	ELECTRICAL	ELECTRICAL	1
301	P1	DAY ROOM	MULTI-USE ROOM	1	321	P3	BEDROOM	INSERT PROVIDED BY END USER	1
302	P3	BEDROOM	INSERT PROVIDED BY END USER	1	322	P3	BEDROOM	INSERT PROVIDED BY END USER	1
303	P3	BEDROOM	INSERT PROVIDED BY END USER	1	323	P3	BEDROOM	INSERT PROVIDED BY END USER	1
304	P3	BEDROOM	INSERT PROVIDED BY END USER	1	324	P3	BEDROOM	INSERT PROVIDED BY END USER	1
305	P3	BEDROOM	INSERT PROVIDED BY END USER	1	325	P3	BEDROOM	INSERT PROVIDED BY END USER	1
306	P3	BEDROOM	INSERT PROVIDED BY END USER	1	326	P3	BEDROOM	INSERT PROVIDED BY END USER	1
307	P3	BEDROOM	INSERT PROVIDED BY END USER	1	327	P3	BEDROOM	INSERT PROVIDED BY END USER	1
308	P3	BEDROOM	INSERT PROVIDED BY END USER	1	328	P3	BEDROOM	INSERT PROVIDED BY END USER	1
309	P3	BEDROOM	INSERT PROVIDED BY END USER	1	329	P3	BEDROOM	INSERT PROVIDED BY END USER	1
310	P3	BEDROOM	INSERT PROVIDED BY END USER	1	330	P3	BEDROOM	INSERT PROVIDED BY END USER	1
311	P3	BEDROOM	INSERT PROVIDED BY END USER	1	331	P3	BEDROOM	INSERT PROVIDED BY END USER	1
312	P3	BEDROOM	INSERT PROVIDED BY END USER	1	332	P3	BEDROOM	INSERT PROVIDED BY END USER	1
313	P3	BEDROOM	INSERT PROVIDED BY END USER	1	333	P3	BEDROOM	INSERT PROVIDED BY END USER	1
314	P1, P2	UTILITY CORRIDOR	UTILITY CORRIDOR	1, 1	334	P1, P2	UTILITY CORRIDOR	UTILITY CORRIDOR	1, 1
315	P2	STORAGE	STORAGE	1	ADDITIONAL SIGNAGE				
316	O	OFFICE	INSERT PROVIDED BY END USER	1		EX1	STAIR EXIT SIGNAGE		2
317	P1, P2	LAUNDRY	LAUNDRY	1, 1		EX2	DIRECTIONAL EXIT SIGNAGE		3
318	P1	JANITOR	JANITORIAL	1		NS	*NO SMOKING WITHIN 25 FEET OF ENTRANCE		8
319	P3	BEDROOM	INSERT PROVIDED BY END USER	1		S1	TACTILE STAIRWAY LEVEL 3		2
						DS	DIRECTIONAL SIGNAGE		2
NOTE : ALL SIGNAGE MUST COMPLY WITH ABA, ADA AND / OR TSA REQUIREMENTS AS WELL AS BASE STANDARDS. COLORS = ARCHITECTURAL BROWN A44 BACKGROUND WITH WHITE REFLECTIVE TEXT.									

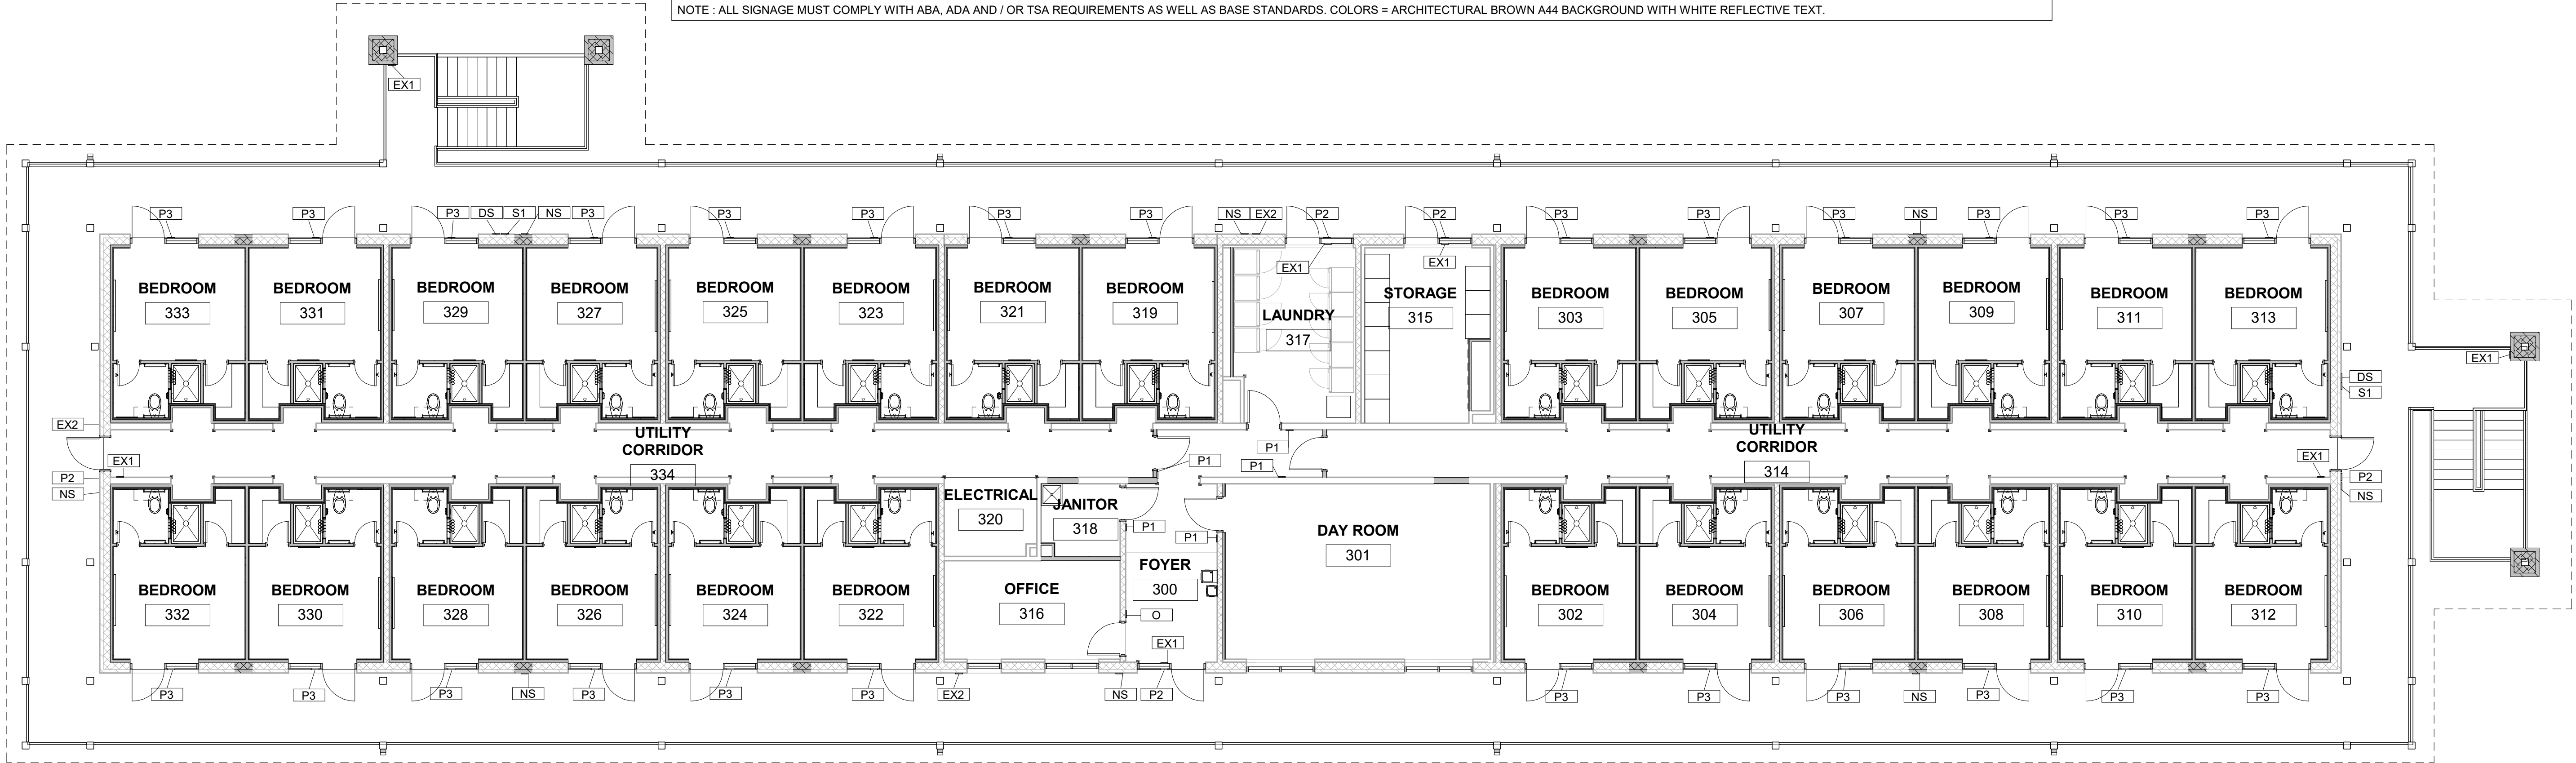

1 LEVEL THREE FLOOR PLAN
SCALE: 1/8" = 1'-0"

SCALE



APPROVED	CHIEF ENGINEER	APPROVED	CIVIL ENGINEER
NKAK 22-1076 B718 DORM LITTLE ROCK AFB			
DETAILS (1)			
LEVEL THREE SIGNAGE PLAN			
AIR MOBILITY COMMAND 19TH CIVIL ENGINEER SQUADRON LITTLE ROCK, ARKANSAS			
DATE: JULY 2026 DESIGNED BY: ABV DRAWN BY: TAH BUILDING NO.: PROJECT NO.: SHEET REF.: I-113 SHEET NO.: 1 OF XX			
STATUS: 65% PRELIMINARY DESIGN			