




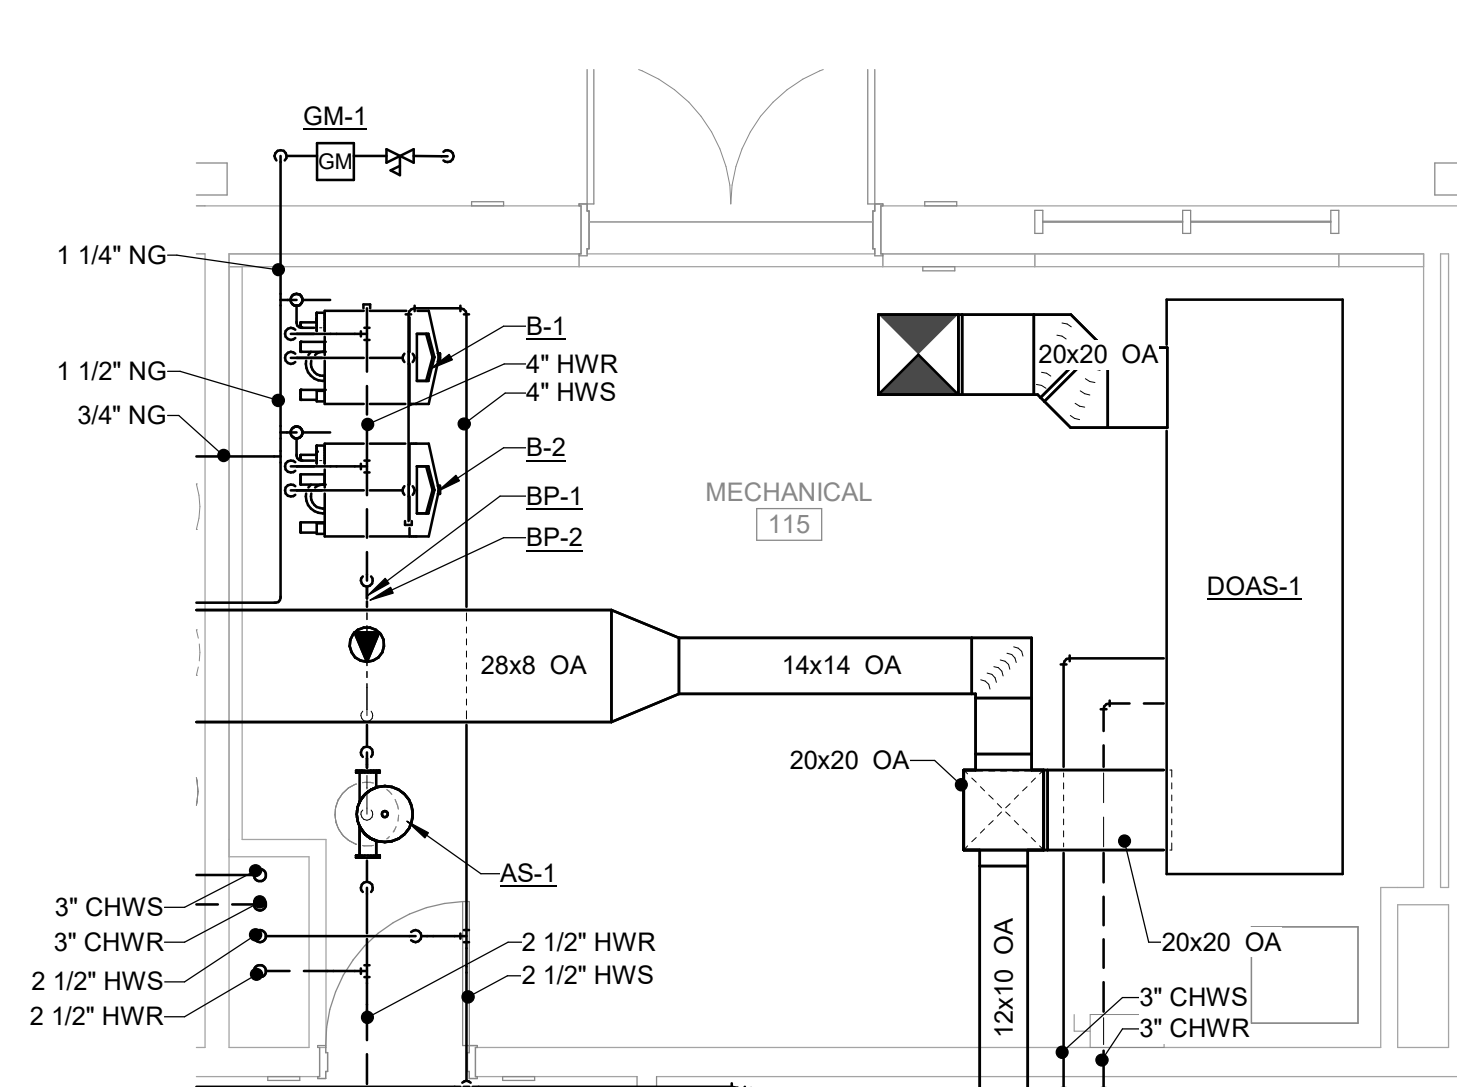

  **ENLARGED MECHANICAL ROOM PLAN**
SCALE: 1/4" = 1'-0"

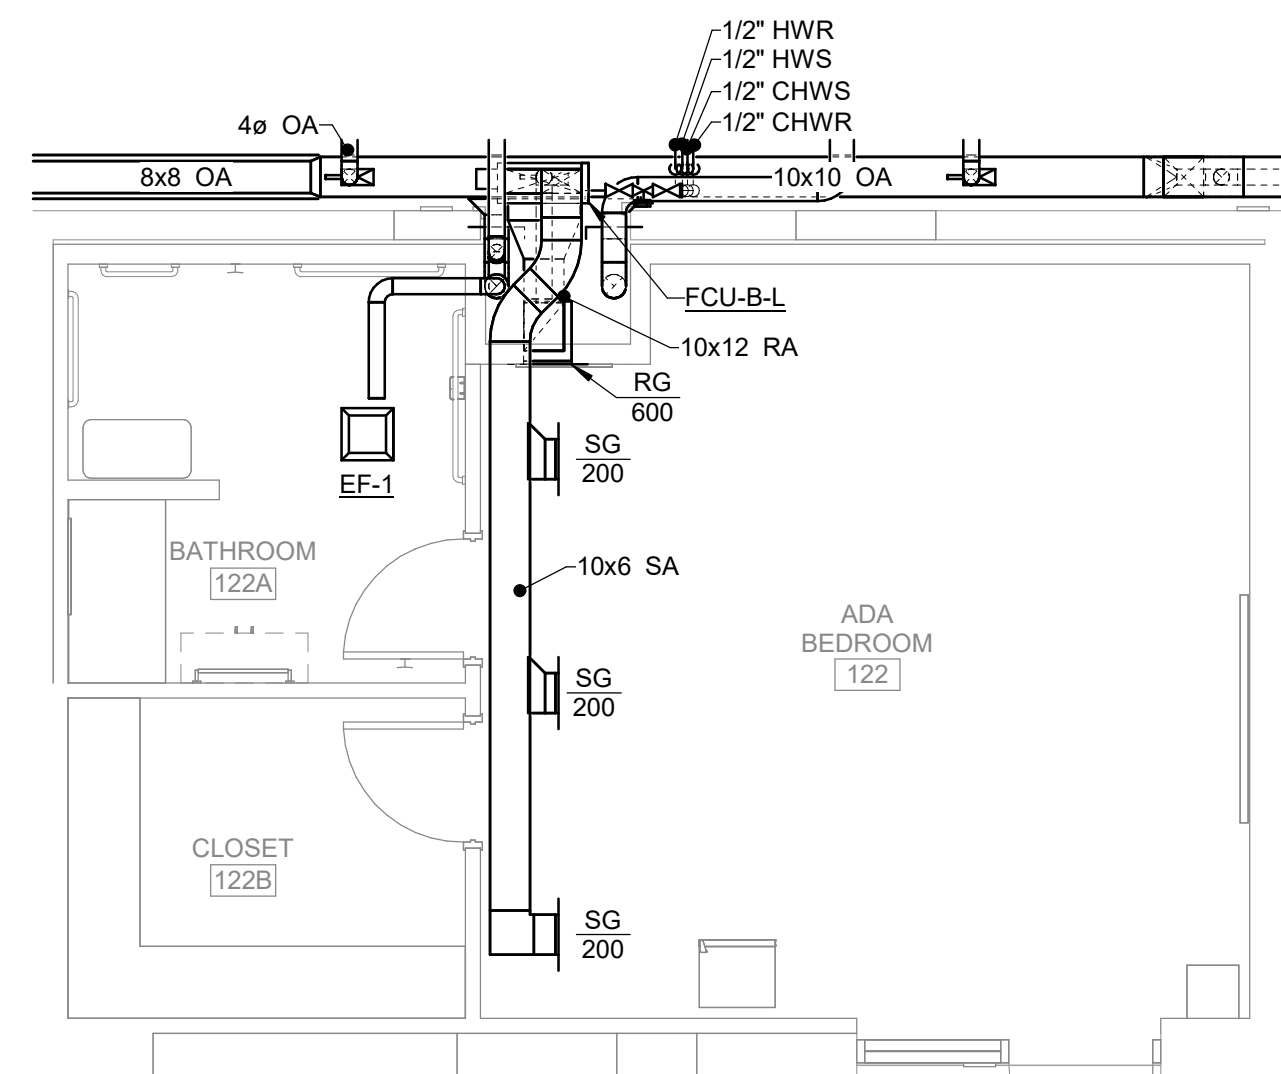

  **ENLARGED ADA BEDROOM PLAN**
SCALE: 1/4" = 1'-0"

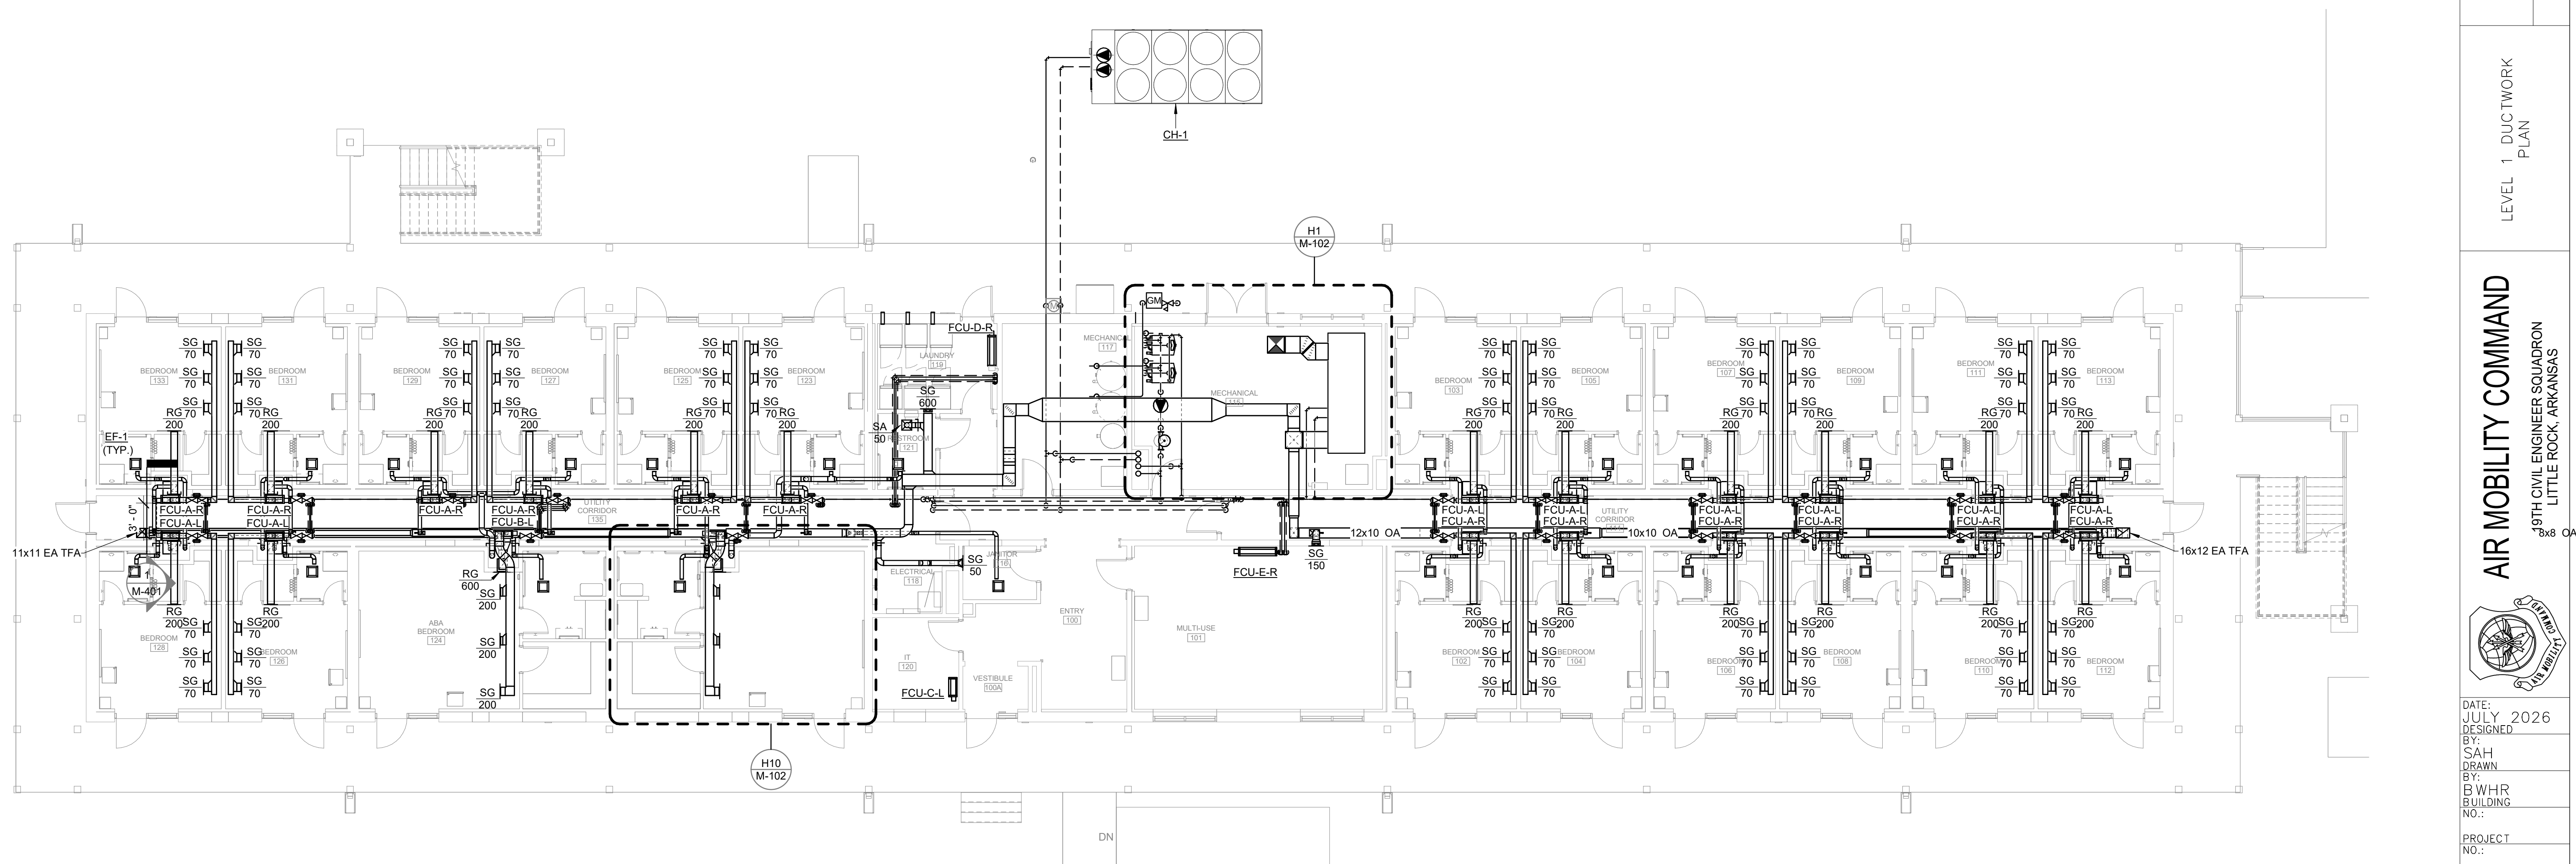

 **LEVEL 1 MECHANICAL DUCTWORK PLAN**
SCALE: 1/8" = 1'-0"

SCALE



AIR MOBILITY COMMAND
19TH CIVIL ENGINEER SQUADRON
LITTLE ROCK, ARKANSAS
8x8

DATE: JULY 2026
DESIGNED BY: SAH
DRAWN BY: BWHR
BUILDING NO.:
PROJECT NO.:
SHEET REF.:
M-102
SHEET NO.: 1 OF XX

STATUS:65% PRELIMINARY DESIGN