



LITTLE ROCK
ARKANSAS

ARCHITECT:

CONSULTANTS:

Project Status
**NOT FOR
CONSTRUCTION**

No.	Revision/Issue	Date	BY	APP'D


PROJECT TITLE
CCR For Repair Airmen
Dormitory B718

SHEET TITLE
**PROPOSED MECHANICAL
FIRST FLOOR PLAN**

TECH REVIEWER	PROJECT NUMBER NKAK 22-1076
DESIGNED BY	SHEET M101
DATE 07-17-2025	29 OF 33
SCALE 1/8" = 1'-0"	

GENERAL NOTES

1. INFORMATION SHOWN IS A CONCEPTUAL LAYOUT FOR REFERENCE ONLY TO AID PRICING EFFORTS, AND IS NOT TO BE USED AS A CONSTRUCTION DOCUMENT.
2. DESIGN - BUILD CONTRACTOR IS ULTIMATELY RESPONSIBLE FOR A CREATING A FINISHED DESIGN, COMPLETE SET OF CONSTRUCTION DOCUMENTS, AND PROVIDING A COMPLETE AND FUNCTIONAL FACILITY TO THE GOVERNMENT.
3. CONTRACTOR IS RESPONSIBLE FOR COMPLYING WITH ALL APPLICABLE LOCAL CODES, MILITARY UFCS, AIR FORCE DESIGN GUIDES, AND OTHER CRITERIA REFERENCED IN THE RFP.

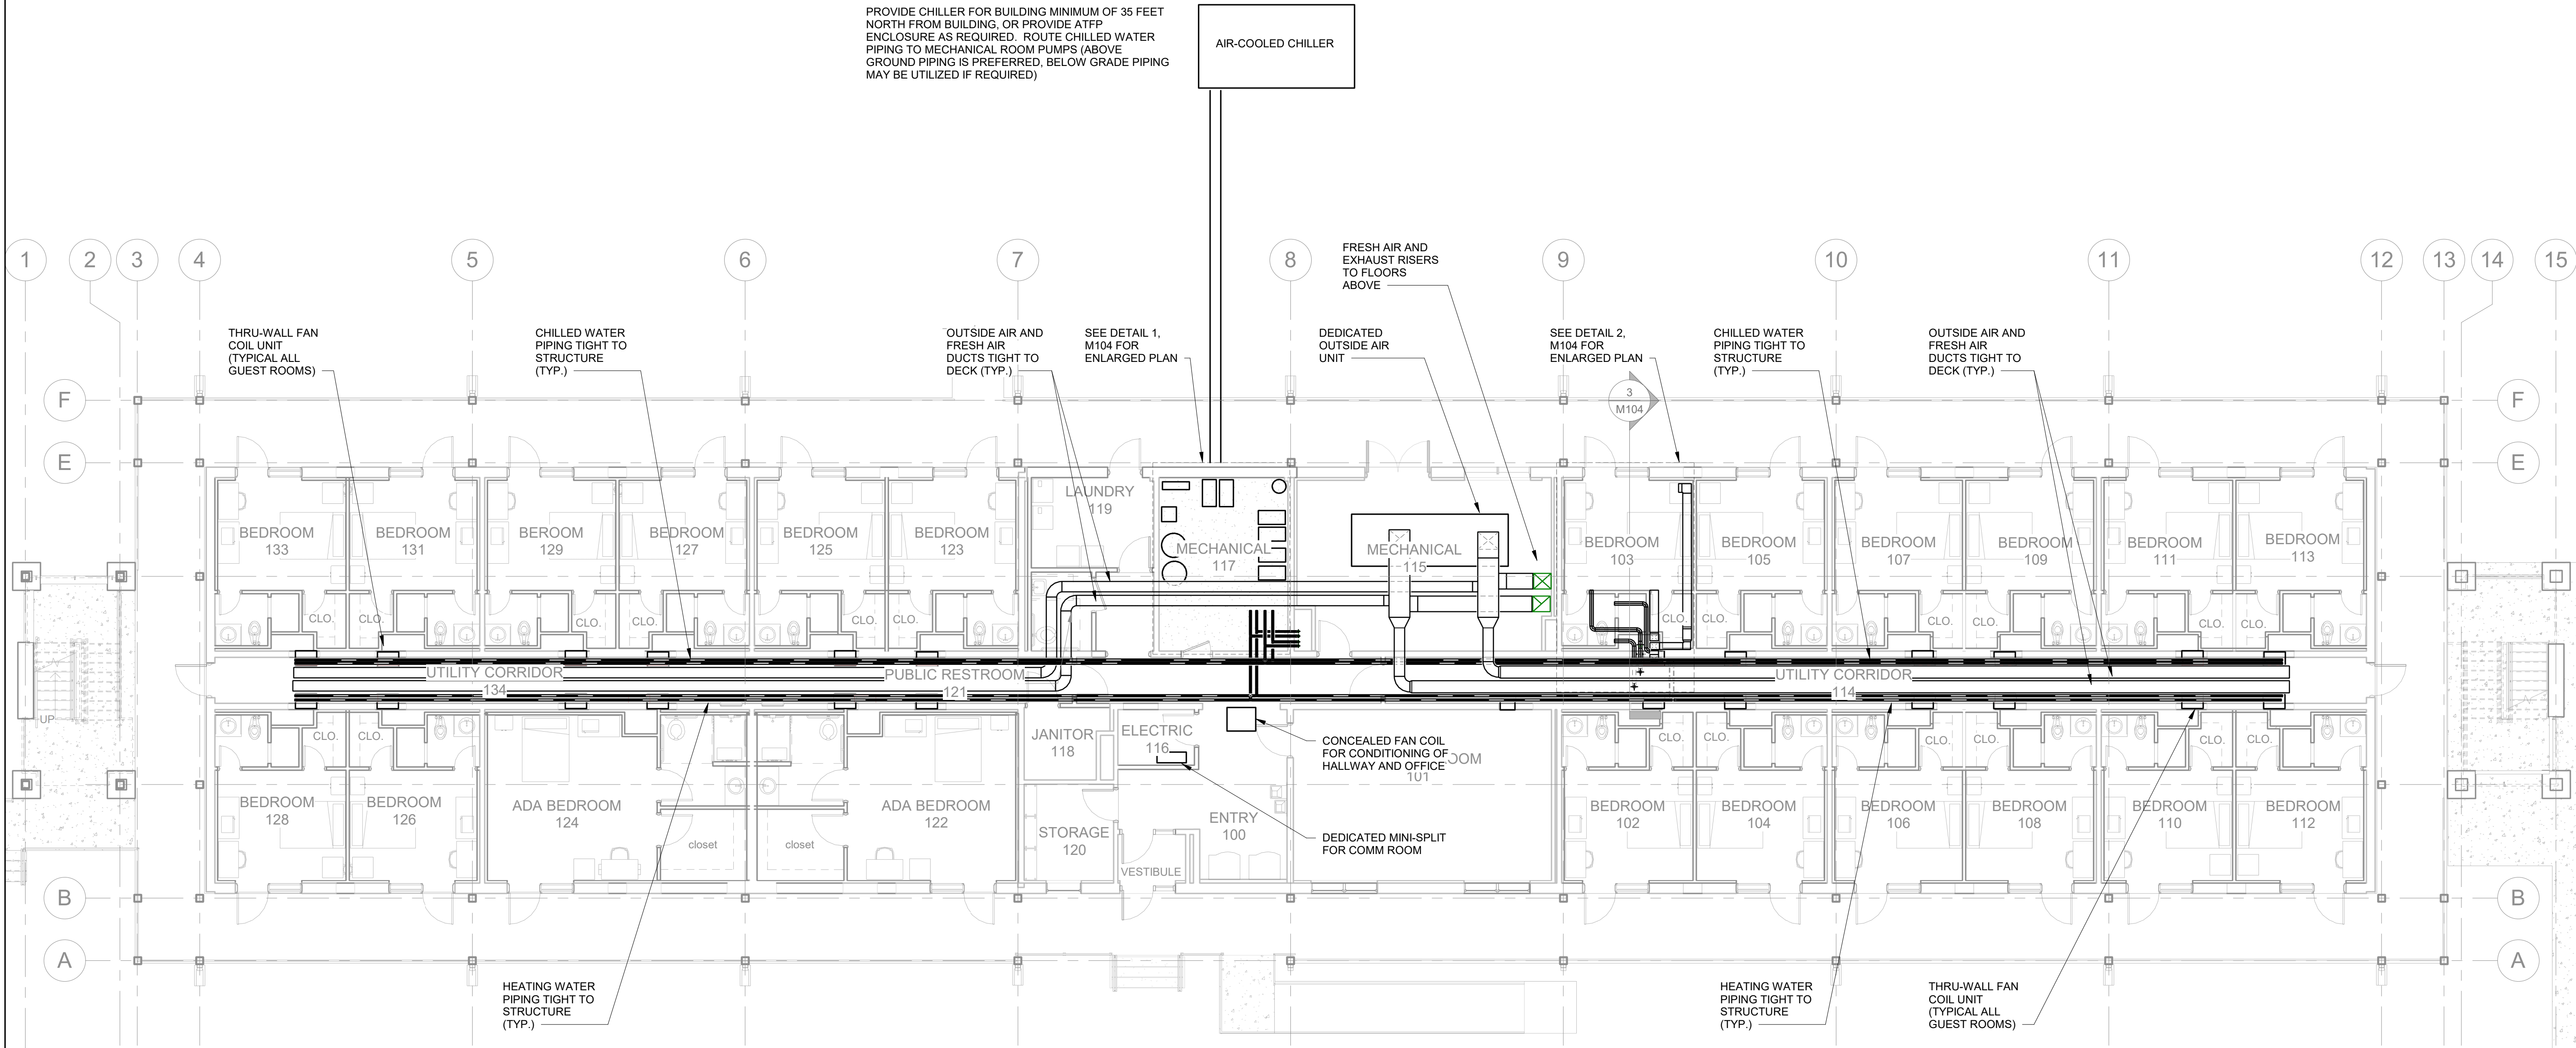

1 MECHANICAL FIRST FLOOR PLAN
1/8" = 1'-0"

