




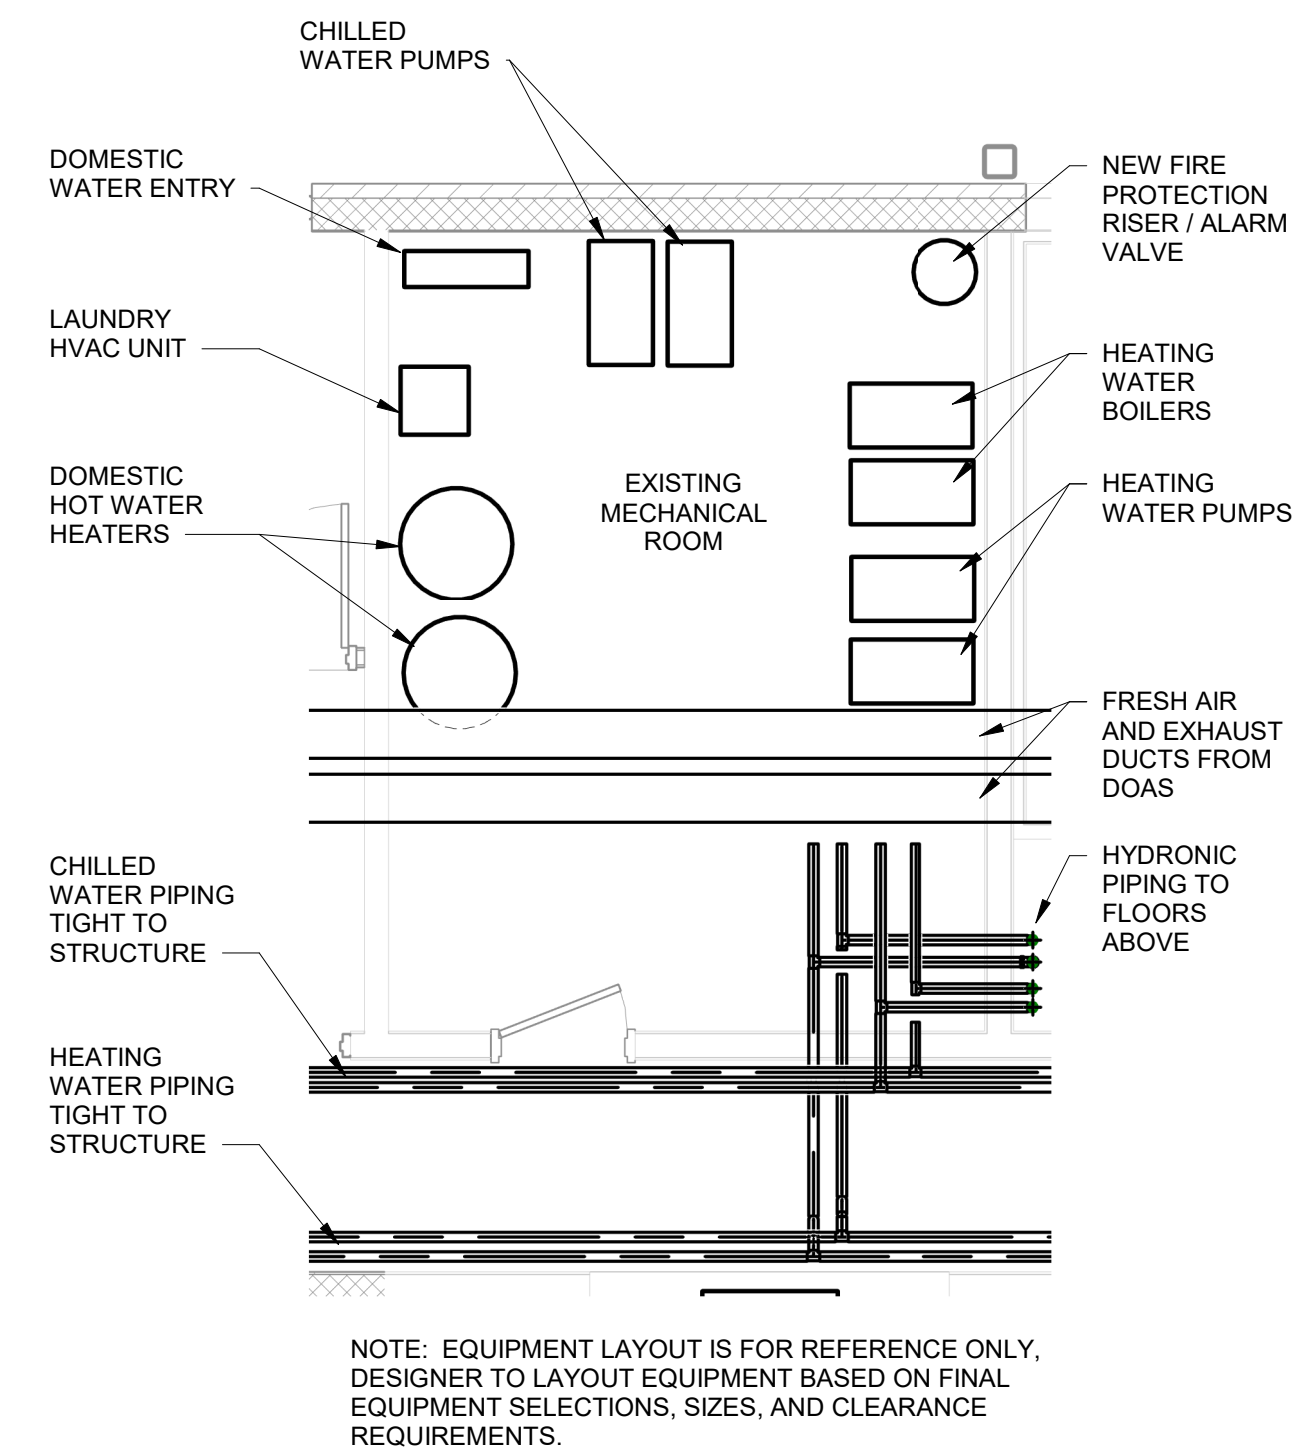

1 ENLARGED MECHANICAL ROOM PLAN
1/4" = 1'-0"

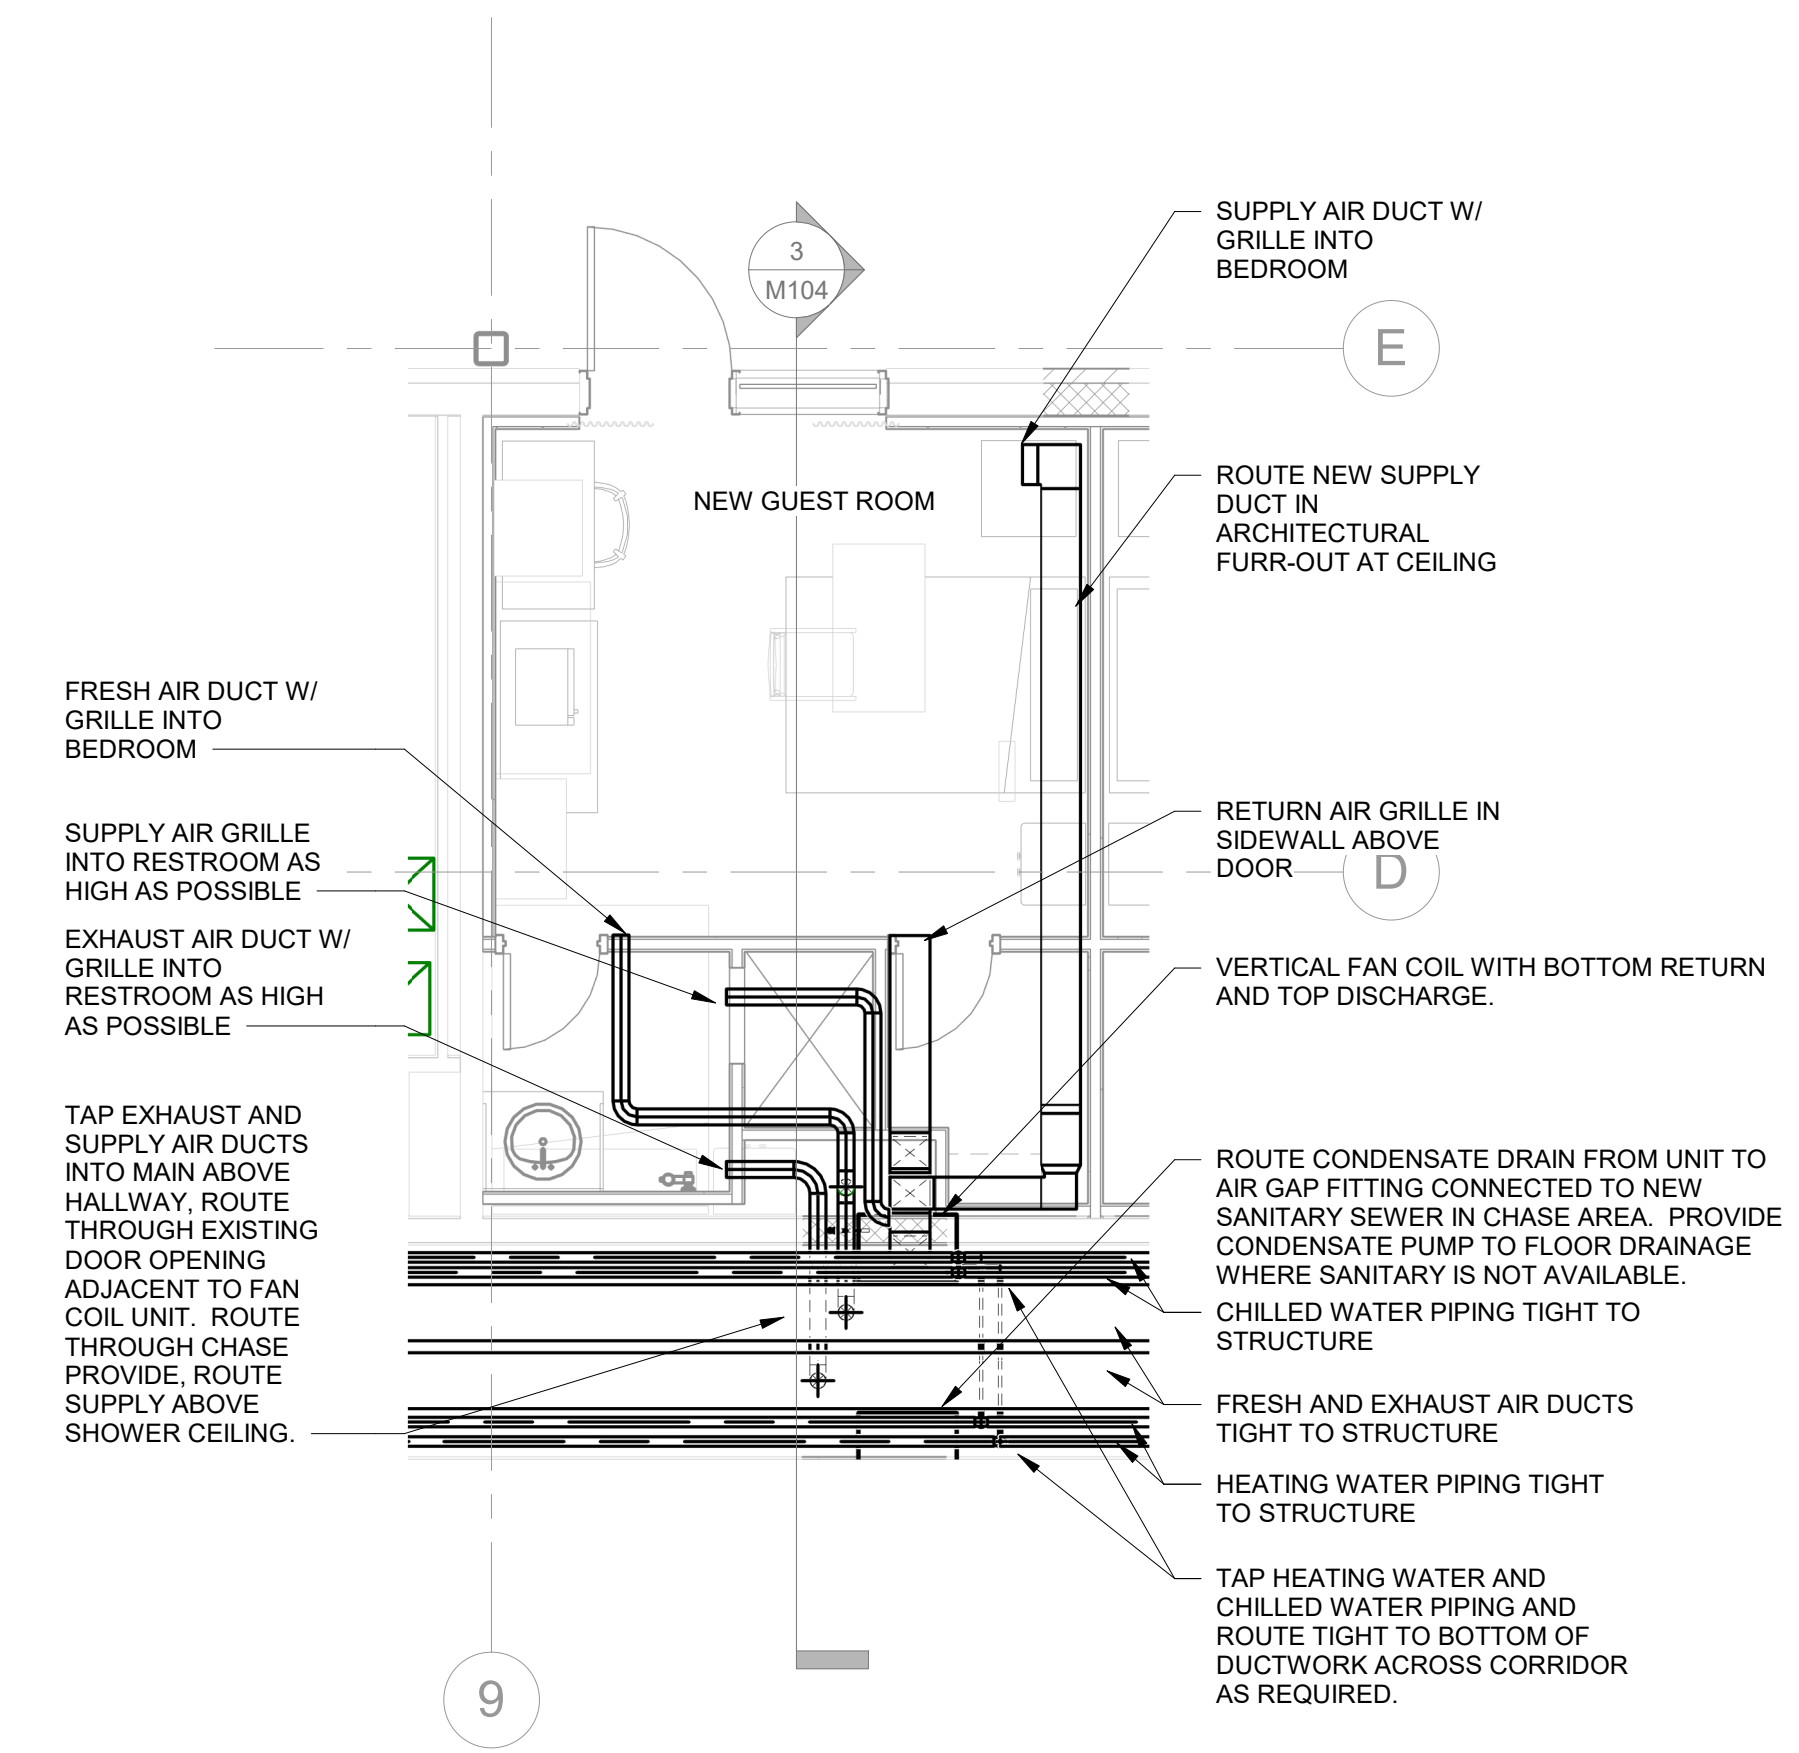

2 ENLARGED BEDROOM MECHANICAL PLAN
1/4" = 1'-0"

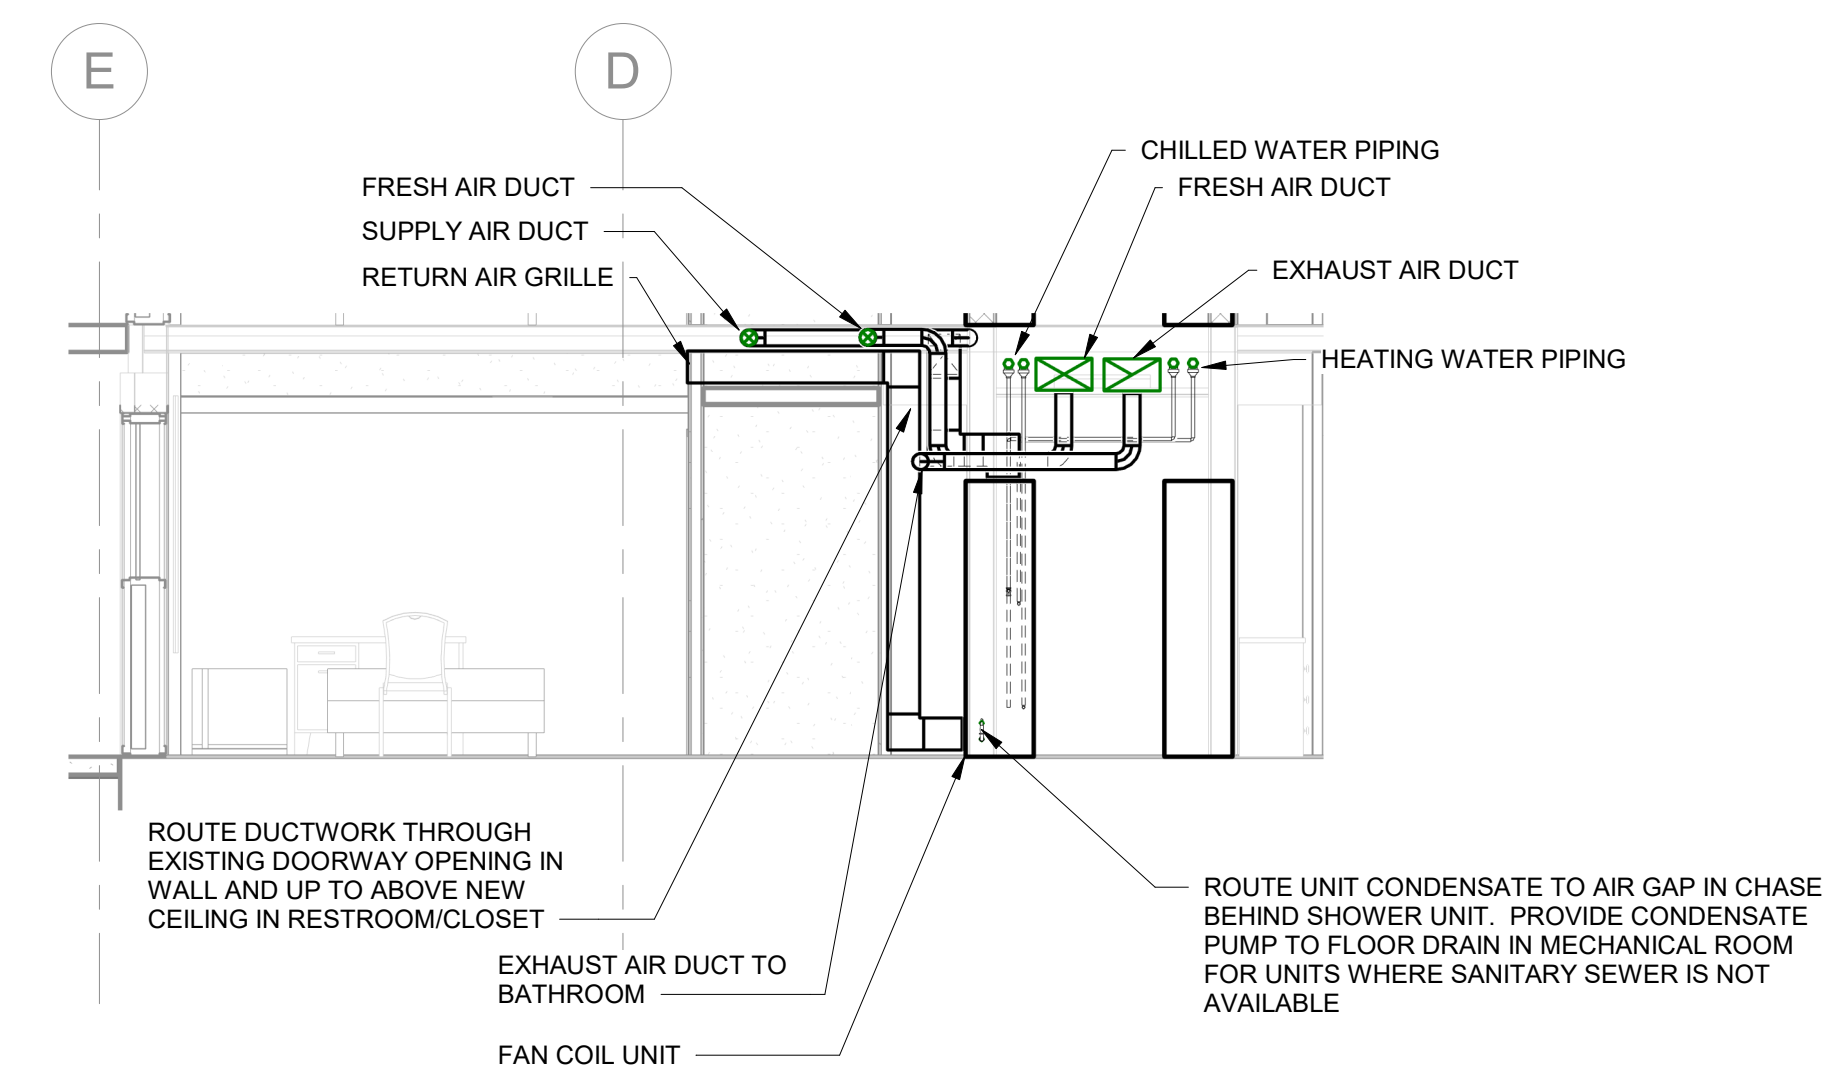

3 MECHANICAL SECTION AT BEDROOM (TYPICAL)
1/4" = 1'-0"

GENERAL NOTES

1. INFORMATION SHOWN IS A CONCEPTUAL LAYOUT FOR REFERENCE ONLY TO AID PRICING EFFORTS, AND IS NOT TO BE USED AS A CONSTRUCTION DOCUMENT.
2. DESIGN - BUILD CONTRACTOR IS ULTIMATELY RESPONSIBLE FOR A CREATING A FINISHED DESIGN, COMPLETE SET OF CONSTRUCTION DOCUMENTS, AND PROVIDING A COMPLETE AND FUNCTIONAL FACILITY TO THE GOVERNMENT.
3. CONTRACTOR IS RESPONSIBLE FOR COMPLYING WITH ALL APPLICABLE LOCAL CODES, MILITARY UFCS, AIR FORCE DESIGN GUIDES, AND OTHER CRITERIA REFERENCED IN THE RFP.



LITTLE ROCK
ARKANSAS

ARCHITECT:

CONSULTANTS:

Project Status
**NOT FOR
CONSTRUCTION**

No.	Revision/Issue	Date	BY	APP'D

PROJECT TITLE CCR For Repair Airmen Dormitory B718	SHEET TITLE PROPOSED MECHANICAL ENLARGED PLANS	DRAWN BY	LEAD DESIGNER
		TECH REVIEWER	PROJECT NUMBER NKAK 22-1076
		DESIGNED BY	SHEET
		DATE 07-17-2025	M104
		SCALE 1/4" = 1'-0"	