
 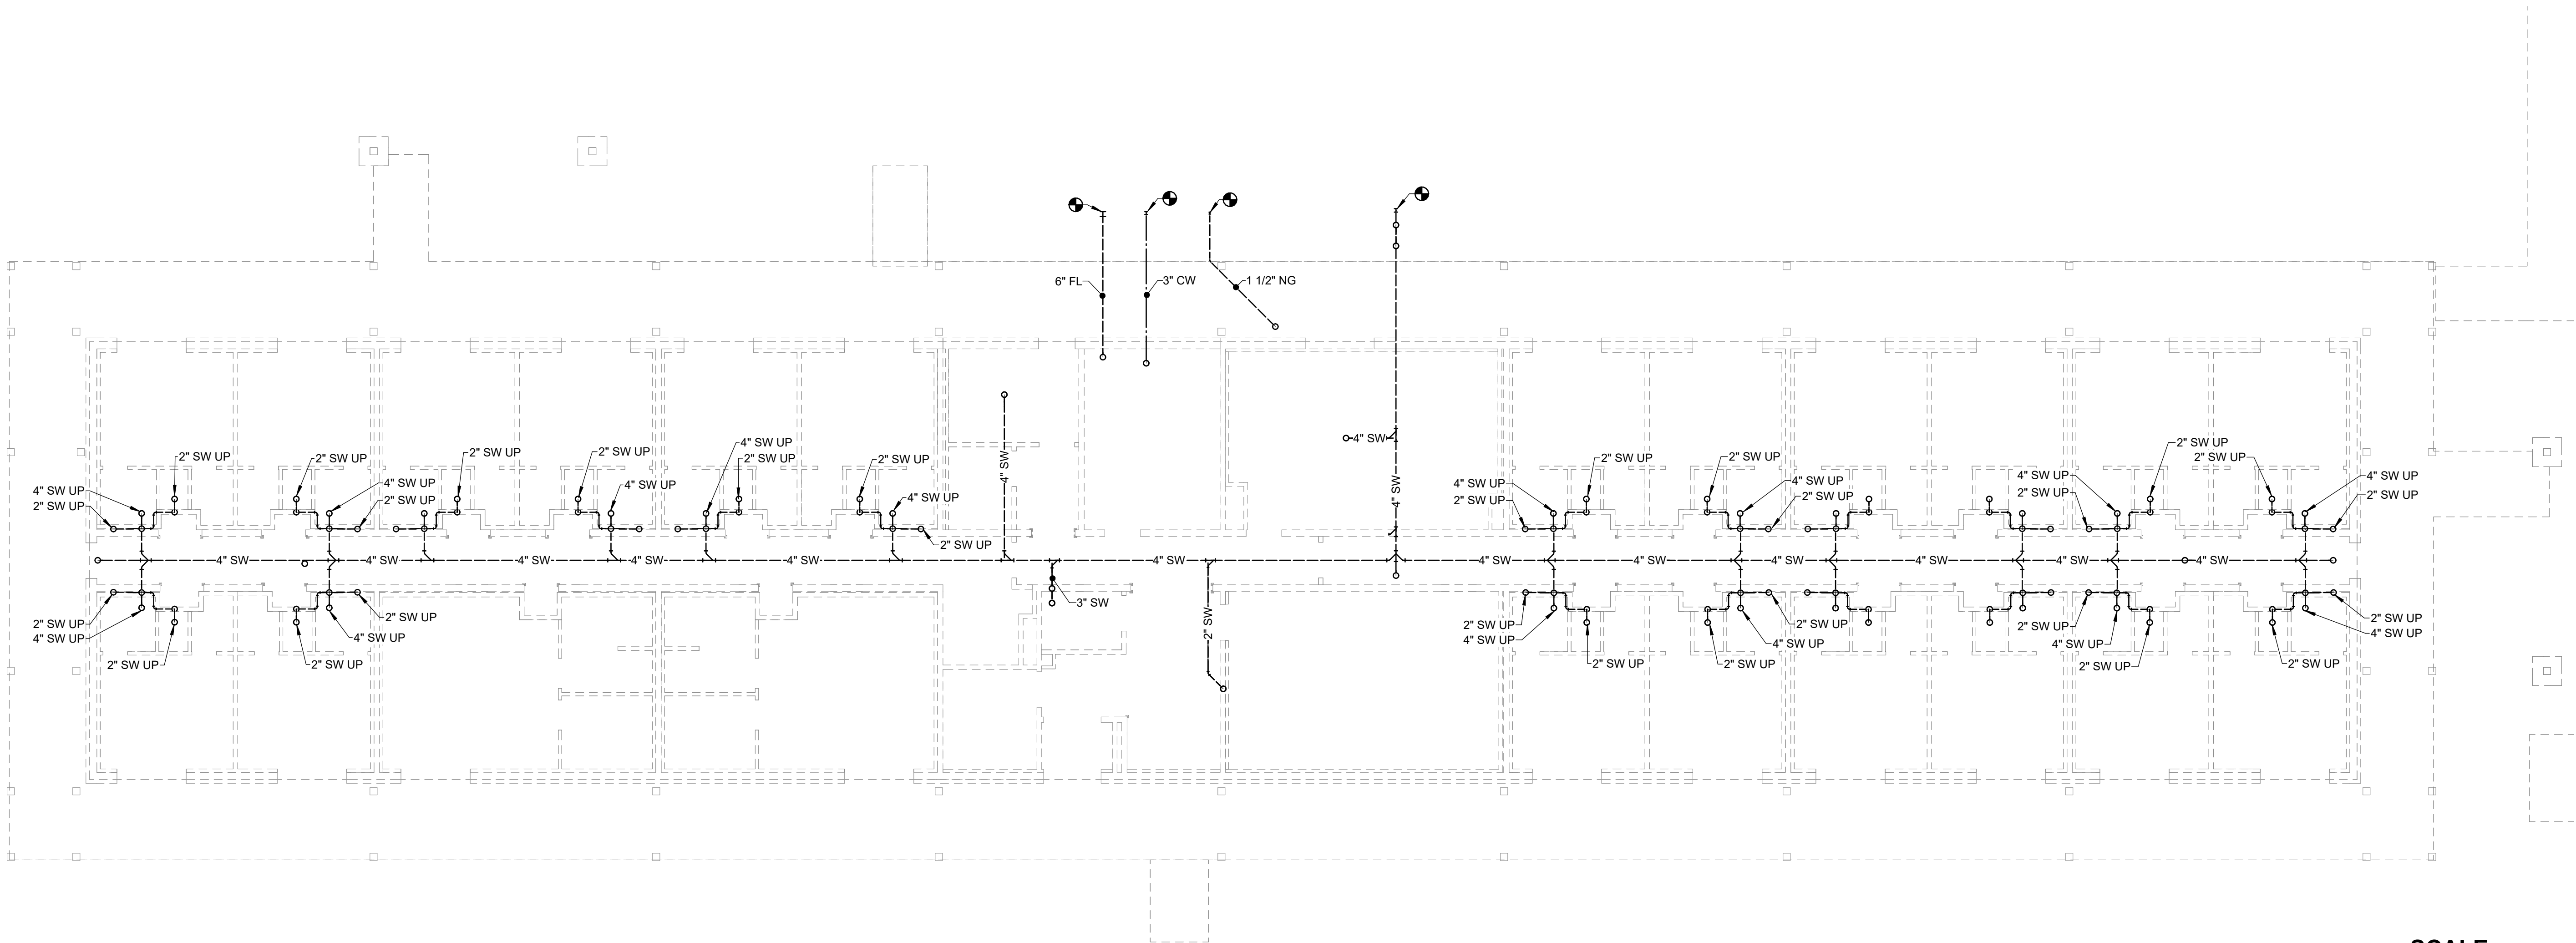


A1

BELOW GRADE PLUMBING PLAN

SCALE: 1/8" = 1'-0"

 
SCALE



SCALE: 1/8"=1'-0

GENERAL SHEET NOTES

1. DASHED (LONG) LINES SHOWN ON THIS SHEET INDICATE PIPE BELOW GRADE.
2. DASHED (SHORT) GREYSCALE LINES SHOWN ON THIS SHEET INDICATE WALLS ON FLOOR ABOVE AND STRUCTURAL MEMBERS BELOW GRADE AND ARE FOR REFERENCE ONLY.
3. REFER TO DOMESTIC WATER 3D PLUMBING RISER DIAGRAMS FOR MORE INFORMATION.
4. REFER TO GAS 3D PLUMBING RISER DIAGRAMS FOR MORE INFORMATION.
5. REFER TO SANITARY WASTE AND VENT 3D PLUMBING RISER DIAGRAMS FOR MORE INFORMATION.
6. COORDINATE ALL FLOOR PENETRATIONS WITH STRUCTURAL MEMBERS.
7. COORDINATE ALL WALL MOUNTED CLEANOUTS WITH BATHROOM ELEVATIONS. REFER TO ARCHITECTURAL ELEVATIONS FOR FINISH DETAILS.

 AIR MOBILITY COMMAND 19TH CIVIL ENGINEER SQUADRON LITTLE ROCK, ARKANSAS					BELOW GRADE PLUMBING PLAN		NKAK 22-1076 B718 DORM LITTLE ROCK AFB		APPROVED	REV #	DATE	DESCRIPTION	APP'D
					APPROVED		CHIEF ENGINEER						
					APPROVED								
					CIVIL ENGINEER								
DETAILS (1)													
DATE: JULY 2026 DESIGNED BY: SAH DRAWN BY: GAM BUILDING NO.: PROJECT NO.: SHEET REF.: - P-100 SHEET NO.: 1 OF XX													