


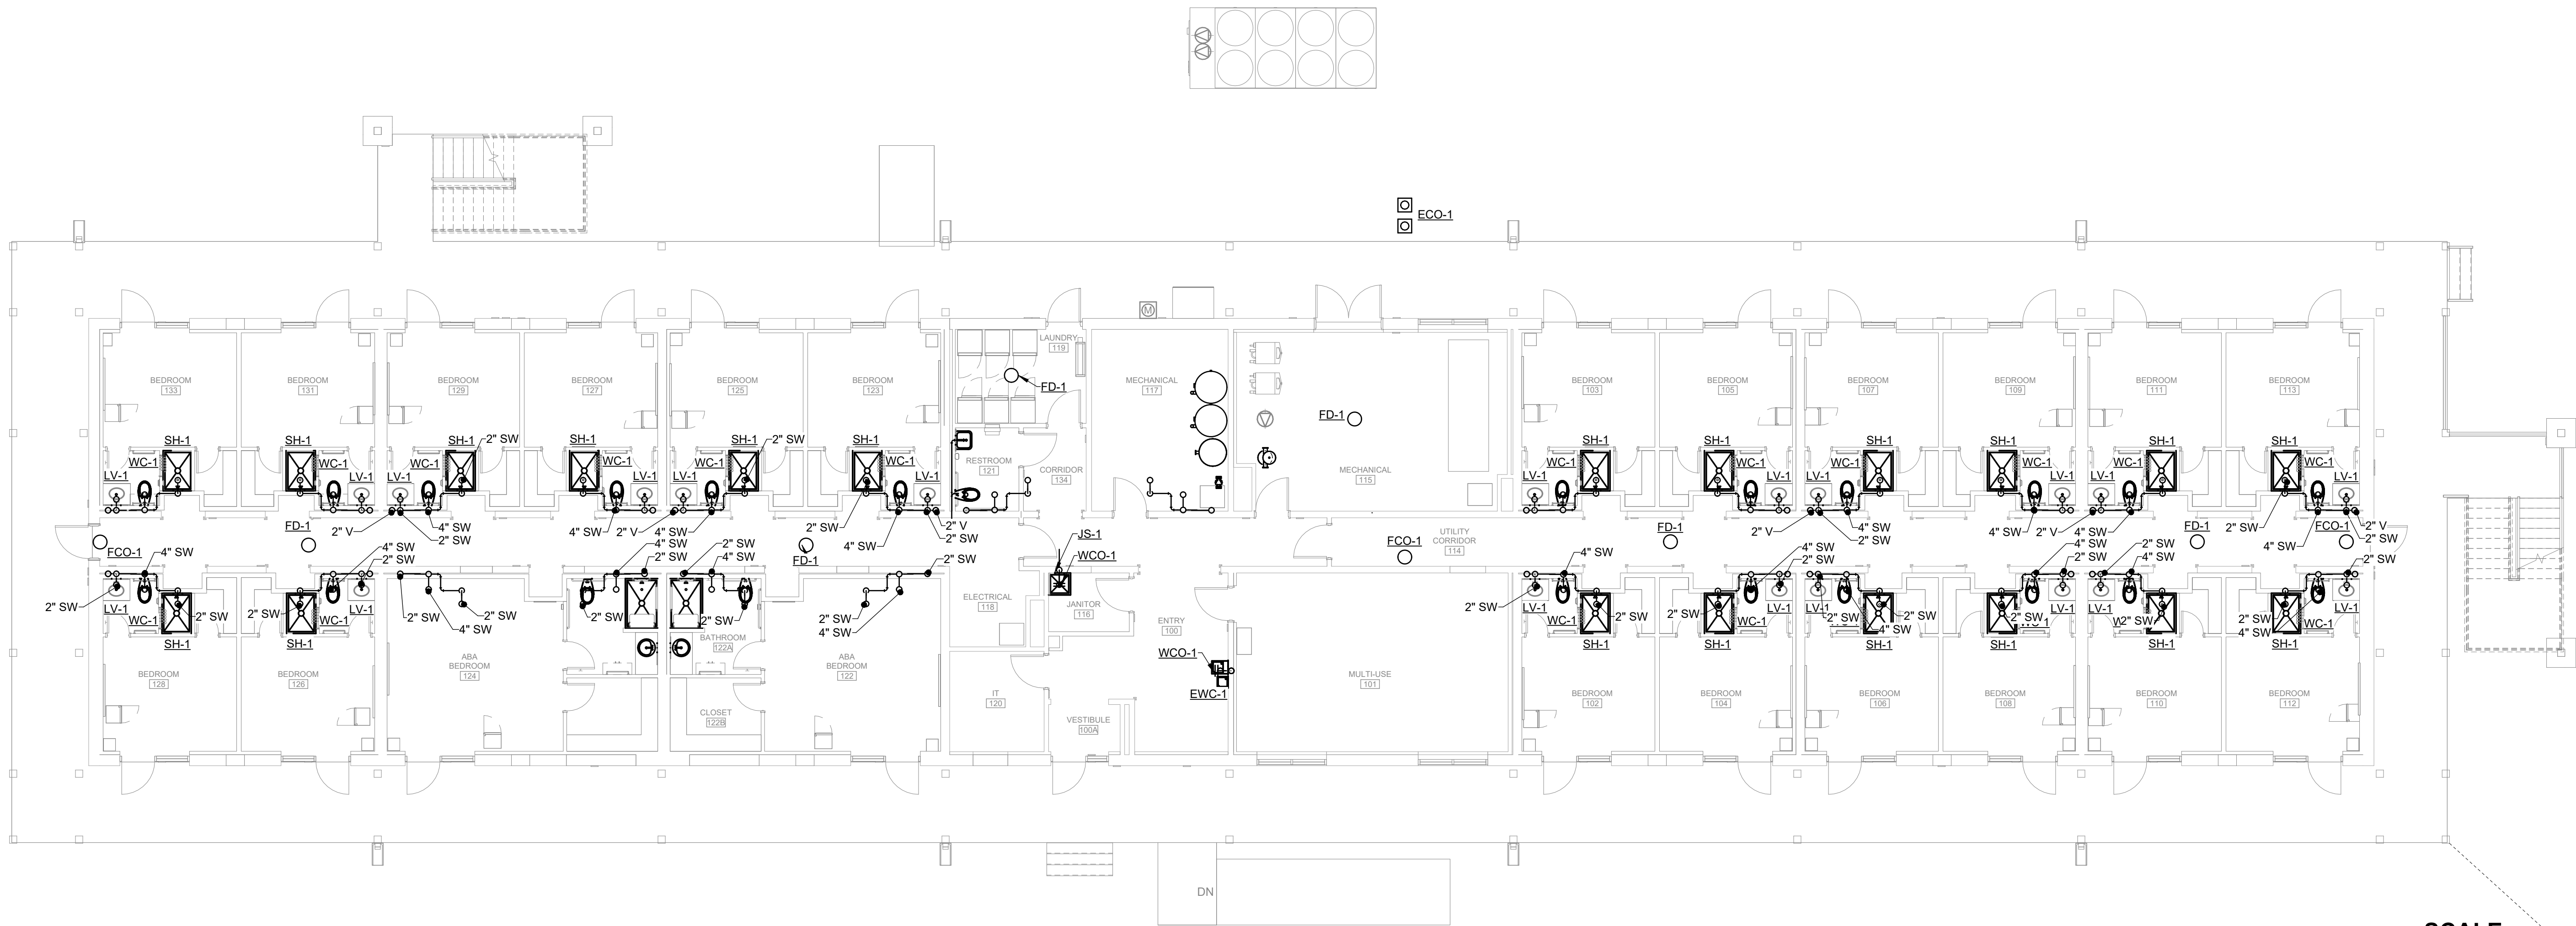

GENERAL SHEET NOTES


1. REFER TO SANITARY WASTE AND VENT 3D PLUMBING RISER DIAGRAMS FOR MORE INFORMATION.
2. REFER TO GREASE WASTE AND VENT 3D PLUMBING RISER DIAGRAMS FOR MORE INFORMATION.
3. RESTROOM VENT PIPES SHOWN ON THIS PLAN ARE SCHEMATIC. AT CONTRACTOR'S OPTION, ROUTE PIPE IN WALL BEHIND PLUMBING FIXTURES AS REQUIRED.
4. COORDINATE ALL FLOOR PENETRATIONS WITH STRUCTURAL MEMBERS.
5. COORDINATE ALL WALL MOUNTED CLEANOUTS WITH BATHROOM ELEVATIONS. REFER TO ARCHITECTURAL ELEVATIONS FOR FINISH DETAILS.

APP'D	DESCRIPTION	DATE	REV #	APPROVED
				CHIEF ENGINEER
				APPROVED
				CIVIL ENGINEER

NKAK 22-1076
B718 DORM
LITTLE ROCK AFB
DETAILS (1)


LEVEL 1 WASTE AND
VENT PLAN

AIR MOBILITY COMMAND
19TH CIVIL ENGINEER SQUADRON
LITTLE ROCK, ARKANSAS

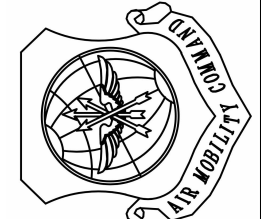

DATE: JULY 2026
DESIGNED BY: SAH
DRAWN BY: GAM
BUILDING NO.:
PROJECT NO.:
SHEET REF.:
P-201
SHEET NO.: 1 OF XX

STATUS:65% ISSUED FOR CONSTRUCTION

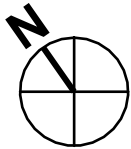

A1

LEVEL 1 WASTE AND VENT PLAN

SCALE: 1/8" = 1'-0"

SCALE

0 4' 8' 16'

SCALE: 1/8"=1'-0'