
 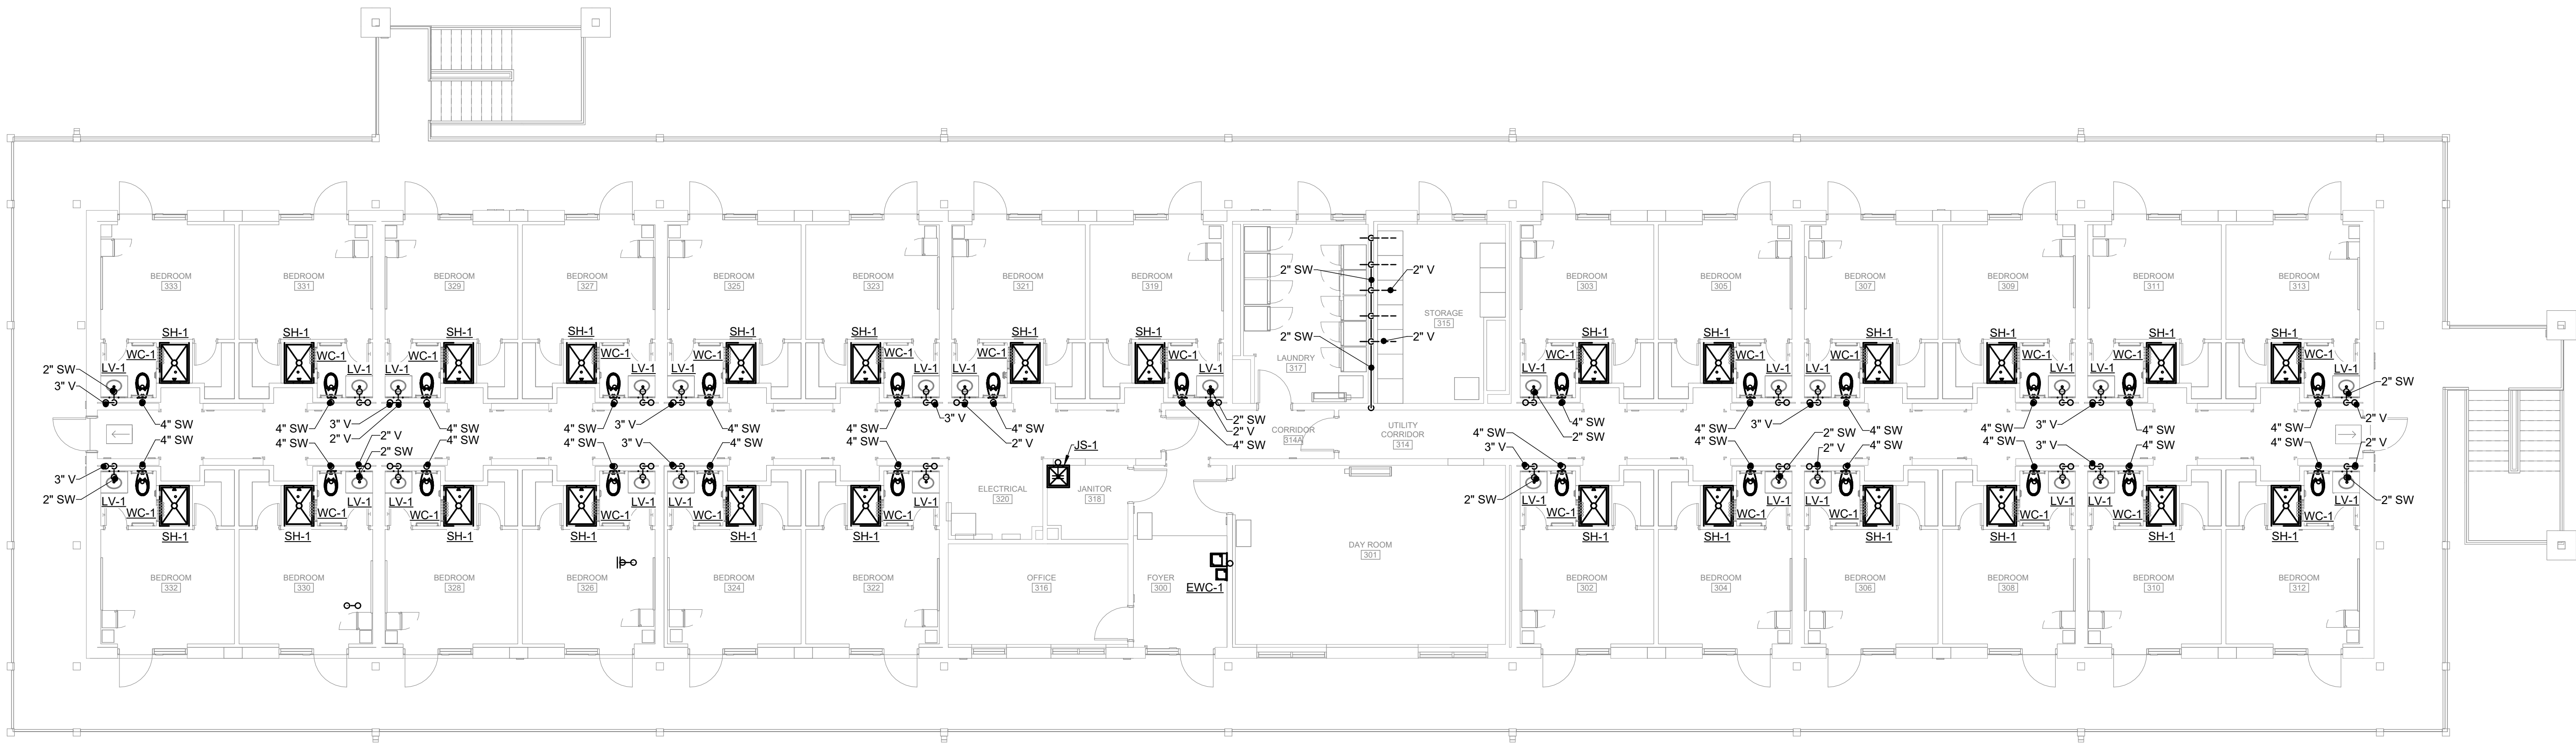


A1

LEVEL 3 WASTE AND VENT PLAN

SCALE: 1/8" = 1'-0"

SCALE



SCALE: 1/8"=1'-0

GENERAL SHEET NOTES

1. REFER TO SANITARY WASTE AND VENT 3D PLUMBING RISER DIAGRAMS FOR MORE INFORMATION.
2. REFER TO GREASE WASTE AND VENT 3D PLUMBING RISER DIAGRAMS FOR MORE INFORMATION.
3. RESTROOM VENT PIPES SHOWN ON THIS PLAN ARE SCHEMATIC. AT CONTRACTOR'S OPTION, ROUTE PIPE IN WALL BEHIND PLUMBING FIXTURES AS REQUIRED.
4. COORDINATE ALL FLOOR PENETRATIONS WITH STRUCTURAL MEMBERS.
5. COORDINATE ALL WALL MOUNTED CLEANOUTS WITH BATHROOM ELEVATIONS. REFER TO ARCHITECTURAL ELEVATIONS FOR FINISH DETAILS.

APP'D	DESCRIPTION	DATE	REV #	APPROVED	NKAK 22-1076 B718 DORM LITTLE ROCK AFB	LEVEL 3 WASTE AND VENT PLAN	AIR MOBILITY COMMAND 19TH CIVIL ENGINEER SQUADRON LITTLE ROCK, ARKANSAS	DATE: JULY 2026 DESIGNED BY: SAH DRAWN BY: GAM BUILDING NO.:	PROJECT NO.:	SHEET REF.:	P-203	SHEET NO.:	1 OF XX
				CHIEF ENGINEER APPROVED	DETAILS (1)								
				CIVIL ENGINEER									

STATUS:65% ISSUED FOR CONSTRUCTION