


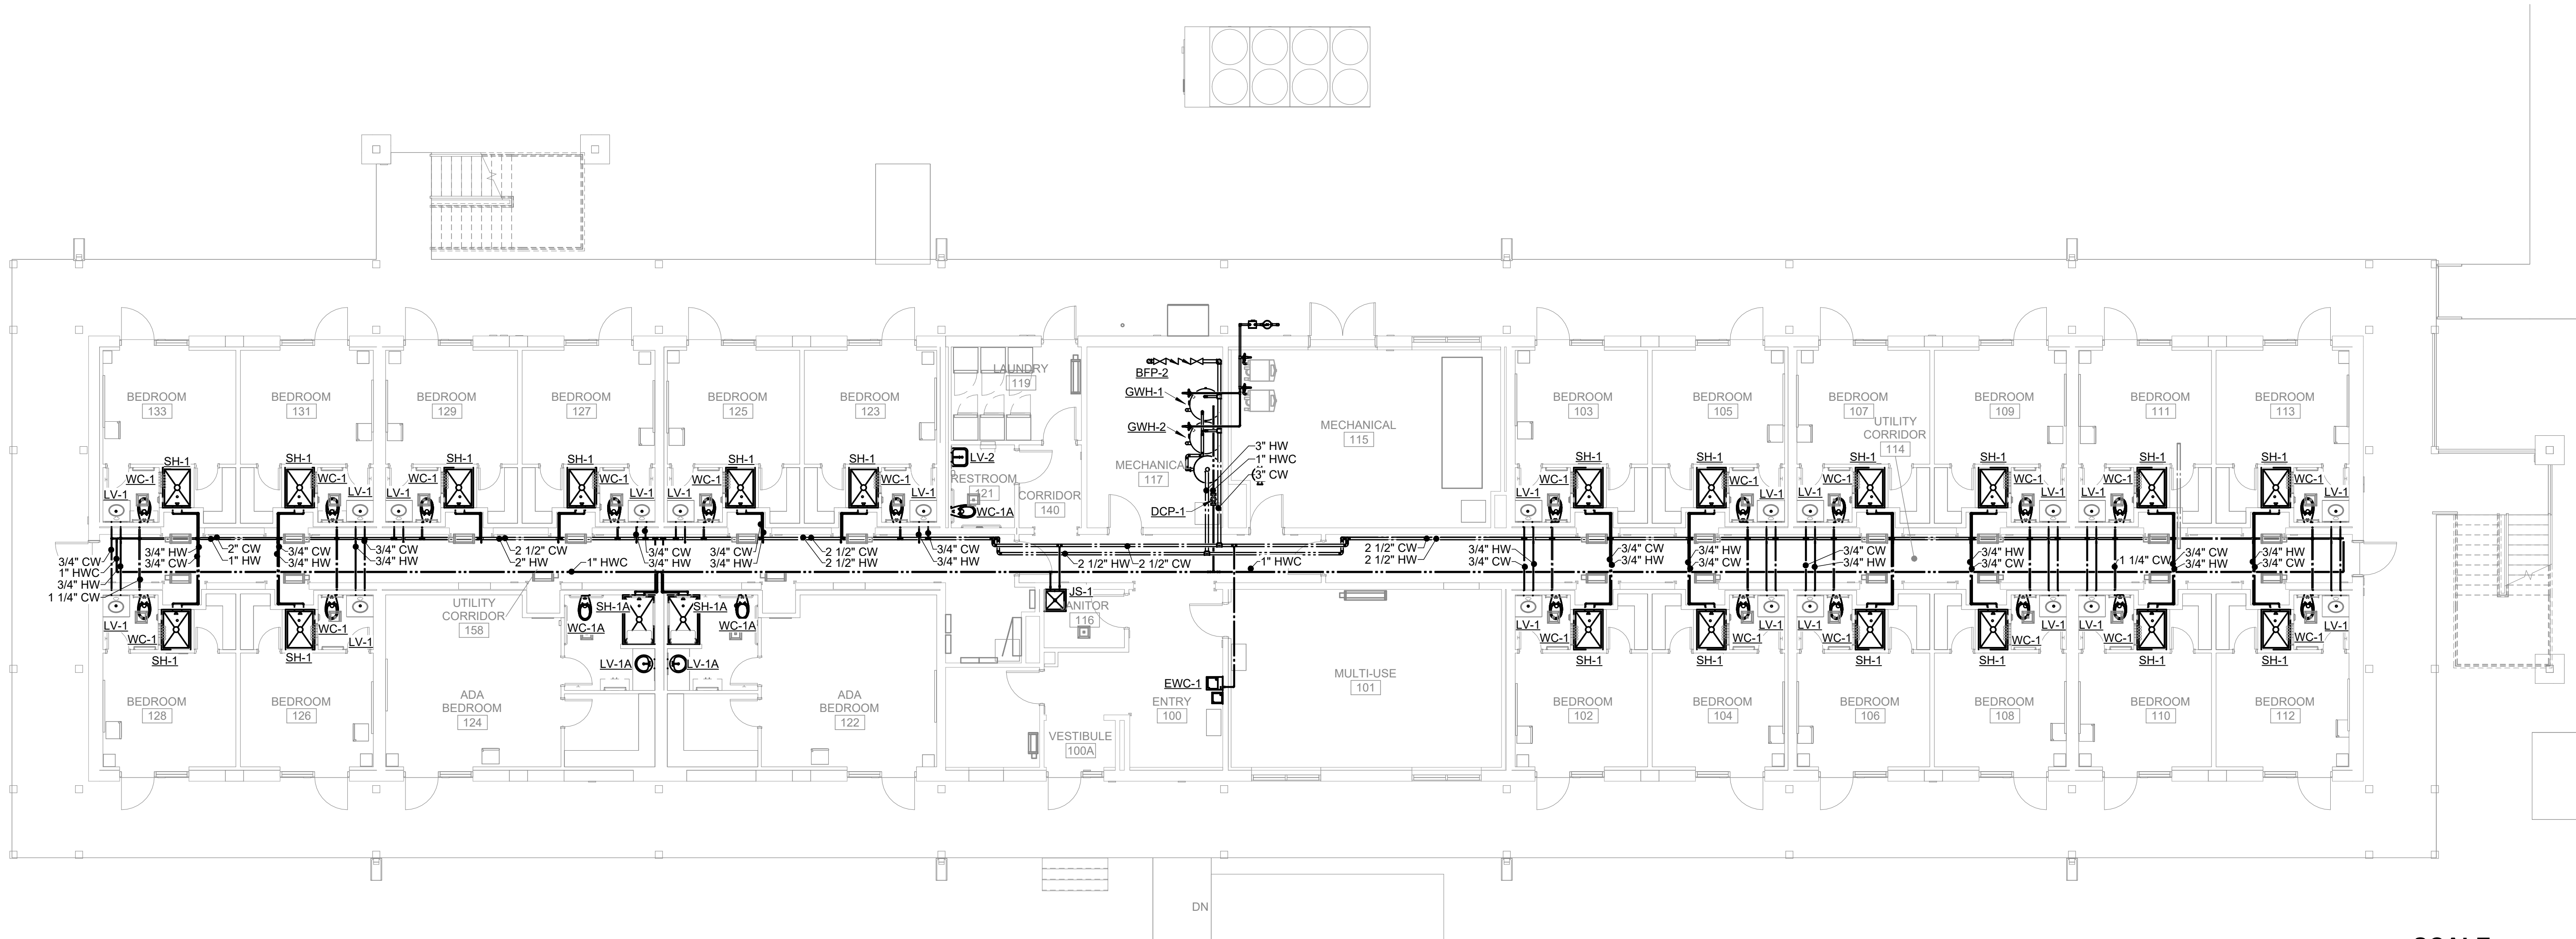

GENERAL SHEET NOTES

1. REFER TO DOMESTIC WATER 3D PLUMBING RISER DIAGRAMS FOR MORE INFORMATION.
2. REFER TO GAS 3D PLUMBING RISER DIAGRAMS FOR MORE INFORMATION.
3. RESTROOM DOMESTIC WATER PIPES SHOWN ON THIS PLAN ARE SCHEMATIC. AT CONTRACTOR'S OPTION, ROUTE PIPE IN WALL BEHIND PLUMBING FIXTURES AS REQUIRED.
4. COORDINATE ALL FLOOR PENETRATIONS WITH STRUCTURAL MEMBERS.

APPROVED	REV #	DATE	DESCRIPTION	APP'D
CHIEF ENGINEER APPROVED				
CIVIL ENGINEER				
NKAK 22-1076 B718 DORM LITTLE ROCK AFB DETAILS (1)				
LEVEL 1 DOMESTIC WATER AND NATURAL GAS PLAN				
AIR MOBILITY COMMAND 19TH CIVIL ENGINEER SQUADRON LITTLE ROCK, ARKANSAS				
DATE: JULY 2026 DESIGNED BY: SAH DRAWN BY: GAM BUILDING NO.: PROJECT NO.: SHEET REF.: P-301 SHEET NO.: 1 OF XX				
STATUS: 65% ISSUED FOR CONSTRUCTION				

A1 LEVEL 1 PLUMBING PLAN
SCALE: 1/8" = 1'-0"

