


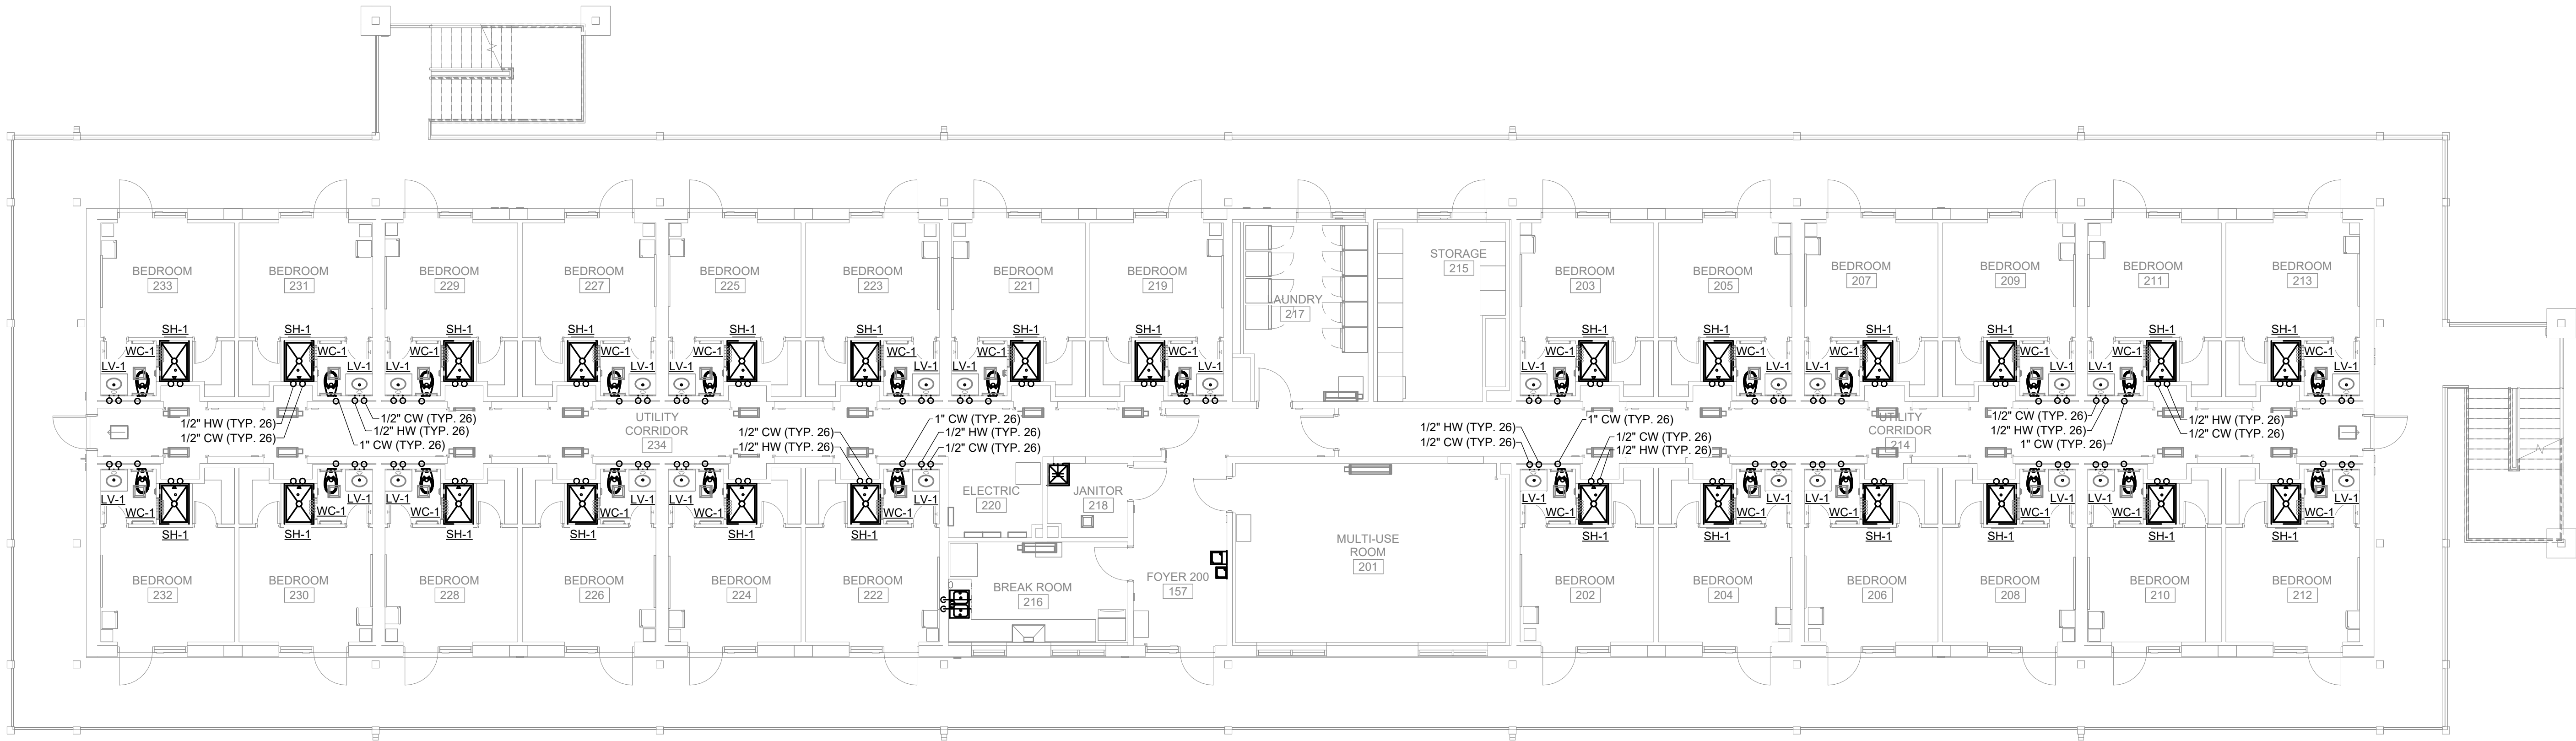


GENERAL SHEET NOTES

1. REFER TO DOMESTIC WATER 3D PLUMBING RISER DIAGRAMS FOR MORE INFORMATION.
2. REFER TO GAS 3D PLUMBING RISER DIAGRAMS FOR MORE INFORMATION.
3. RESTROOM DOMESTIC WATER PIPES SHOWN ON THIS PLAN ARE SCHEMATIC. AT CONTRACTOR'S OPTION, ROUTE PIPE IN WALL BEHIND PLUMBING FIXTURES AS REQUIRED.
4. COORDINATE ALL FLOOR PENETRATIONS WITH STRUCTURAL MEMBERS.

APP'D	DESCRIPTION	DATE	REV #	APPROVED	NKAK 22-1076 B718 DORM LITTLE ROCK AFB	LEVEL 2 DOMESTIC WATER AND NATURAL GAS PLAN	AIR MOBILITY COMMAND 19TH CIVIL ENGINEER SQUADRON LITTLE ROCK, ARKANSAS	DATE:	DESIGNED BY:	DRAWN BY:	PROJECT NO.:	SHEET REF.:	SHEET NO.:
				CHIEF ENGINEER APPROVED				JULY 2026	SAH	GAM		P-302	1 OF XX

STATUS:65% ISSUED FOR CONSTRUCTION

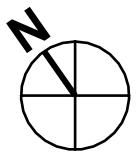

A1

LEVEL 2 PLUMBING PLAN

SCALE: 1/8" = 1'-0"

SCALE

0 4' 8' 16'

SCALE: 1/8"=1'-0"