


FLAG NOTES

- 13/4" DRAIN PAN DRAIN, 3/4" CONDENSATE DRAIN, AND 1" - 7" W.C. NATURAL GAS PIPING DOWN FROM NEW FURNACE LOCATION.
- 23" PVC COMBUSTION AIR AND 3" FLUE EXHAUST PIPING UP THROUGH ROOF. TERMINATE WITH FURNACE MANUFACTURER'S COMBINATION COMBUSTION AIR - EXHAUST FLUE FITTING.
- 3PROVIDE GAS PIPE SIZE TRANSITION AT FURNACE TO MATCH FURNACE CONNECTION SIZE AS REQUIRED.
- 4MOUNT REFRIGERANT PIPING AT ROOF ON PIPING SUPPORTS WITH PIPING CLAMPED TO SUPPORTS. PIPING SUPPORTS SHALL BE MIFAB MODEL C10 C-SERIES CHANNEL SUPPORTS CONSISTING OF RUBBER SUPPORTS WITH 13/16" GALVANIZED STEEL CHANNEL OR EQUAL. SUPPORT PIPING PER MANUFACTURER'S RECOMMENDATIONS. FIELD VERIFY ROUTE OF PIPING AND PLACEMENT OF PIPING SUPPORTS.
- 5MAINTAIN A MINIMUM CLEARANCE AS RECOMMENDED BY THE EQUIPMENT MANUFACTURER ON THIS SIDE OF THE UNIT.

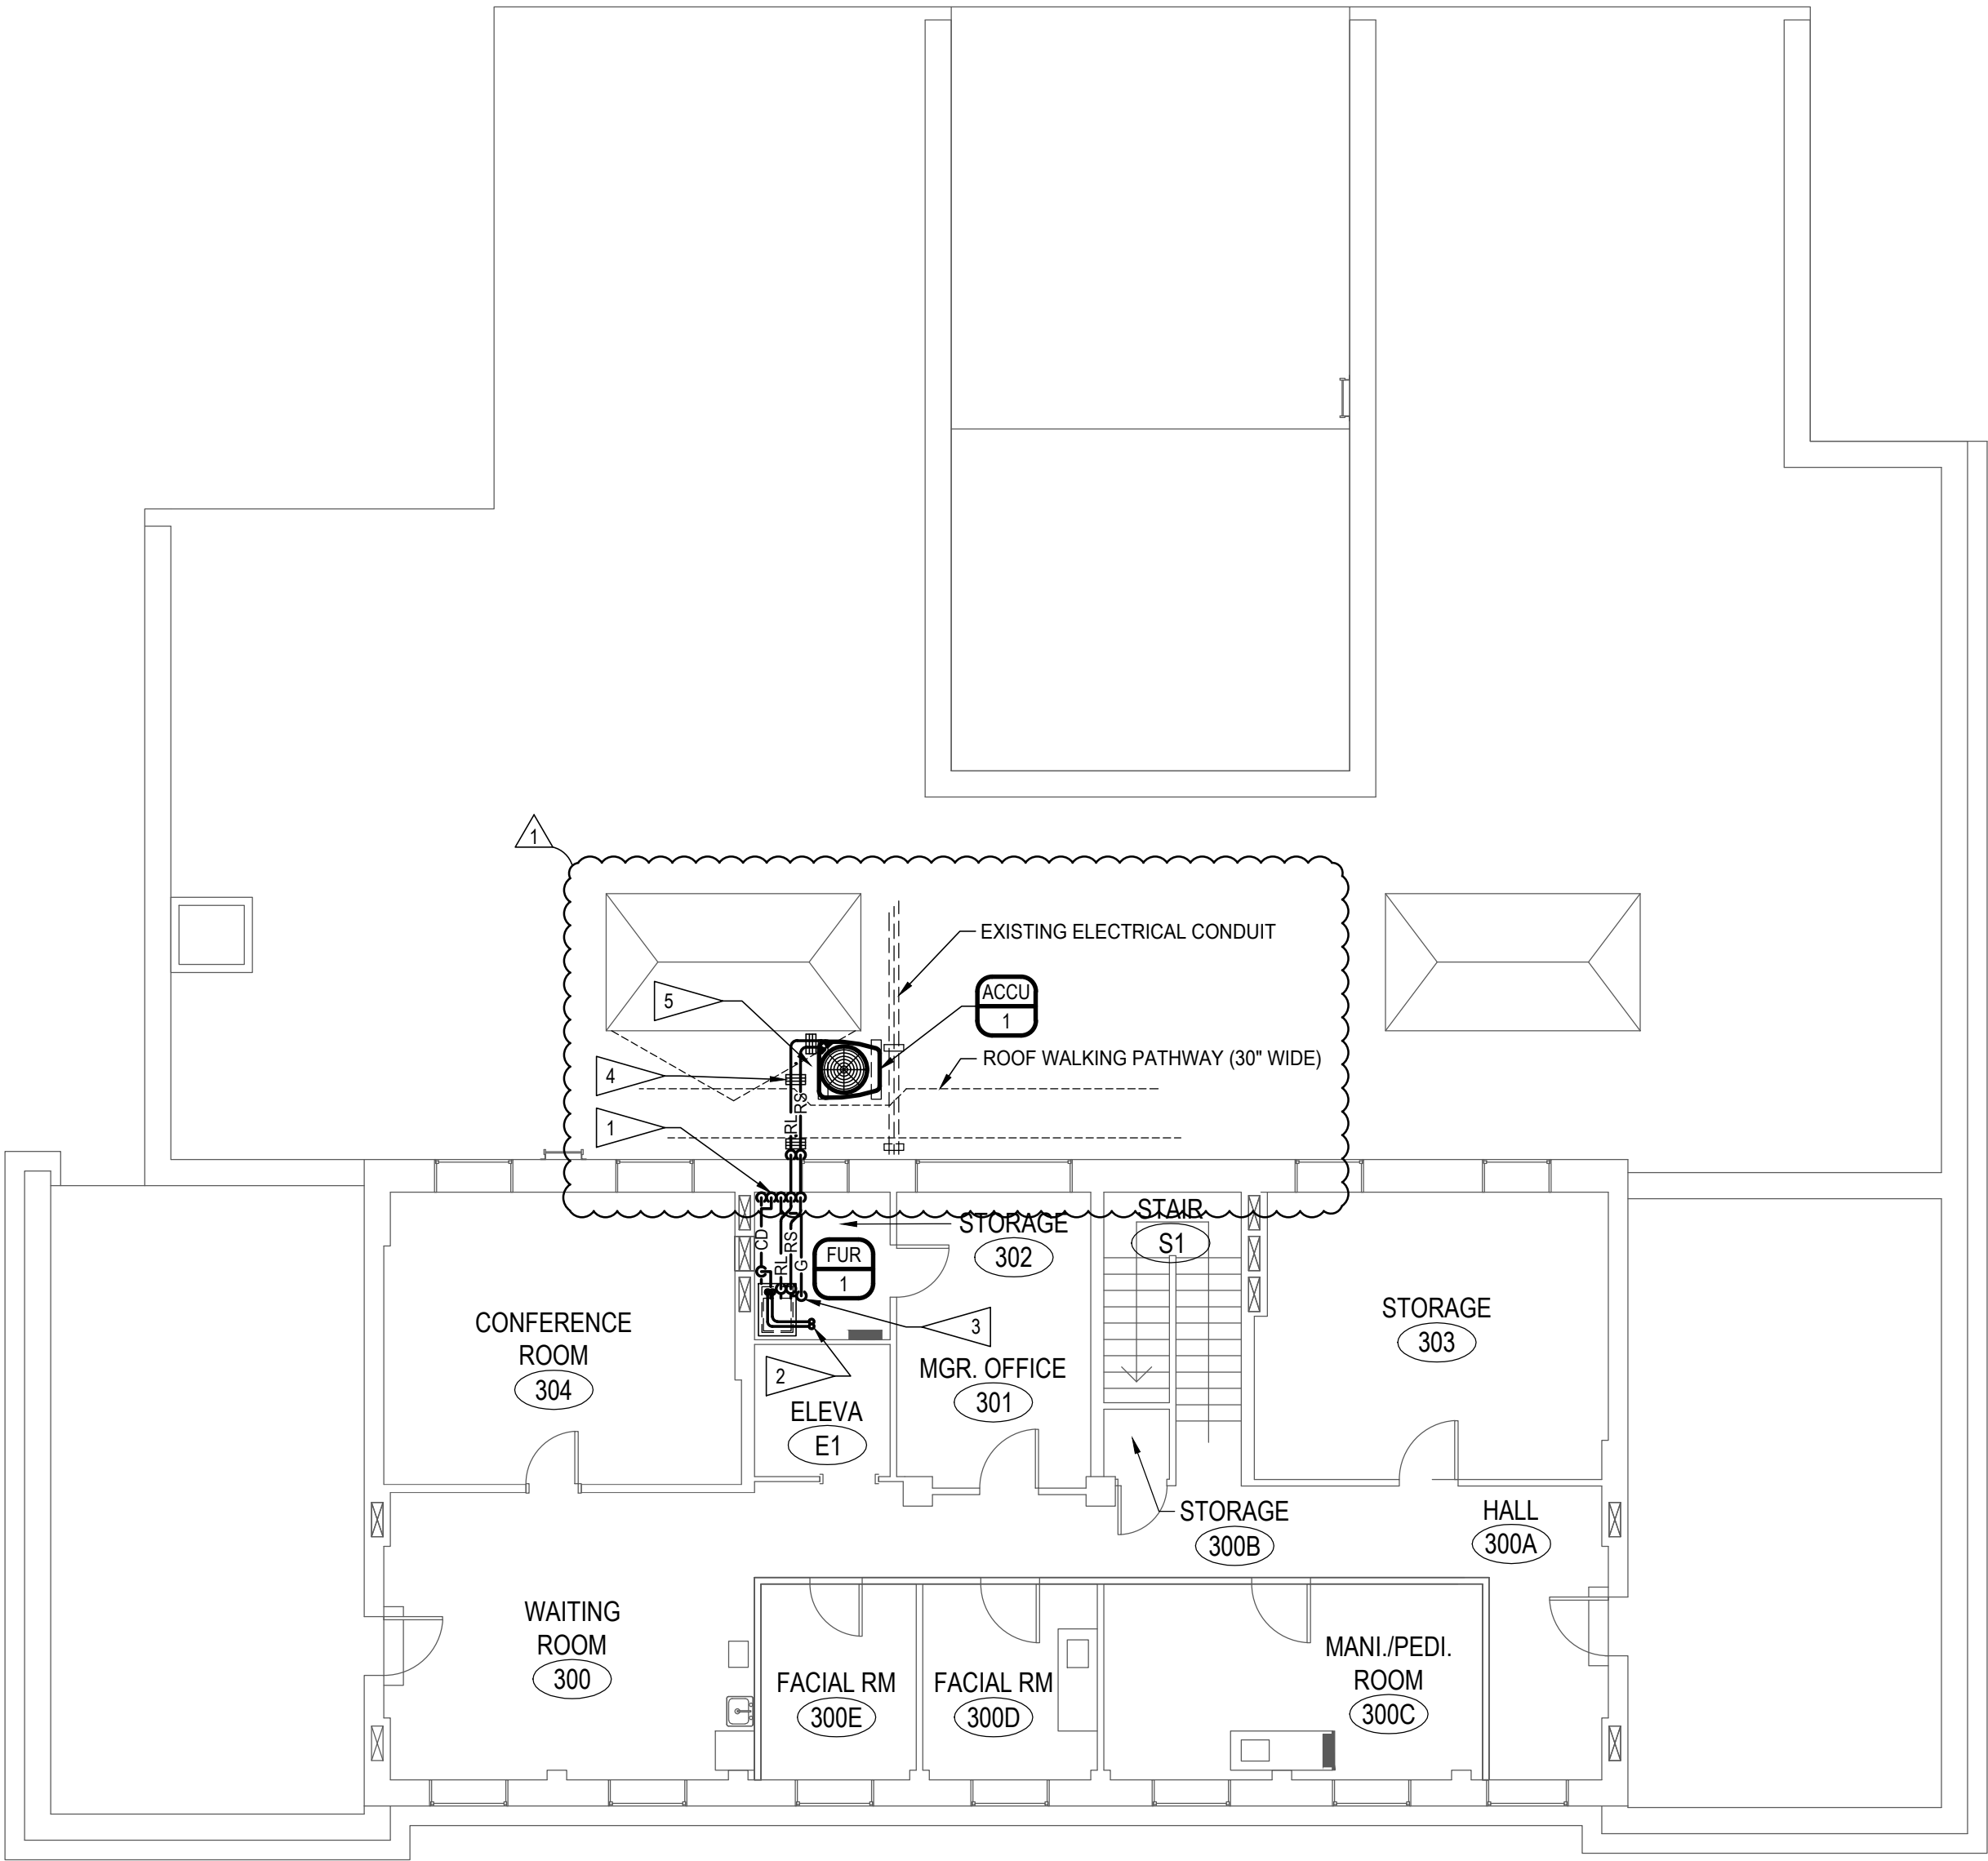

THIRD FLOOR PLAN - HVAC PIPING
SCALE: 1/8" = 1'-0"

ASI-1 2026-04-28
FINAL CONSTRUCTION DOCUMENTS

© COPYRIGHT 2024 AE# 20239955
Permission to reproduce all or part of this drawing is hereby granted solely for the limited purpose of construction of this project or archiving. Unauthorized copying, disclosure or construction use without written permission of Alvine Engineering is prohibited by copyright law.
NOTE:
DO NOT SCALE DRAWINGS. VERIFY ALL DIMENSIONS and clearances from ARCHITECTURAL, STRUCTURAL, shop and other appropriate drawing or at site. lay out and coordinate all work prior to installation to provide clearances required for operation, maintenance, and codes and verify non-interference with other work. DO NOT FABRICATE PRIOR TO VERIFICATION OF CLEARANCE FOR ALL TRADES. READ SPECIFICATIONS.

A/E FIRM PRIME: KENNETH HAHN ARCHITECTS, INC. OMAHA, NE. SUBCONTRACTOR: ALVINE ENGINEERING OMAHA, NE.	DESIGNED: MRG	SUB SHEET NO. M3-4	TITLE OF SHEET THIRD FLOOR PLAN - HVAC PIPING BUCKSTAFF BATHHOUSE HVAC HOT SPRINGS NATIONAL PARK HOT SPRINGS, AK	DRAWING NO. XXX/XXXX
	DRAWN BY: MRG			PMIS NO. 177425
	TECH. REVIEW: BAH			SHEET
	DATE: 2/15/2024			27 OF 51