

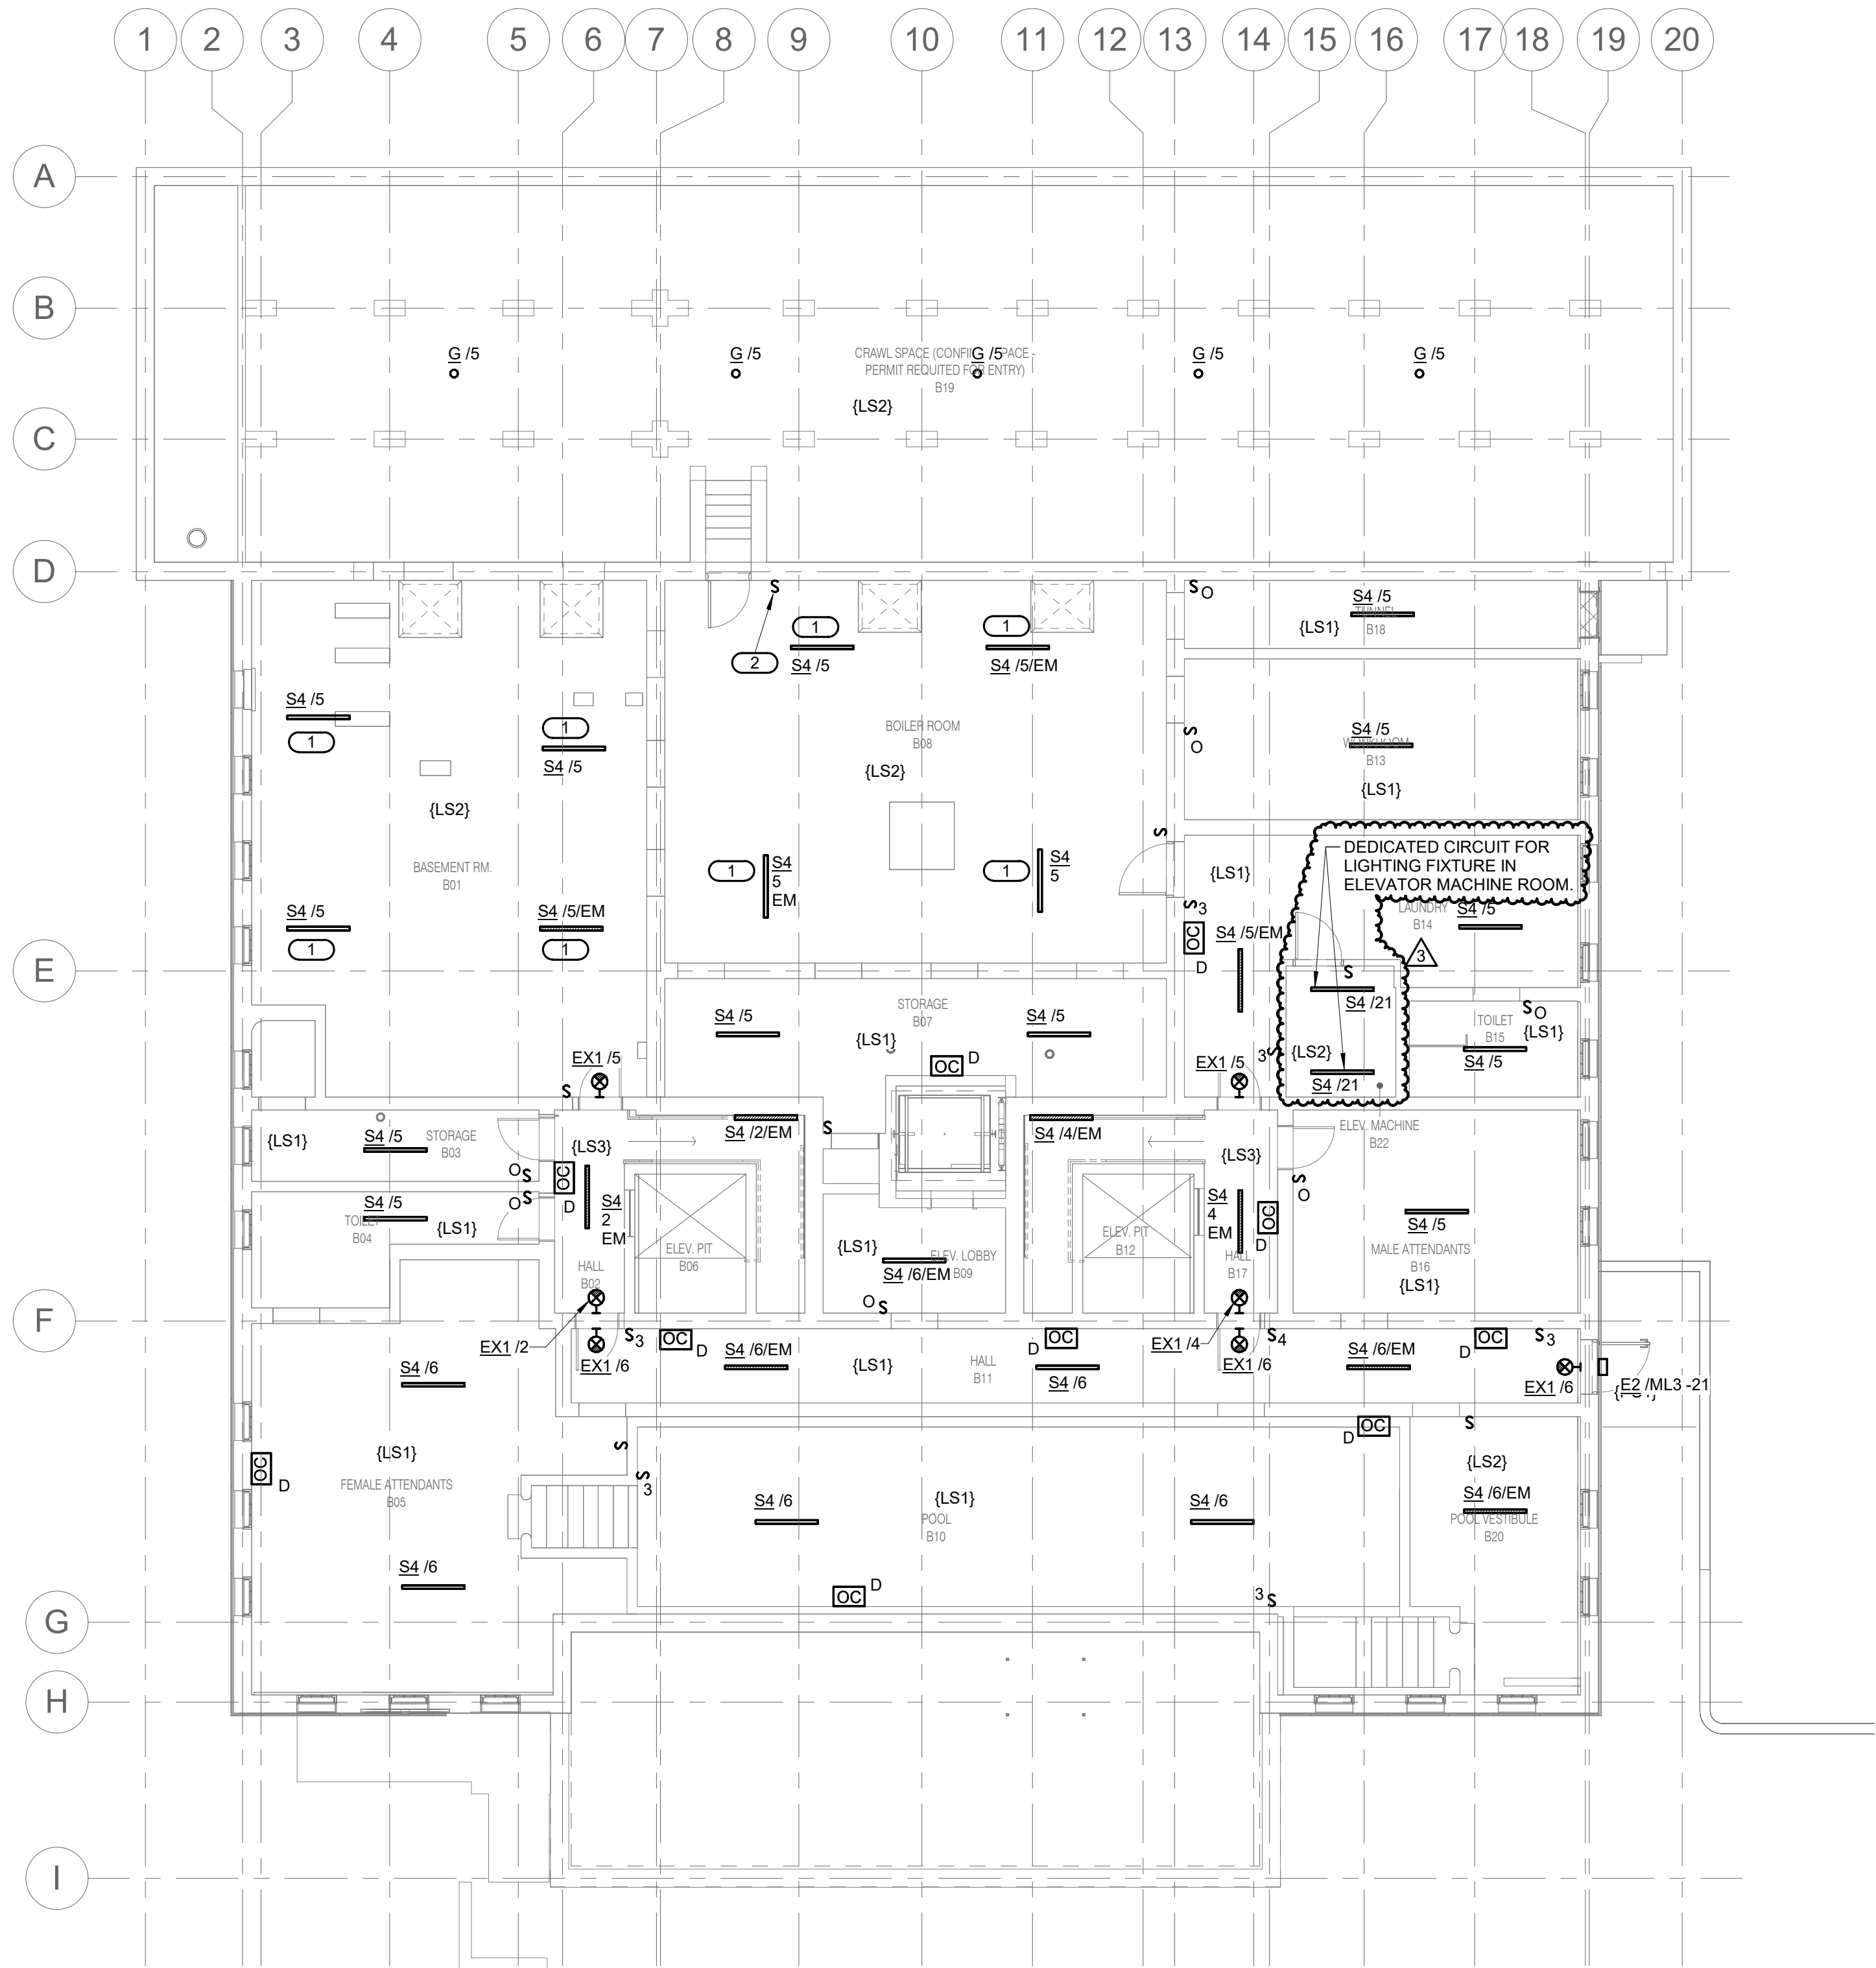


- SHEET NOTES:**
1. REFER TO SHEET E0.0 AND E0.1 FOR GENERAL NOTES AND SYMBOLS.
 2. ALL LIGHTING CIRCUITS ON THIS SHEET SHALL BE CONNECTED TO PANEL MLB, UNLESS NOTED OTHERWISE.
 3. MOUNT LINEAR SUSPENDED TYPE LIGHTING FIXTURE AT 7' 6" AFF, UNLESS NOTED OTHERWISE. COORDINATE WITH STRUCTURAL BEAM, MECHANICAL PIPES AND DUCTWORK.

- KEYNOTES:** #
1. SUSPENDED LINEAR FIXTURE SHALL BE MOUNTED AT 7' 0" AFF OR EVEN WITH BOTTOM OF BEAMS.
 2. LIGHT SWITCH CONTROLS LIGHT FIXTURES 'G' IN CRAWL SPACE.

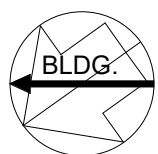

1 BASEMENT LIGHTING PLAN
EL1.0 1/8" = 1'-0"

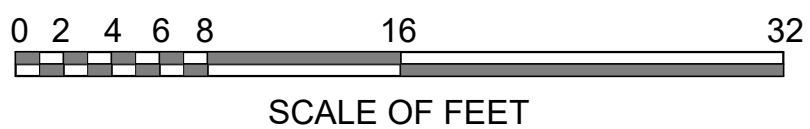

SI-08 05.27.2026



10.27.2023

A/E FIRMS PRIME/ARCH: STRATA ARCHITECTURE 1701 OAK STREET, SUITE 100 KANSAS CITY, MO T: 816.474.0900 MEP/ENG: IMEG CORP. 1600 BALTIMORE STREET, SUITE 300 KANSAS CITY, MO T: 816.842.8437	DESIGNED: PIP	SUB SHEET NO. 01 EL1.0	TITLE OF SHEET MAURICE BATHHOUSE BASEMENT LIGHTING PLAN REHABILITATE BATHHOUSES HOT SPRINGS NATIONAL PARK	DRAWING NO. 626 180065
	CADD: WMM			PMIS/PKG NO. 318674
	TECH. REVIEW: PIP			SHEET 171 OF 286
	DATE: 10.27.2023			