

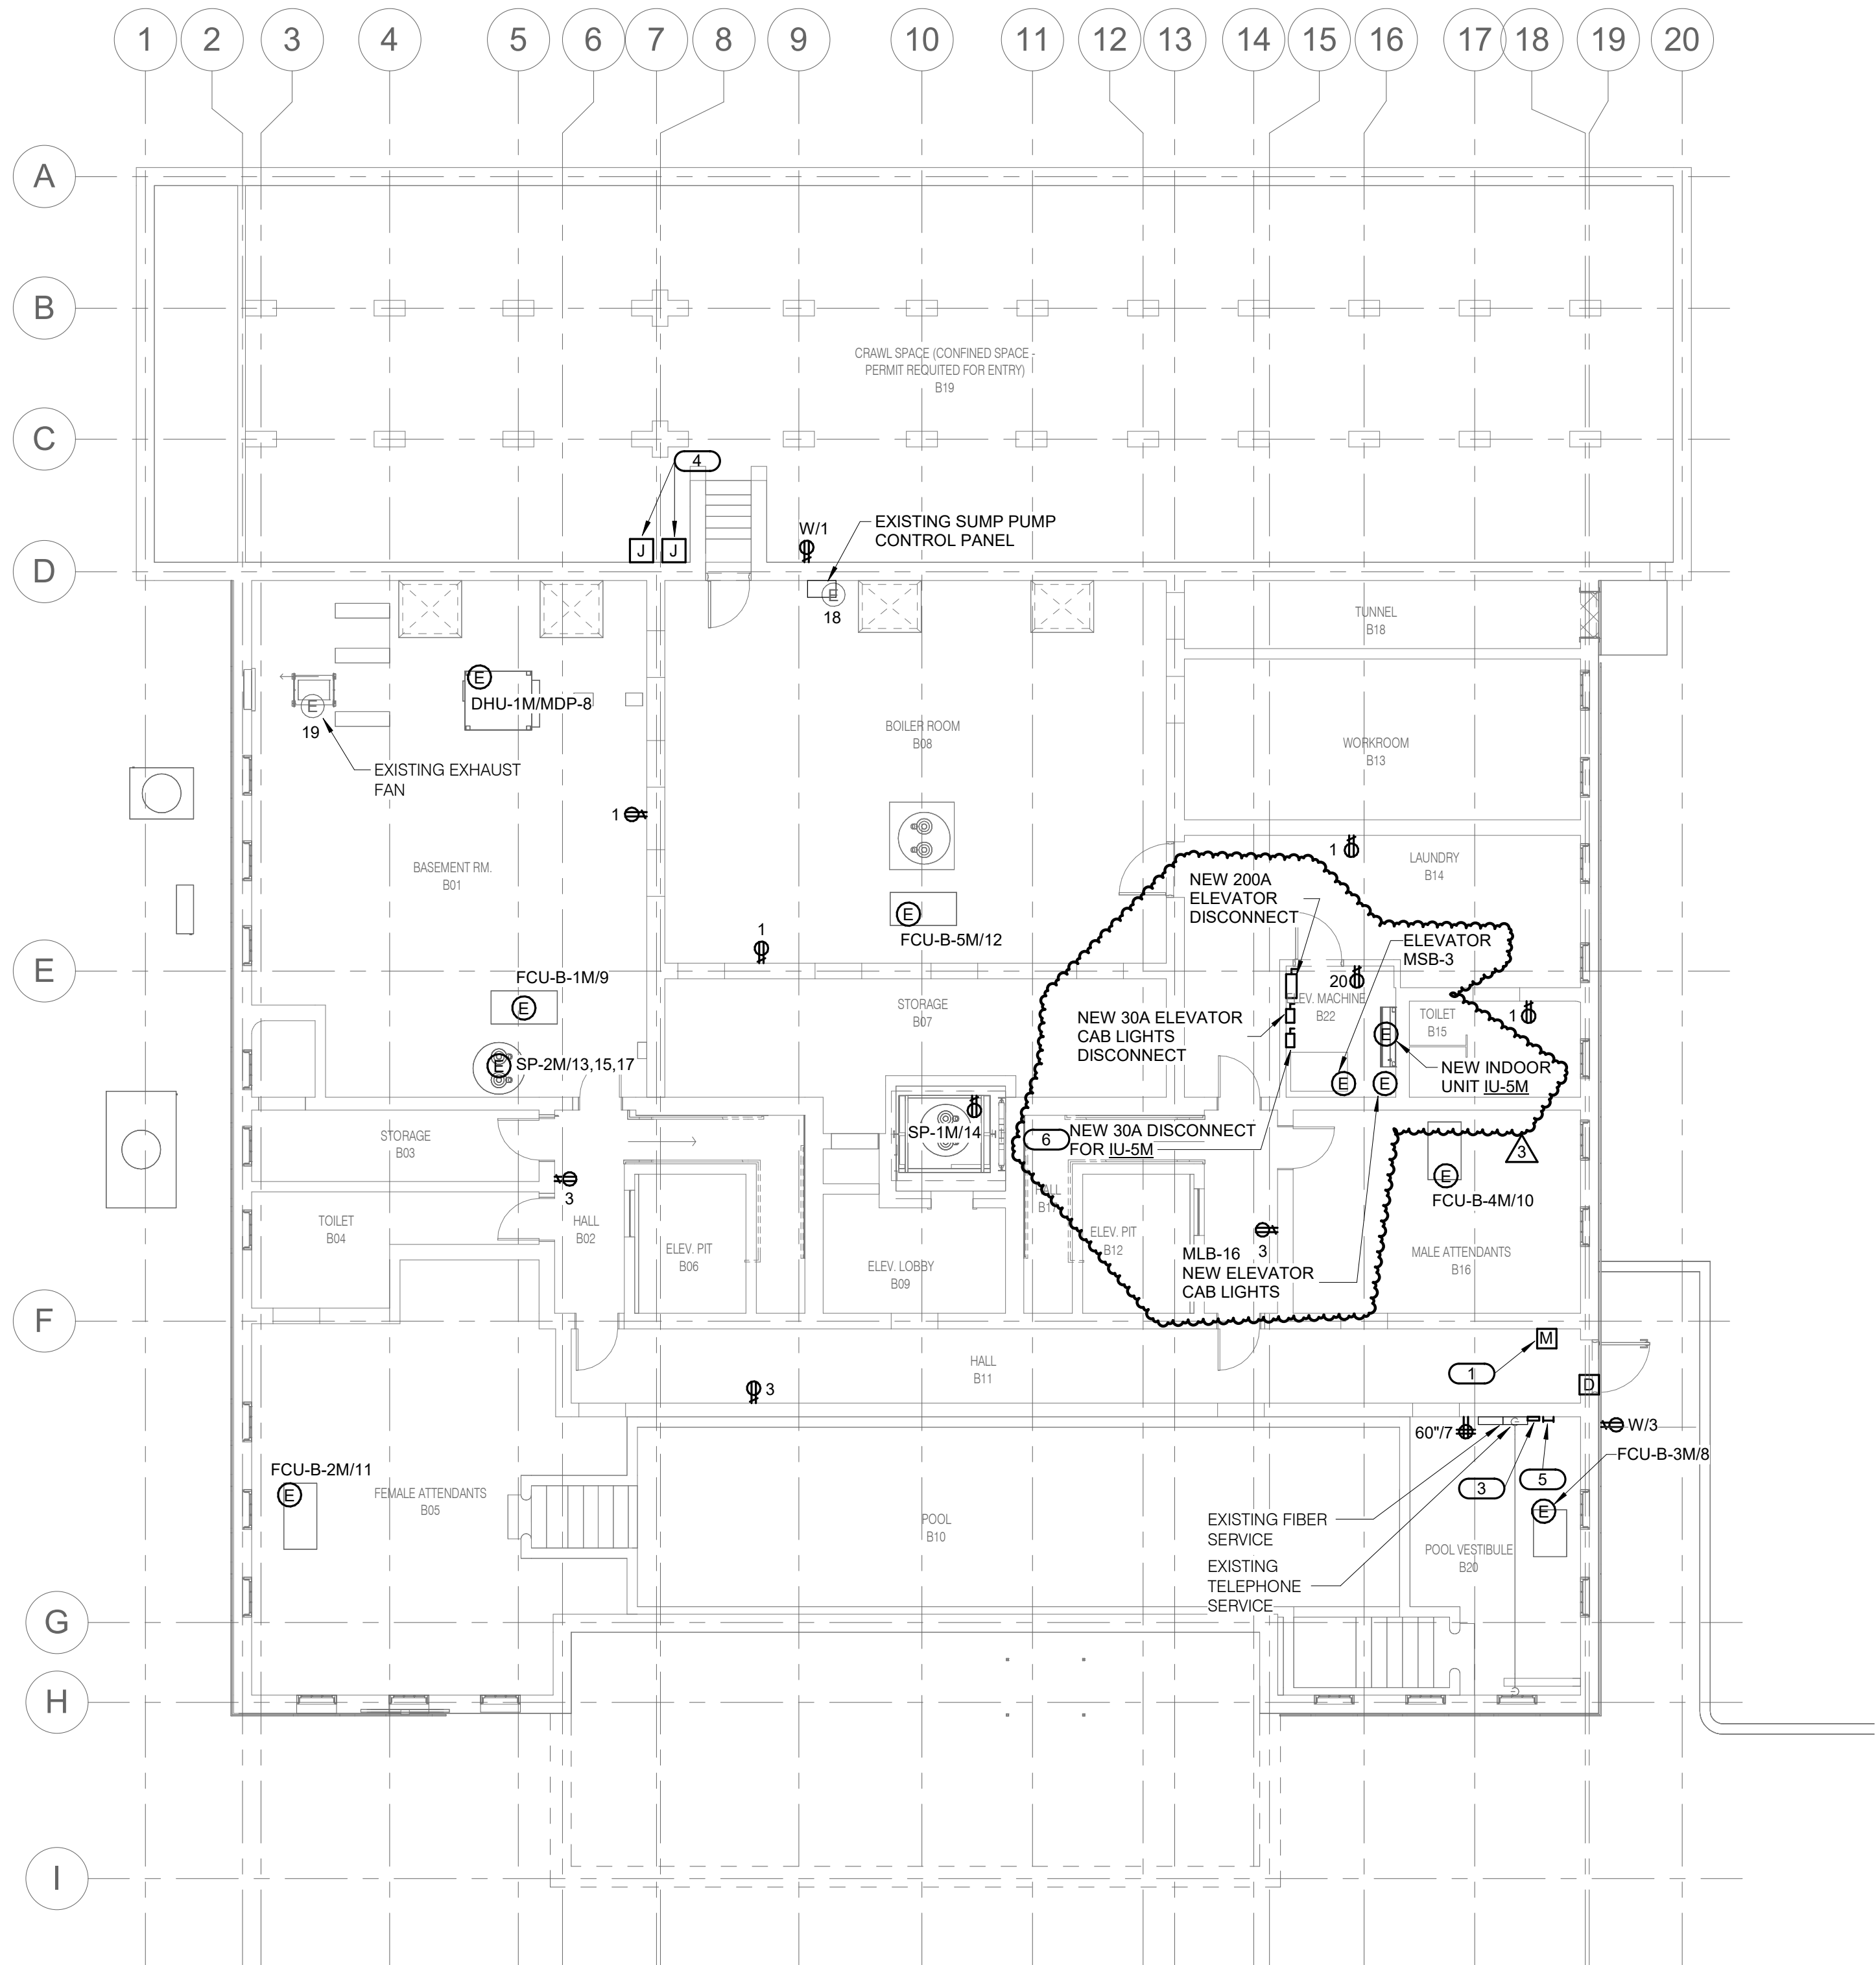


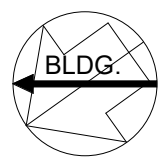

- SHEET NOTES:**
1. REFER TO SHEET E0.0 AND E0.1 FOR GENERAL NOTES AND SYMBOLS.
 2. REFER TO MECHANICAL PLANS FOR ALL MECHANICAL EQUIPMENT LOCATIONS.
 3. ALL POWER CIRCUITS ON THIS SHEET SHALL BE CONNECTED TO PANEL MLB, UNLESS NOTED OTHERWISE.
 4. ALL POWER, SECURITY AND LOW-VOLTAGE WIRING SHALL BE INSTALLED IN CONDUIT.

- KEYNOTES:** (#)
1. ADDRESSABLE MOTION / INTRUSION SENSOR THAT RELAYS SIGNAL TO SECURITY SYSTEM.
 2. EXISTING EXHAUST FAN TO BE RE-CIRCUITED TO PANEL 'MLB'.
 3. FURNISH AND INSTALL NEW STANDALONE NETWORK SWITCH FOR DATA CONNECTIONS ON 1ST FLOOR.
 4. THERMOSTAT AND HUMIDISTAT SERVING DEHUMIDIFIER FURNISHED AND INSTALLED BY M.C. E.C. SHALL INSTALL LOW-VOLTAGE WIRING FROM THERMOSTAT AND HUMIDISTAT TO DEHUMIDIFIER IN BASEMENT RM B01. COORDINATE WITH M.C.
 5. TELECOMMUNICATIONS GROUND BUSBAR (TGB) MOUNT AT 6'-8" AFF.
 6. POWER FOR NEW INDOOR UNIT WILL BE COMING FROM THE ELECTRICAL CONNECTION OF THE OUTSIDE CONDENSING UNIT. FURNISH AND INSTALL NECESSARY CONDUIT AND WIRE AS REQUIRED.

1 BASEMENT POWER PLAN
EP1.0 1/8" = 1'-0"

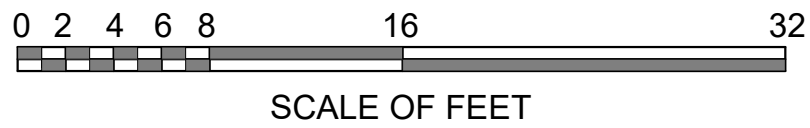

SI-08 05.27.2023



10.27.2023

A/E FIRMS PRIME/ARCH: STRATA ARCHITECTURE 1701 OAK STREET, SUITE 100 KANSAS CITY, MO T: 816.474.0900 MEP/ENG: IMEG CORP. 1600 BALTIMORE STREET, SUITE 300 KANSAS CITY, MO T: 816.842.8437	DESIGNED: PIP	SUB SHEET NO. 01 EP1.0	TITLE OF SHEET MAURICE BATHHOUSE BASEMENT POWER PLAN REHABILITATE BATHHOUSES HOT SPRINGS NATIONAL PARK	DRAWING NO. 626 180065
	CADD: WMM			PMIS/PKG NO. 318674
	TECH. REVIEW: PIP			SHEET 176 OF 286
	DATE: 10.27.2023			