

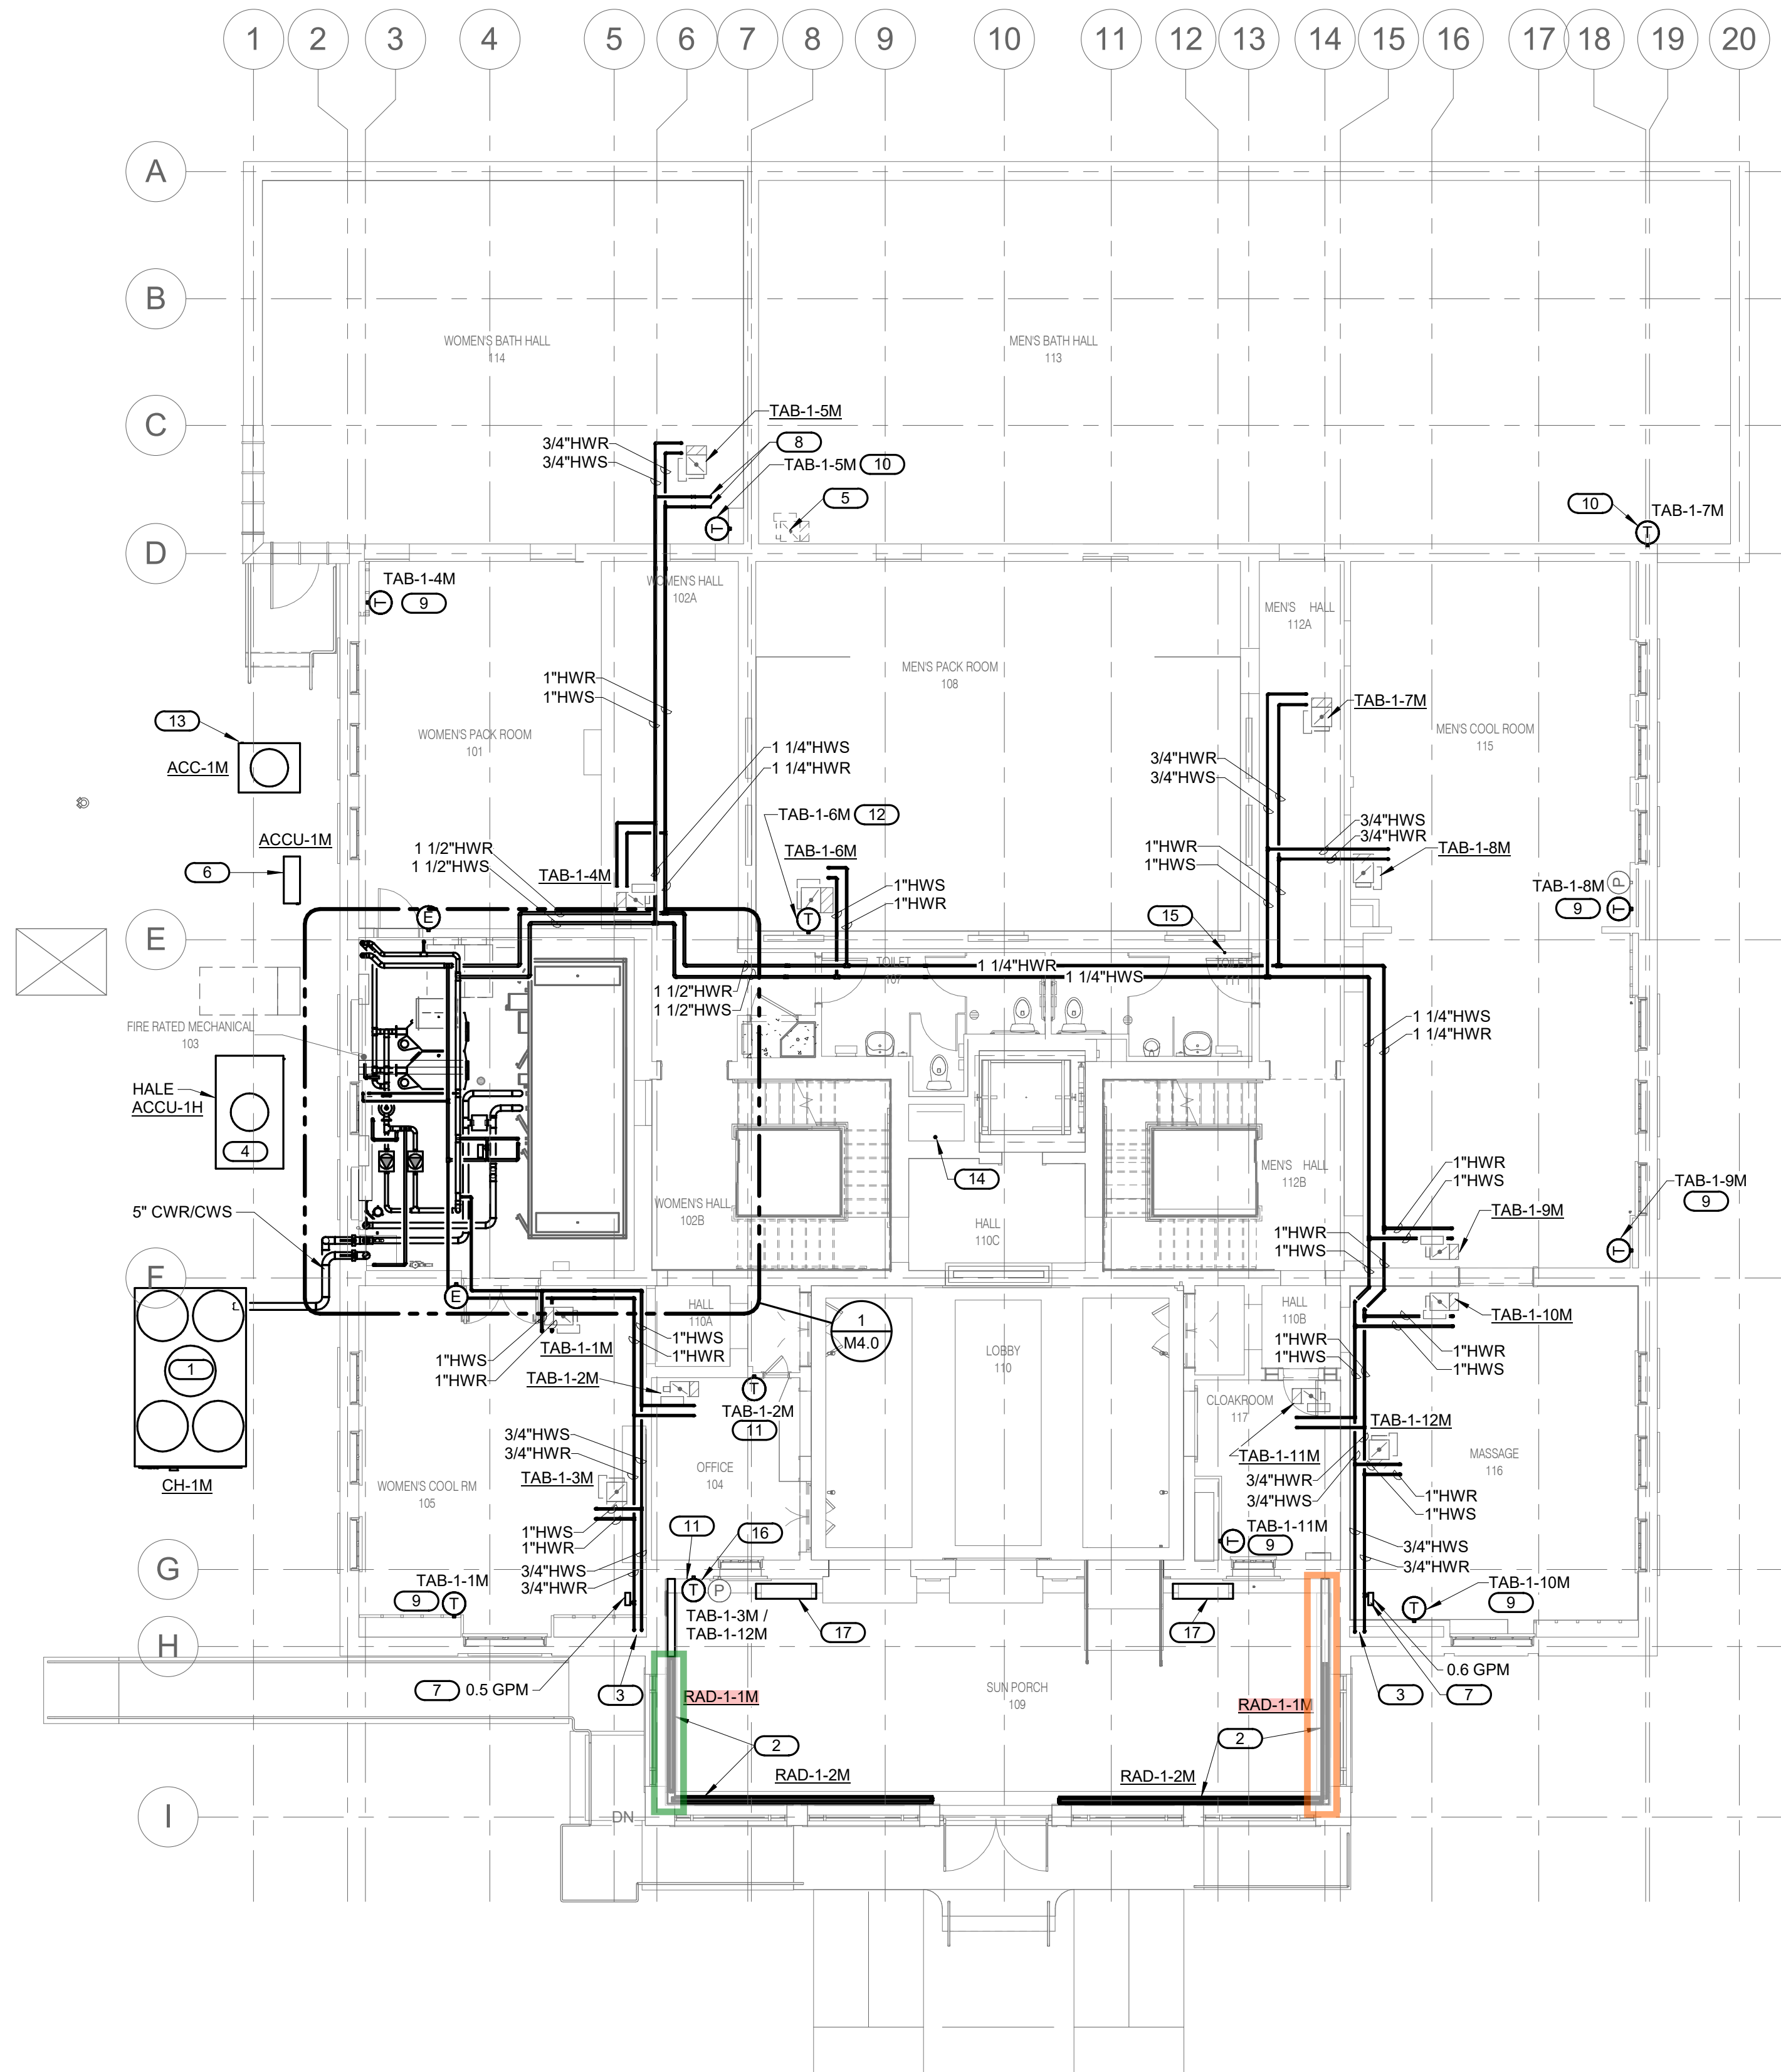


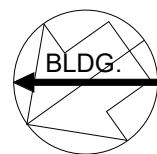

- SHEET NOTES:**
- ROUTING OF TERMINAL EQUIPMENT, DUCTWORK AND PIPING SHALL BE VERY CAREFULLY COORDINATED WITH EXISTING CONDITIONS, PRESERVATION ZONES AND HISTORIC NATURE OF BUILDING TO CONFORM WITH THE SECRETARY OF THE INTERIOR'S REHABILITATION REQUIREMENTS AND PRESERVATION BRIEFS RELATED TO MEP DESIGN AND INSTALLATION.

- KEYNOTES:**
- AIR COOLED CHILLER SET ON CONCRETE PAD. EXTEND CHILLED WATER TO BUILDING.
 - CONTINUOUS HOT WATER PEDESTAL FINNED TUBE RADIATOR WITH LINEAR BAR GRILLE OUTLET IN ARCHITECTURAL STYLE METAL ENCLOSURE. ROUTE RETURN PIPING IN COVES. LOBBY FLOOR IS SLOPED SLIGHTLY DOWN FROM EAST TO WEST. COORDINATE WITH HOUSING INSTALLATION AND SUPPORT FEET.
 - 3/4\"/>

1 FIRST FLOOR MECHANICAL PIPING PLAN
MP1.1 1/8" = 1'-0"

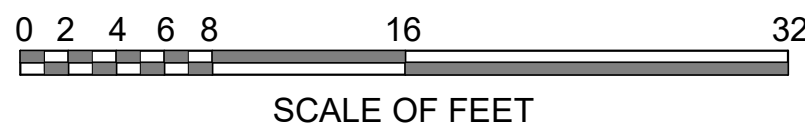

10.27.2023

A/E FIRMS PRIME/ARCH: STRATA ARCHITECTURE 1701 OAK STREET, SUITE 100 KANSAS CITY, MO T: 816.474.0900 MEP/ENG: IMEG CORP. 1600 BALTIMORE STREET, SUITE 300 KANSAS CITY, MO T: 816.842.8437	DESIGNED:	SUB SHEET NO. 01 MP1.1	TITLE OF SHEET MAURICE BATHHOUSE FIRST FLOOR MECHANICAL PIPING PLAN REHABILITATE BATHHOUSES HOT SPRINGS NATIONAL PARK	DRAWING NO. 626 180065
	CADD:			PMIS/PKG NO. 318674
	TECH. REVIEW:			SHEET 147 OF 286
	DATE: 10.27.2023			