


- SHEET NOTES:**
- ROUTING OF TERMINAL EQUIPMENT. DUCTWORK AND PIPING SHALL BE VERY CAREFULLY COORDINATED WITH EXISTING CONDITIONS, PRESERVATION ZONES AND HISTORIC NATURE OF BUILDING TO CONFORM WITH THE SECRETARY OF THE INTERIOR'S REHABILITATION REQUIREMENTS AND PRESERVATION BRIEFS RELATED TO MEP DESIGN AND INSTALLATION.


- KEYNOTES:** #
- PEDISTAL MOUNTED FINNED TUBE RADIATOR COVER WITH TWO (2) 3-ELEMENT SECTIONS FED FROM THE NORTH & SOUTH ENDS WITH RETURN PIPING ROUTED IN COVER.
 - 3/4" HWS & HWR RISERS ROUTED IN EXISTING PIPE CHASE. CONNECT 3/4" PIPING TO SERVE HALF OF PEDESTAL FINNED TUBE.
 - 4-PIPE VERTICAL FAN COIL UNIT CONNECTED TO 3/4" HWS, HWR, CWS, CWR, DPP ON FLOOR BELOW.
 - 4-PIPE VERTICAL FAN COIL UNIT CONNECTED TO 3/4" HWS, HWR, DPP, AND 1" CWS, CWR ON FLOOR BELOW.
 - TEMPORARY THERMOSTAT LOCATION. THERMOSTAT CAN BE SURFACE MOUNTED WITH SURFACE MOUNTED CONDUIT.
 - COMBINATION THERMOSTAT/CO2 SENSOR MOUNTED AT EXISTING ABANDONED LAVATORY ROUGH-IN LOCATION. ROUTE CONDUIT WIRING DOWN THROUGH EXISTING PIPING PENETRATIONS AND PATCH.

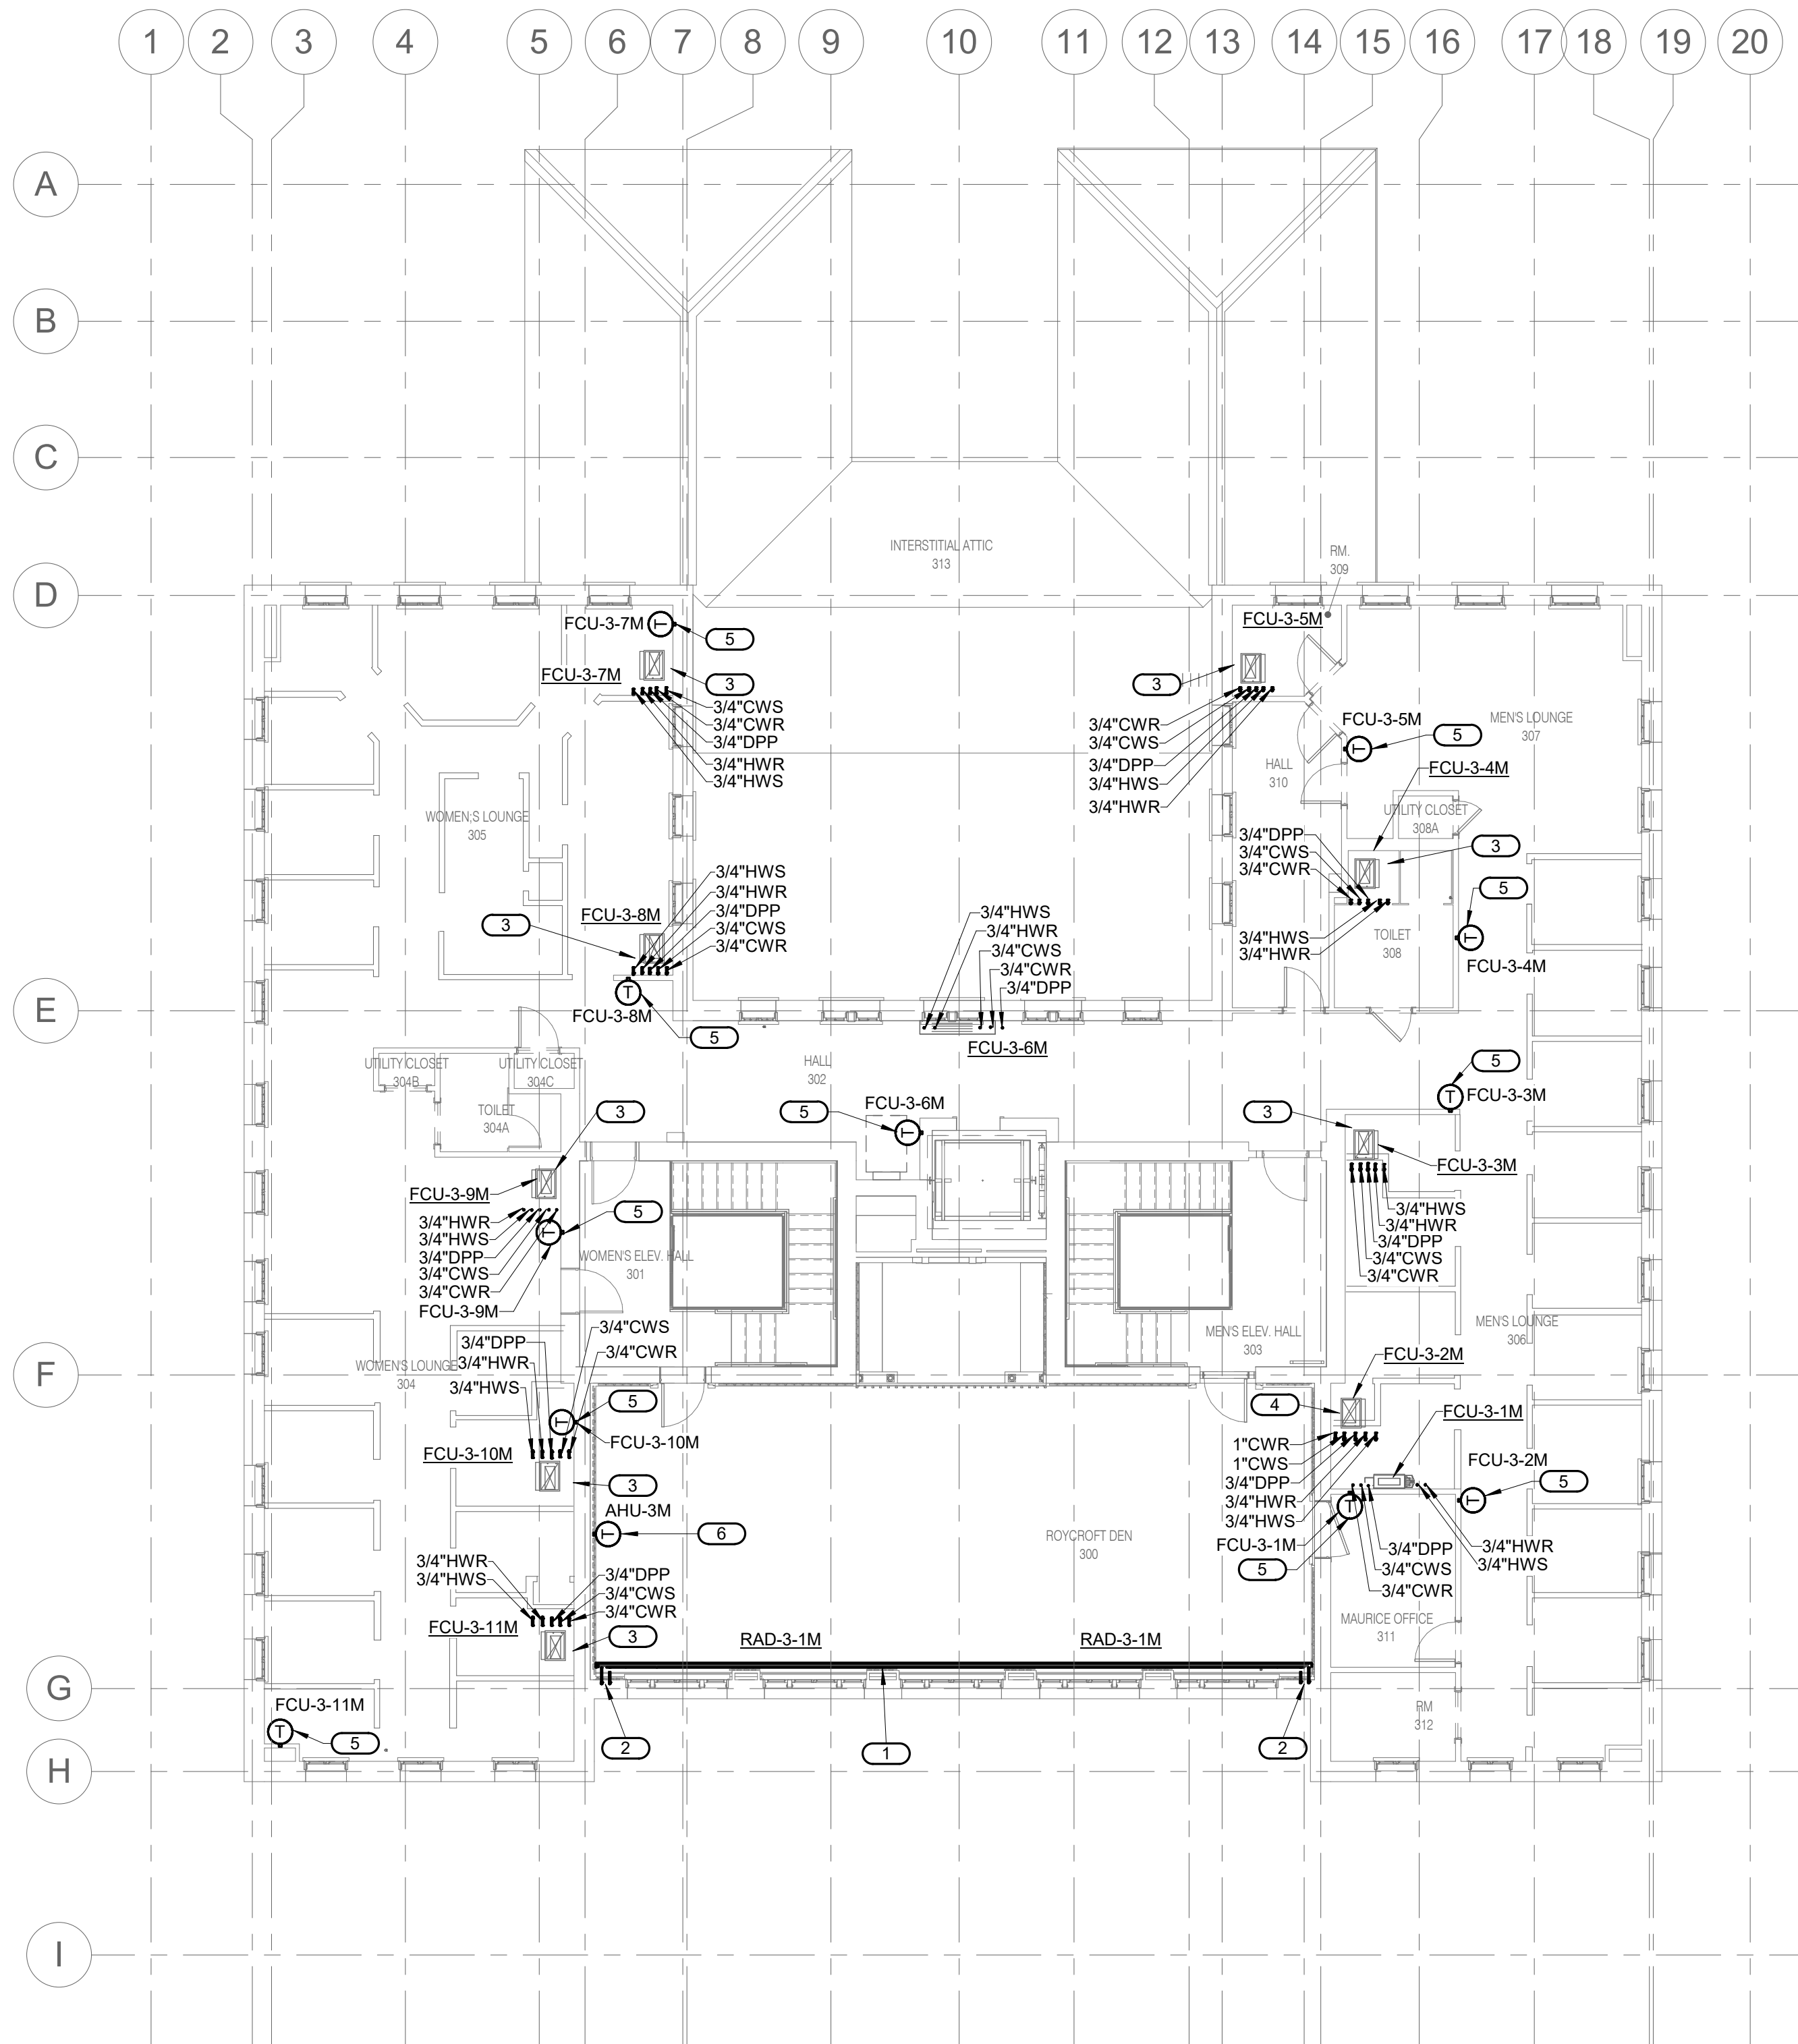

1
MP1.3 THIRD FLOOR MECHANICAL PIPING PLAN

1/8" = 1'-0"

0 2 4 6 8 16 32
SCALE OF FEET

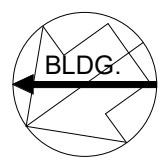

10.27.2023

A/E FIRMS PRIME/ARCH: STRATA ARCHITECTURE 1701 OAK STREET, SUITE 100 KANSAS CITY, MO T: 816.474.0900 MEP/ENG: IMEG CORP. 1600 BALTIMORE STREET, SUITE 300 KANSAS CITY, MO T: 816.842.8437	DESIGNED:	SUB SHEET NO. 01 MP1.3	TITLE OF SHEET MAURICE BATHHOUSE THIRD FLOOR MECHANICAL PIPING PLAN REHABILITATE BATHHOUSES HOT SPRINGS NATIONAL PARK	DRAWING NO. 626 180065
	CADD:			PMIS/PKG NO. 318674
	TECH. REVIEW:			SHEET 148 OF 286
	DATE: 10.27.2023			