

NEW BLAST FACILITY FOR
LEXICON INC.
8900 FOURCHE DAM PIKE
LITTLE ROCK, ARKANSAS

:STAMP

CONSTRUCTION DOCUMENTS
:SHEET TITLE
ELECTRICAL SECTIONS



:REVISIONS		
NO.	DESCRIPTION	DATE
1	Revision 1	01/22/25
7	Wall Layout	09/21/26

1 NOVEMBER 24 :ISSUE DATE


24-007 :PROJECT NUMBER

:SHEET NUMBER

E301

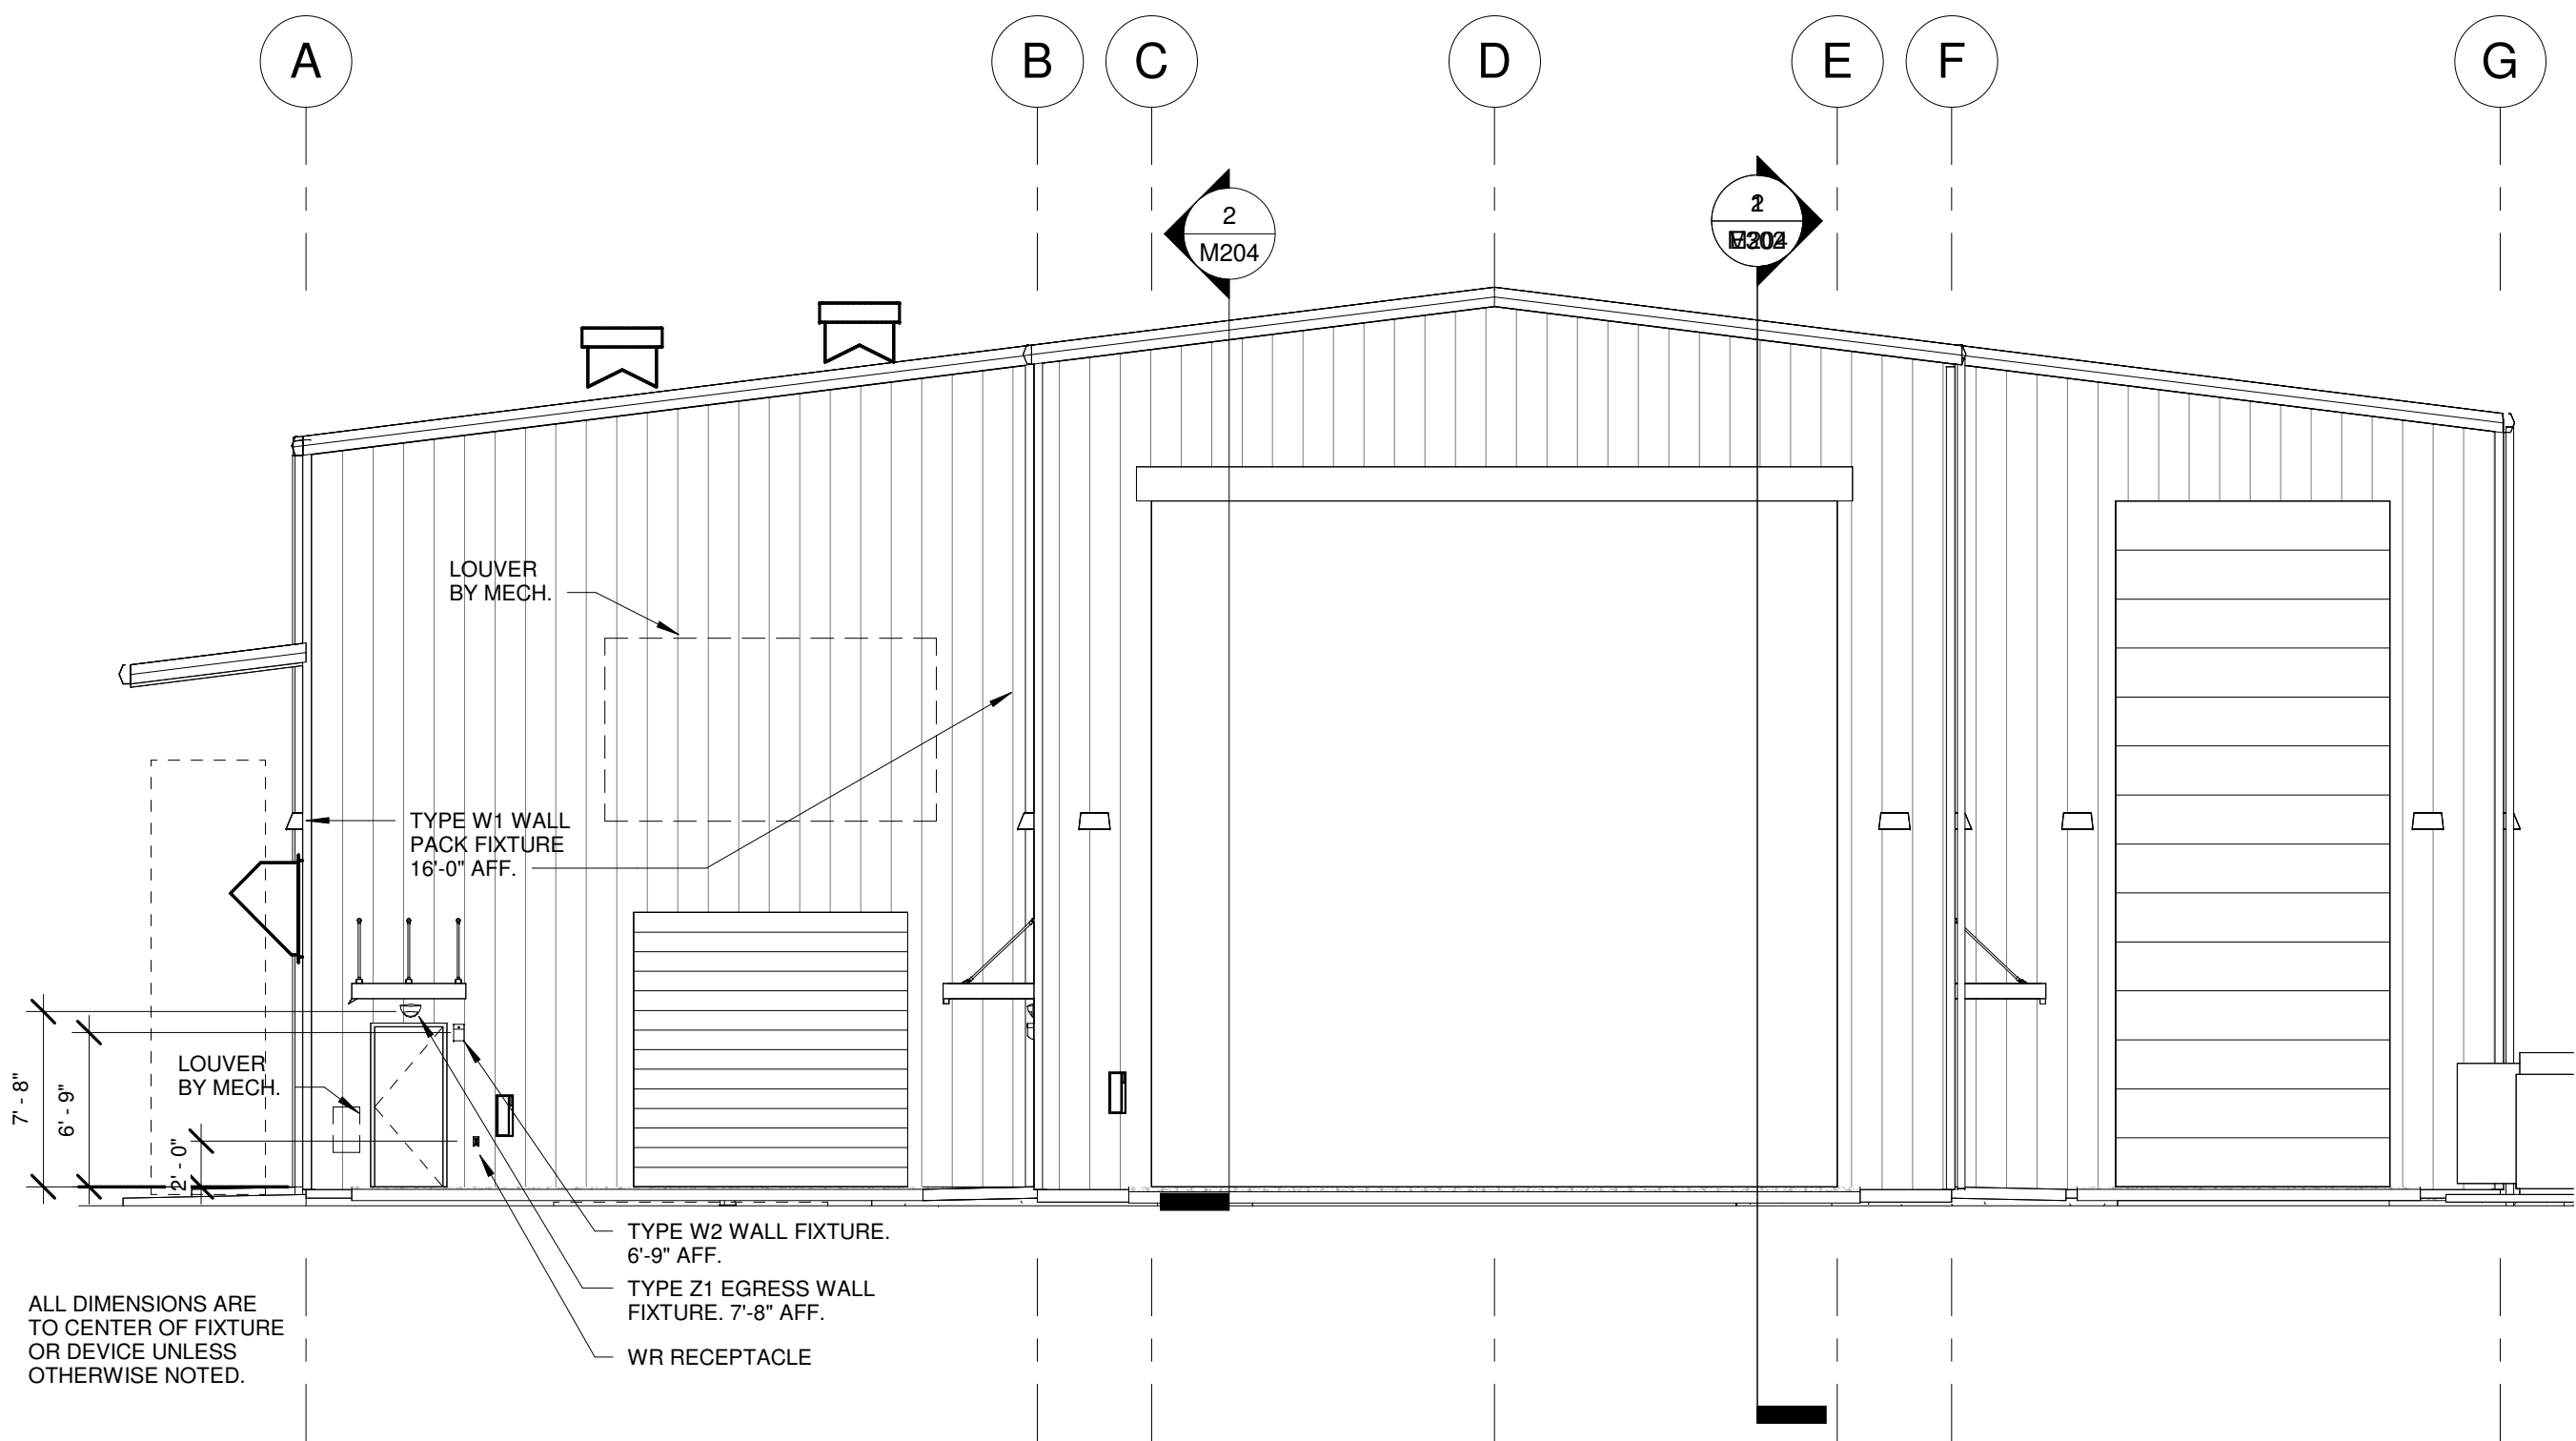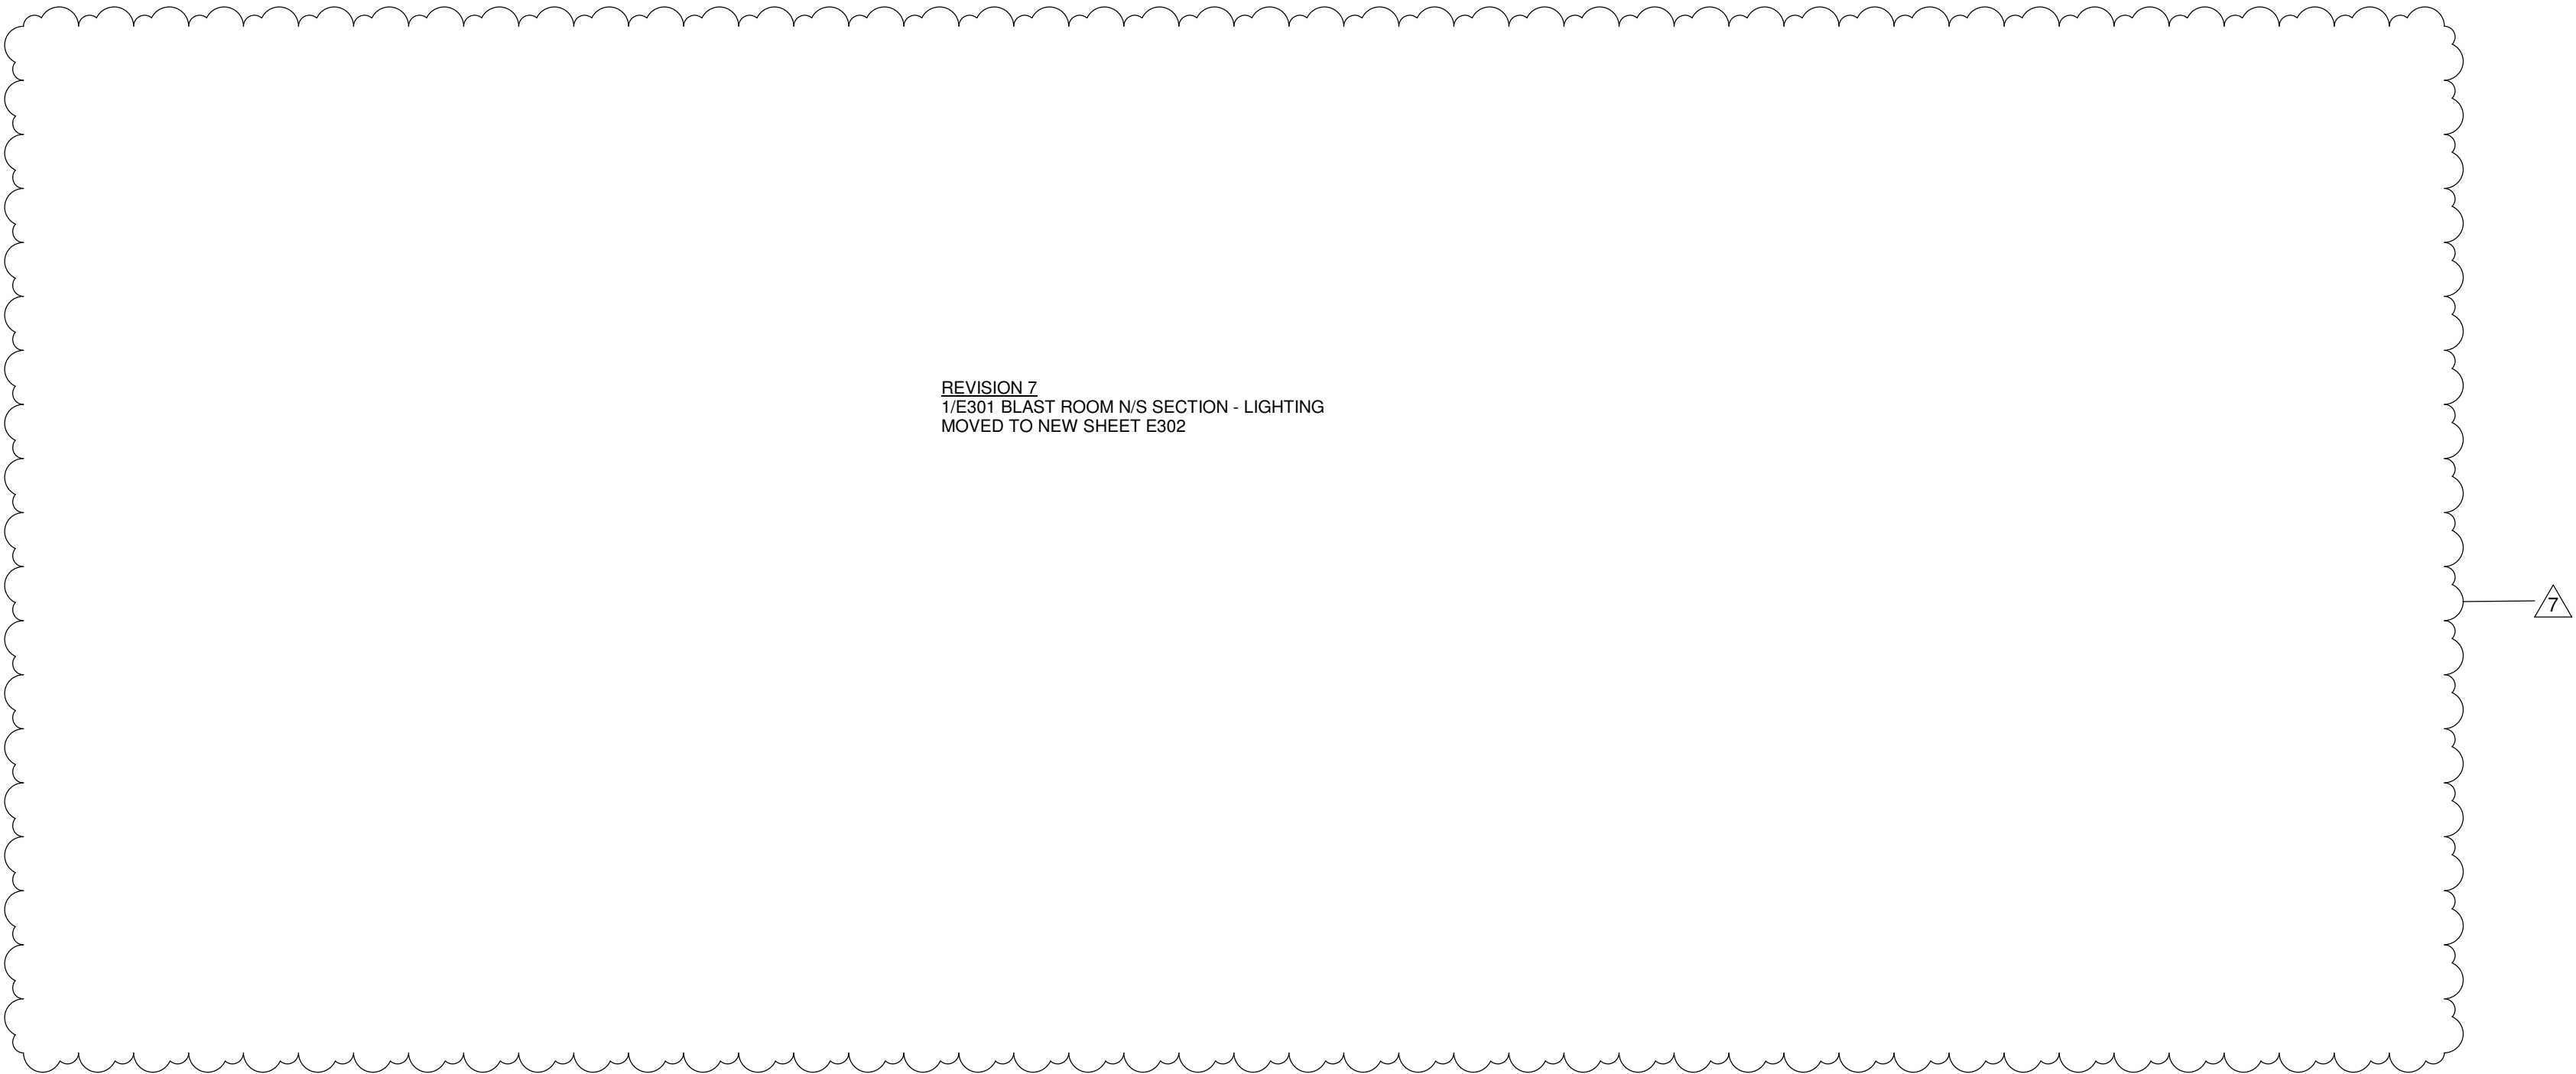

BUILDING SOUTH ELEVATION - LIGHTING
2
E301 1/8" = 1'-0"

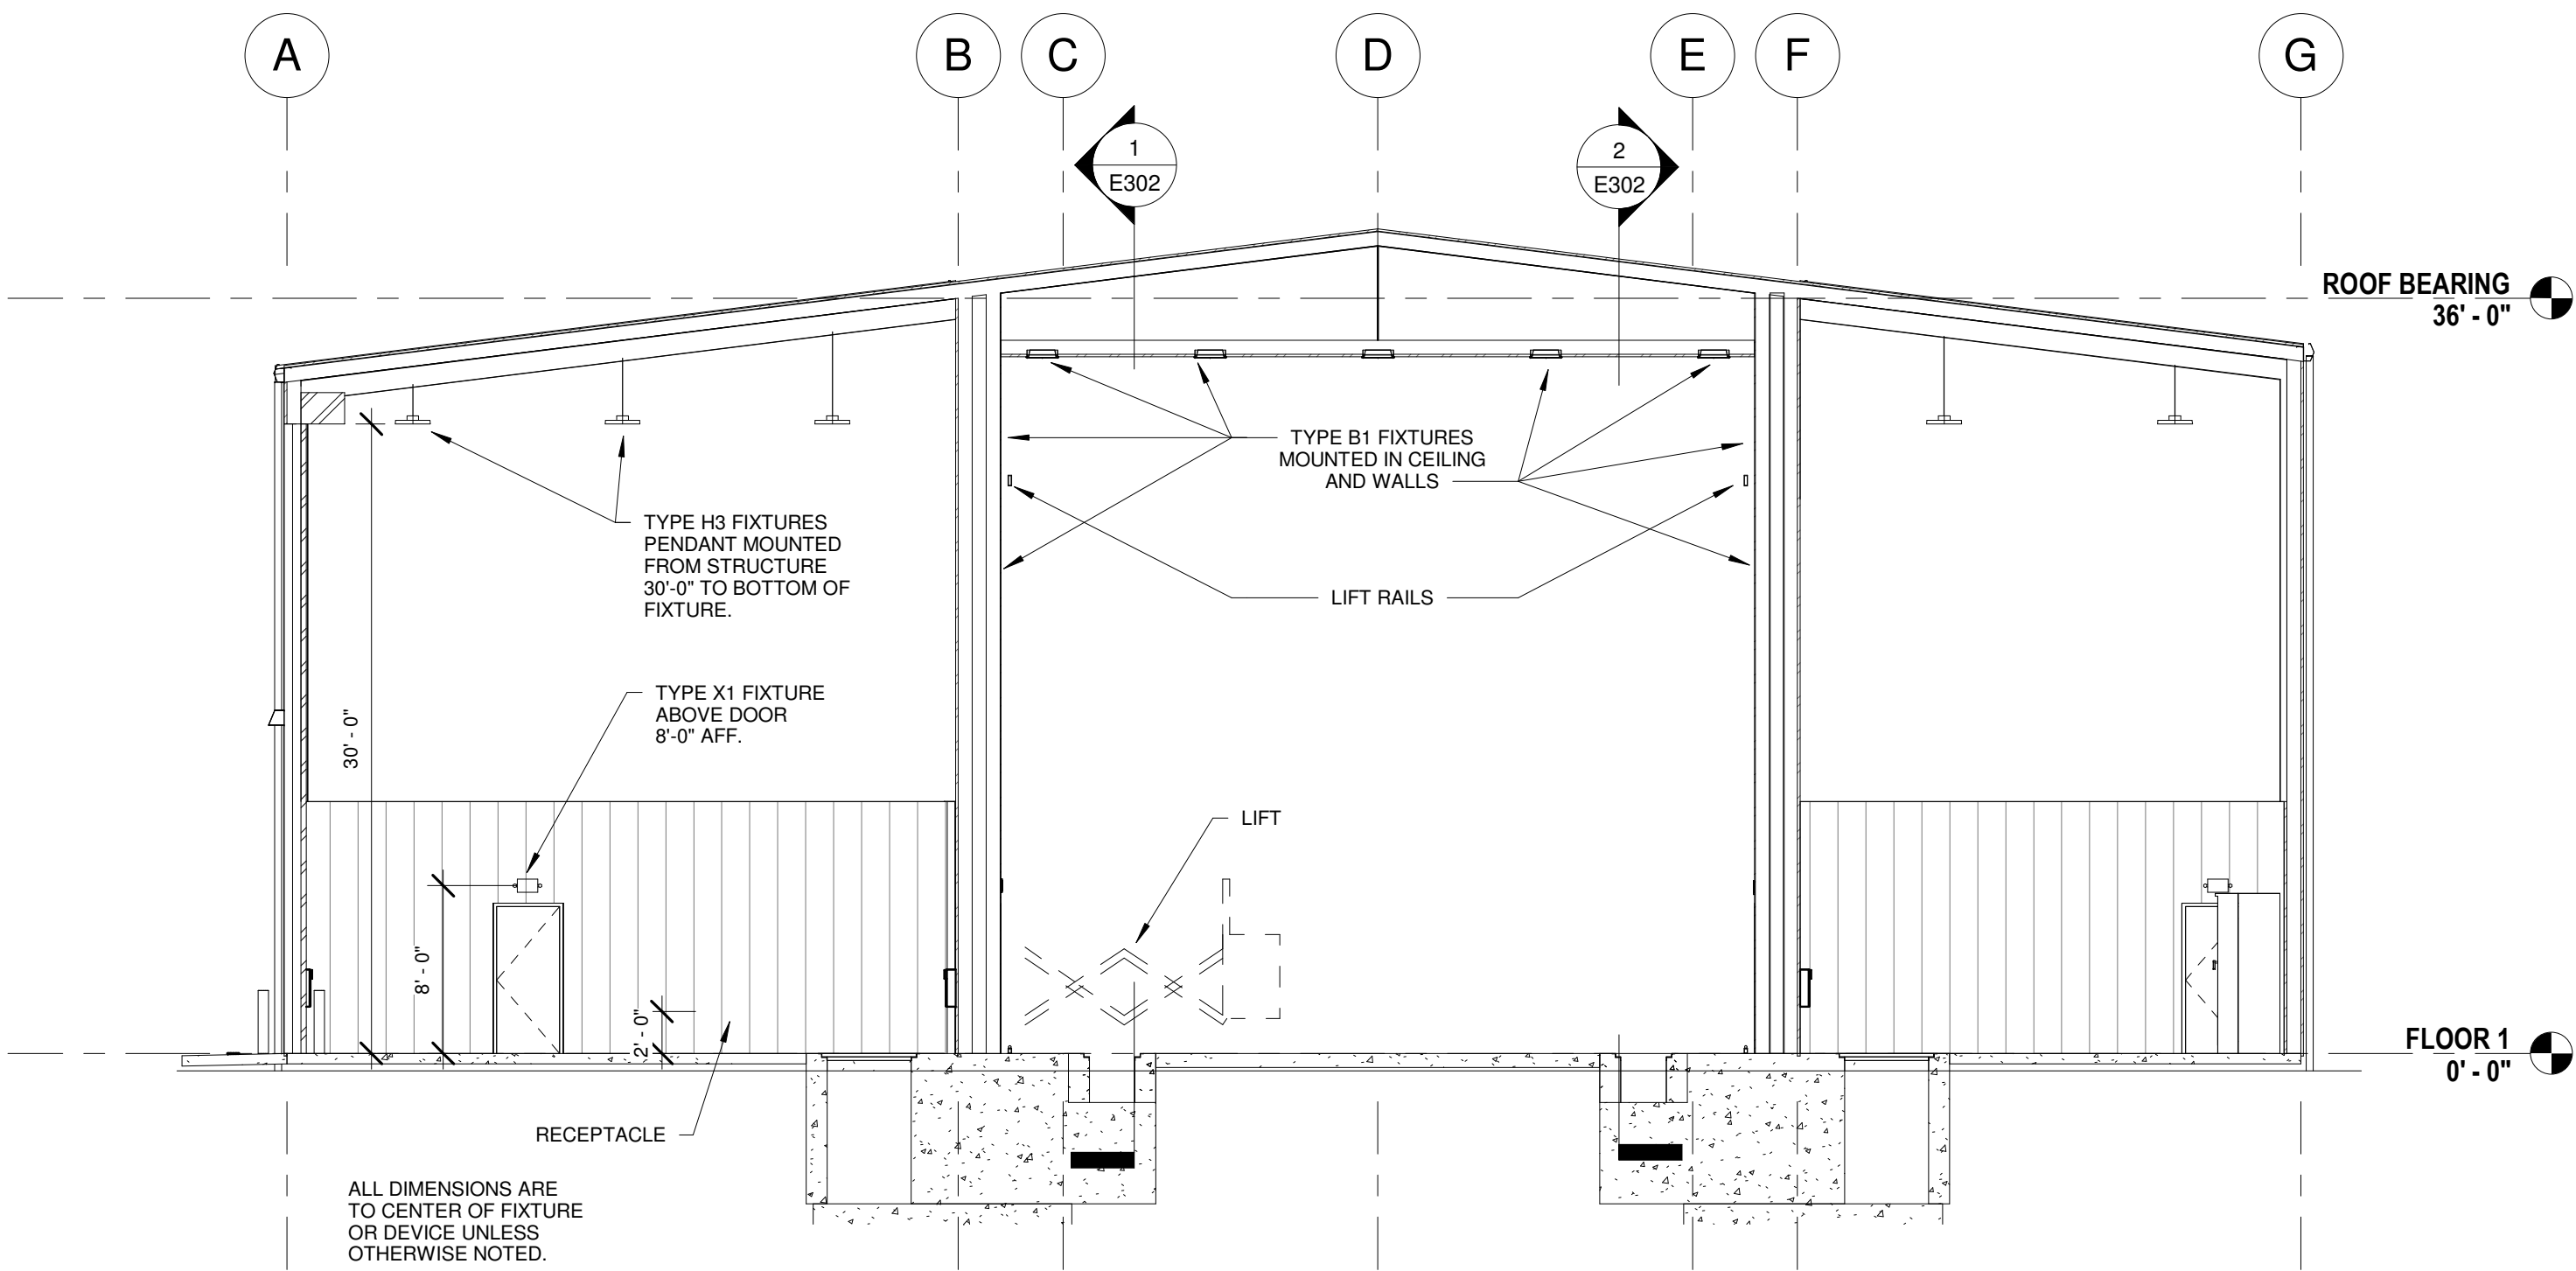

BUILDING SECTION - LIGHTING
3
E301 1/8" = 1'-0"

REVISION 1: MINOR GRAPHICAL ADJUSTMENTS TO DIMENSIONS AND NOTES.

