


4/24/2026 2:20:00 PM Autodesk Docs/Baxter and Vantive- Mountain Home/BAXTER_VANTIVE_Master Base File_ARCH_1/25.vnt

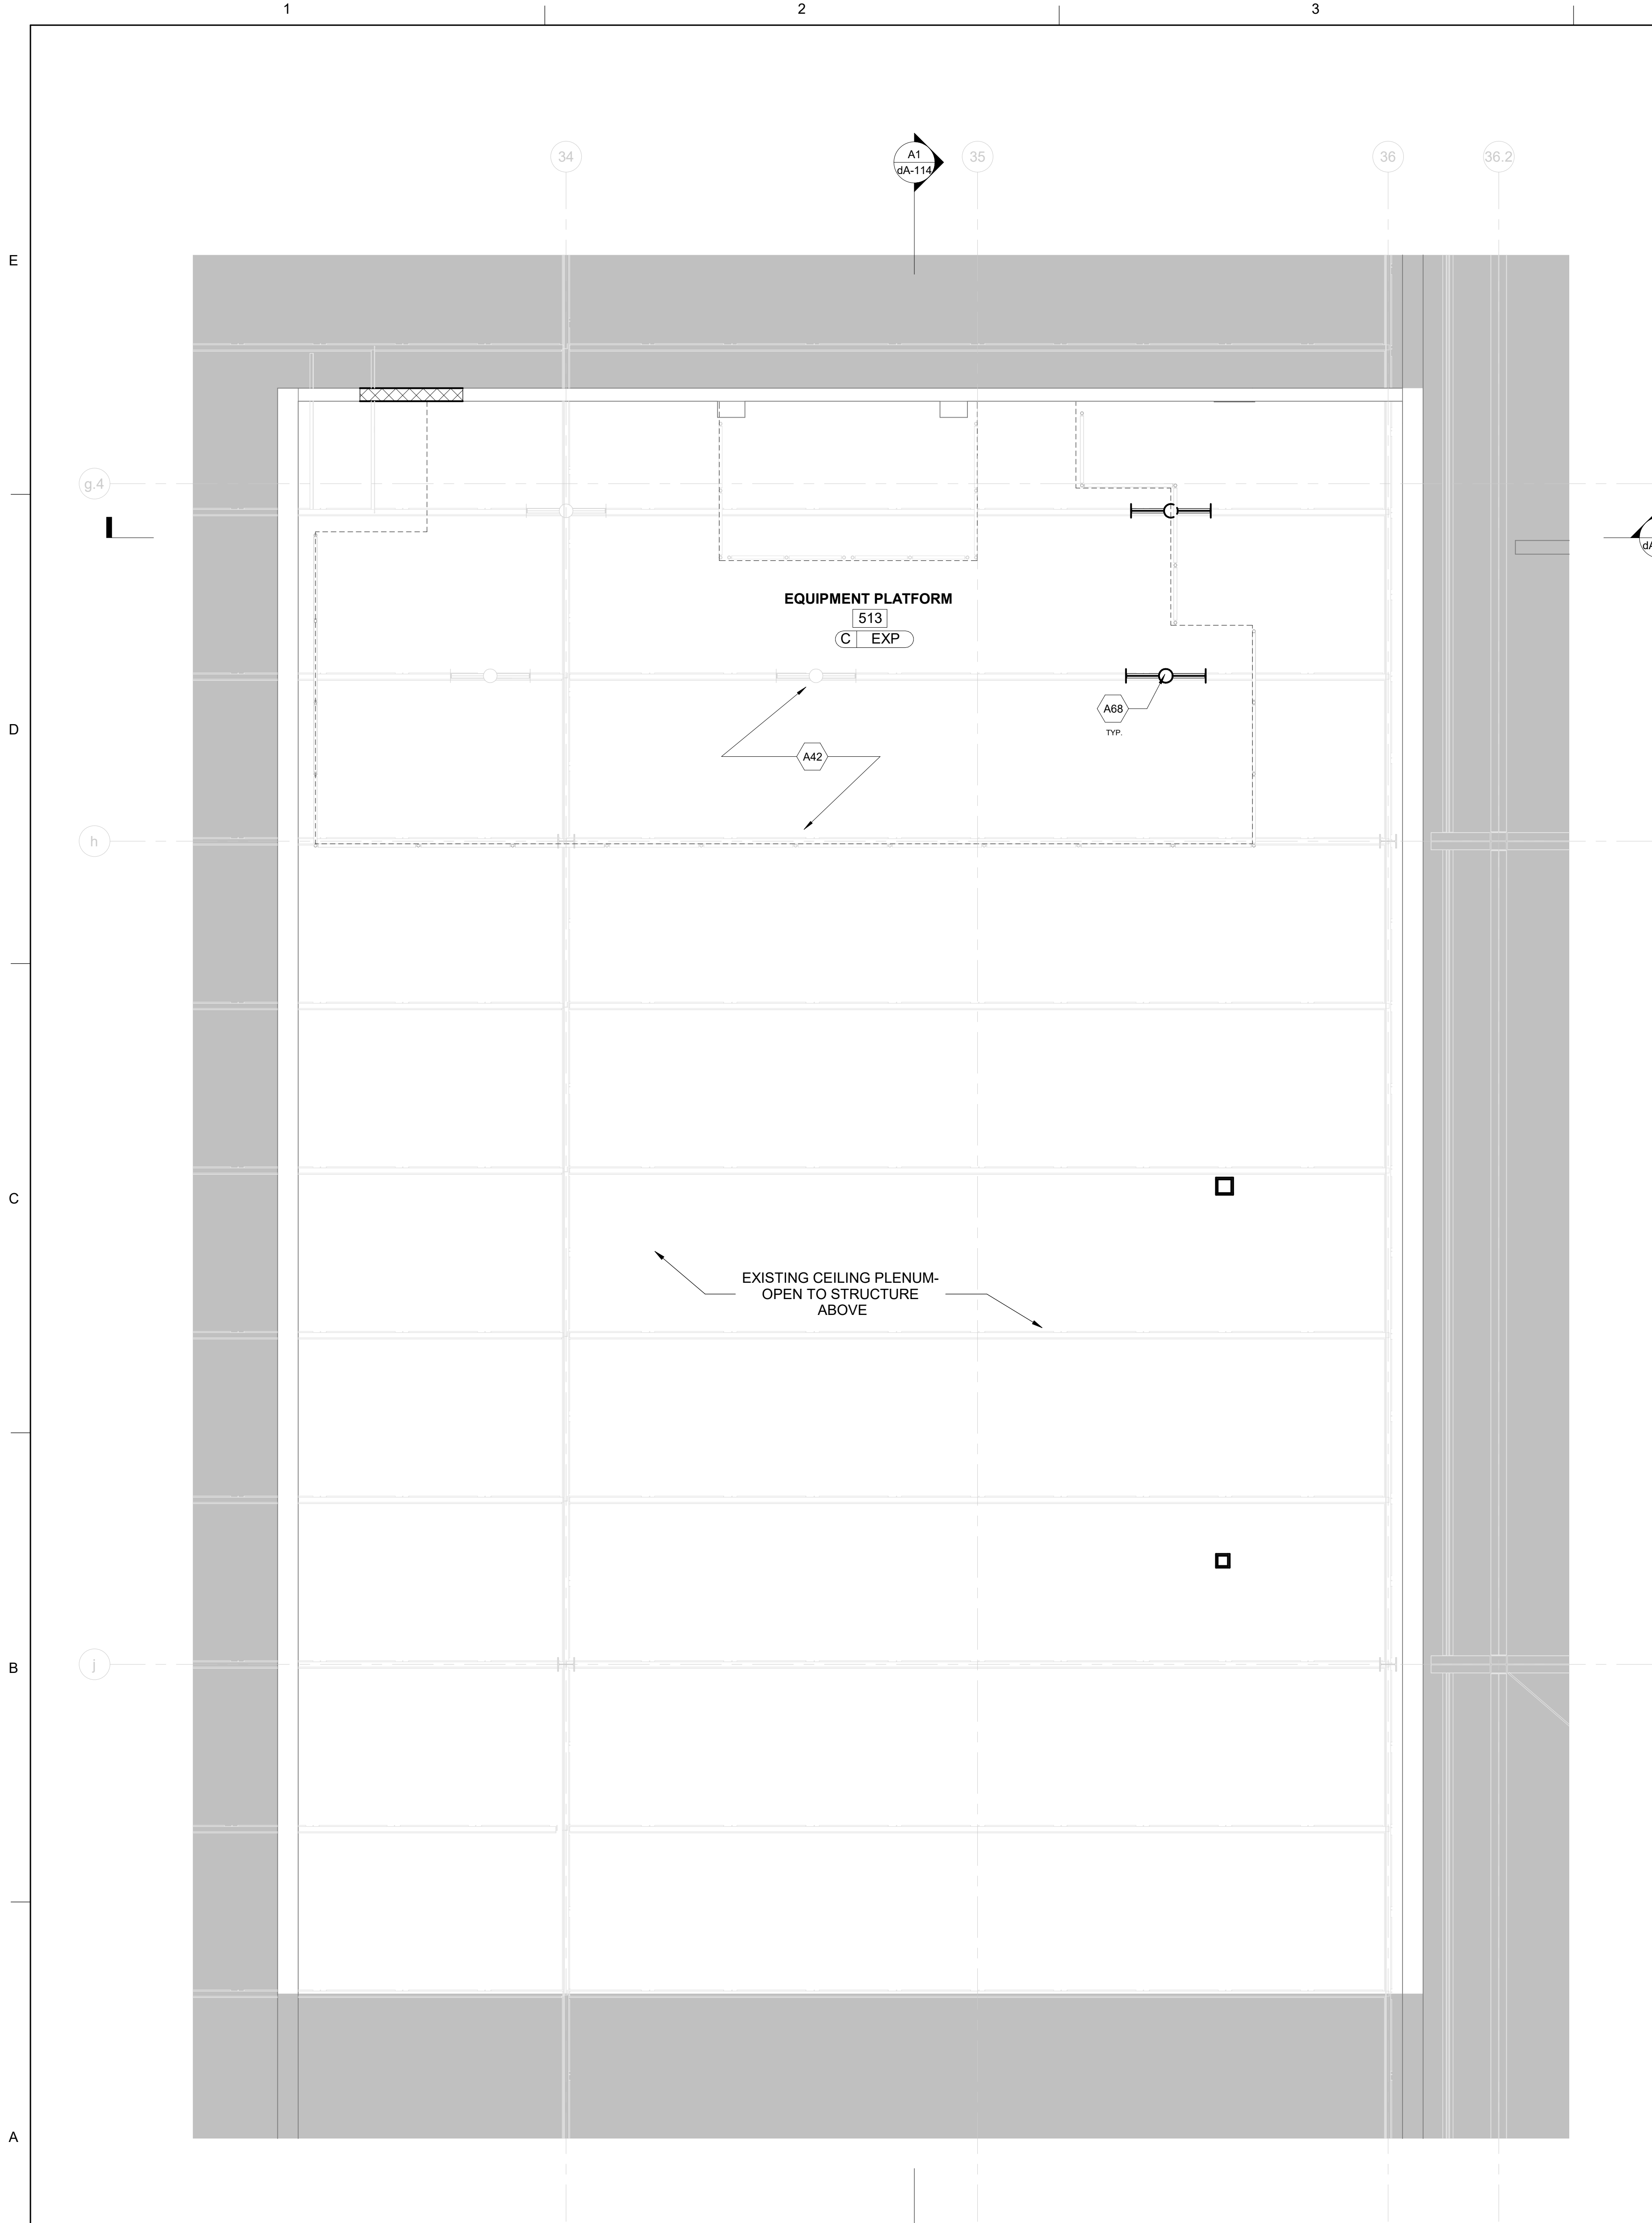

A1 AREA 510 - EQUIPMENT PLATFORM - RCP

SCALE: 1/4" = 1'-0"

SHEET NOTES


1. ALL MATERIAL EXPOSED WITHIN A RETURN AIR CEILING PLENUM SHALL BE NONCOMBUSTIBLE OR SHALL BE LIMITED IN COMBUSTIBILITY AND HAVE A FLAME SPREAD INDEX OF 25 MAX. AND A SMOKE- DEVELOPMENT INDEX OF 50 MAX., PER ASTM E84.
2. ALL CEILING MOUNTED DEVICES SHALL BE CENTERED IN BOTH DIRECTIONS IN ACOUSTICAL CEILING PANELS U.N.O. CENTER SPRINKLER HEADS IN ACOUST. CEILING PANELS WHERE THEY OCCUR - COORDINATE THE LOCATION OF THE SPRINKLER HEADS WITH OTHER CEILING FIXTURES AND EQUIPMENT IN ALL CEILING. ENSURE THAT A SYMMETRICAL AND BALANCED ARRANGEMENT IS INSTALLED.
3. CEILING HEIGHTS INDICATED (I.E. 9'-0") ARE RELATIVE TO THE FINISH FLOOR ELEVATION OF THE ROOM FOR WHICH THEY ARE INDICATED.
4. CEILING GRIDS SHALL BE ORIENTED WITHIN SPACES AS SHOWN, U.N.O. FULL TILE (FT) WHERE INDICATED, SHALL ABUT DESIGNATED WALL. LIMIT PARTIAL PANELS TO NO LESS THAN 6".
5. DEVICES HAVE BEEN SHOWN FOR COORDINATION PURPOSES. ALL DEVICES MAY NOT BE SHOWN.
6. ENSURE THE INSTALLATION OF ALL DEVICES INDICATED ON THE ENGR. DWG. SEE OTHER DISCIPLINES DRAWINGS FOR ITEMS NOT SHOWN ON REFLECTED CEILING PLANS. CONTACT THE ARCHITECT IF ANY CONFLICTS OCCUR.
7. COORDINATE ACCESS PANELS WITH MECHANICAL BALANCING DAMPER LOCATIONS.

KEYNOTES

- | | |
|-----|---|
| A42 | SEE ELECTRICAL DRAWINGS FOR EXISTING AND PROPOSED LIGHT FIXTURES IN ALL SPACES. |
| A68 | INSTALL PENDANT LIGHT FIXTURES AT THE SAME HEIGHT AS THE EXISTING PENDANTS. |

SHEET LEGEND

- | | |
|--|---|
| | EXISTING 1' X 4' PENDANT LIGHT FIXTURE |
| | 1' X 4' PENDANT LIGHT FIXTURE |
| | 24" X 48" MECH. DIFFUSERS |
| | 24" X 24" MECH. RETURN AIR GRILLES |
| | EXISTING 2'X4' LIGHTING TO REMAIN |
| | WALL MOUNTED EXIT SIGN |
| | CEILING MOUNTED EXIT SIGN |
| | EXP EXPOSED TO STRUCTURE - CEILING DRYFALL B42W1 (PAINT TO MATCH EXISTING) |
| | ETR CEILING TO REMAIN - PATCH AND REPAIR AS REQUIRED TO MAINTAIN IN CURRENT CONDITION |
| | B1 2'-0" X 4'-0" CLEAN ROOM ACOUSTICAL CEILING SYSTEM. BOD: ARMSTRONG CLEAN ROOM FL/VL LAY-IN TILE SYSTEM |

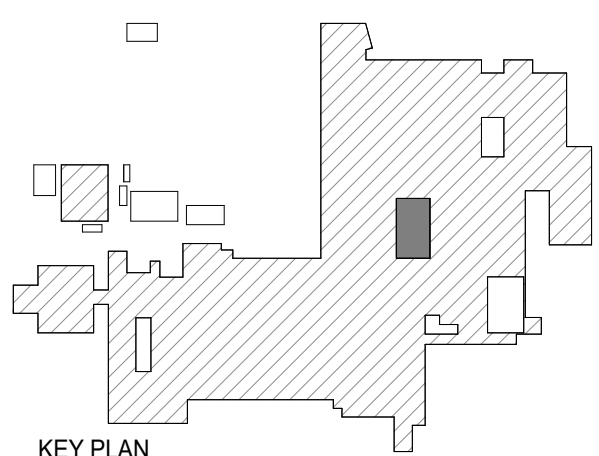

3500 Parkway Lane
Suite 500
Peachtree Corners
Georgia 30092

Copyright © 2025 by Pond & Company. All rights reserved. No copying or duplication of these documents is allowed without the expressed written agreement of Pond & Company.

EOR/AOR SEAL

COA SEAL

CLIENT INFORMATION

Vantive

PROJECT NAME

**VANTIVE TUBING
CLEAN ROOM**

1900 AR-201
MOUNTAIN HOME,
ARKANSAS 72653

DRAWING ISSUE

24APR/26	27FEB/26	27FEB/26	14NOV/25
DATE	DATE	DATE	DATE

ISSUED FOR BID, EQ BID CLARIFICATIONS	ISSUED FOR BID CLARIFICATIONS	ISSUED FOR REVIEW DESCRIPTION
--	----------------------------------	----------------------------------

G D O B MARK

DESIGNED BY:	TB
DRAWN BY:	MP
CHECKED BY:	JS
SUBMITTED BY:	JM
DATE:	04/24/2026
PROJECT #:	1241011

SHEET TITLE

**AREA 510 -
EQUIPMENT
PLATFORM - RCP**

SHEET NUMBER

dA-112

ORIGINAL SHEET SIZE:
36" X 42"

ISSUED FOR BID