

1

2

3

4

5

6

SHEET NOTES

- ALL MATERIAL EXPOSED WITHIN A RETURN AIR CEILING PLENUM SHALL BE NONCOMBUSTIBLE OR SHALL BE LIMITED IN COMBUSTIBILITY AND HAVE A FLAME SPREAD INDEX OF 25 MAX. AND A SMOKE-DEVELOPMENT INDEX OF 50 MAX., PER ASTM E84.
- ALL CEILING MOUNTED DEVICES SHALL BE CENTERED IN BOTH DIRECTIONS IN ACOUSTICAL CEILING PANELS U.N.O. CENTER SPRINKLER HEADS IN ACOUST. CEILING PANELS WHERE THEY OCCUR - COORDINATE THE LOCATION OF THE SPRINKLER HEADS WITH OTHER CEILING FIXTURES AND EQUIPMENT IN ALL CEILING. ENSURE THAT A SYMMETRICAL AND BALANCED ARRANGEMENT IS INSTALLED.
- CEILING HEIGHTS INDICATED (I.E. 9'-0") ARE RELATIVE TO THE FINISH FLOOR ELEVATION OF THE ROOM FOR WHICH THEY ARE INDICATED.
- CEILING GRIDS SHALL BE ORIENTED WITHIN SPACES AS SHOWN, U.N.O. FULL TILE (FT) WHERE INDICATED, SHALL ABUT DESIGNATED WALL. LIMIT PARTIAL PANELS TO NO LESS THAN 6". DEVICES HAVE BEEN SHOWN FOR COORDINATION PURPOSES. ALL DEVICES MAY NOT BE SHOWN.
- ENSURE THE INSTALLATION OF ALL DEVICES INDICATED ON THE ENGR. DWG. SEE OTHER DISCIPLINES DRAWINGS FOR ITEMS NOT SHOWN ON REFLECTED CEILING PLANS. CONTACT THE ARCHITECT IF ANY CONFLICTS OCCUR.
- COORDINATE ACCESS PANELS WITH MECHANICAL BALANCING DAMPER LOCATIONS.



KEYNOTES

KEY #	KEYNOTE DESCRIPTION
A39	2X4 LIGHT FIXTURES IN DROP DOWN ACT CEILING GRID, TYP.
A42	SEE ELECTRICAL DRAWINGS FOR EXISTING AND PROPOSED LIGHT FIXTURES IN ALL SPACES.
A68	INSTALL PENDANT LIGHT FIXTURES AT THE SAME HEIGHT AS THE EXISTING PENDANTS.


SHEET LEGEND

	LED STRIP LIGHT
	1' X 4' PENDANT LIGHT FIXTURE
	WALL MOUNTED LIGHT FIXTURE
	2' X 4' LAY-IN LIGHT FIXTURE
	LED WALL LUMINAIRE
	2' X 4' MECH. HEPA FILTERS
	2' X 2' MECH. RETURN AIR GRILLES
	WALL MOUNTED EXIT SIGN
	CEILING MOUNTED EXIT SIGN
	2'-0" X 4'-0" ACOUSTICAL CEILING SYSTEM: ARMSTRONG CEILINGS, ULTIMA REGULAR 1944, 15/16" GRID, COLOR: WHITE, SIZE 24"x48"
	2'-0" X 4'-0" ACOUSTICAL CEILING SYSTEM: ARMSTRONG CEILINGS, CLEAN ROOM EA7903 1-1/2" GRID, CEILING TILES #3115, COLOR: WHITE, SIZE 24" X 48"
EXP	EXPOSED TO STRUCTURE; PAINT
ETR	EXISTING CEILING TO REMAIN - PATCH AND REPAIR AS REQUIRED TO MAINTAIN IN CURRENT CONDITION
	NOT IN SCOPE

FIRE SPRINKLER HEAD LOCATIONS

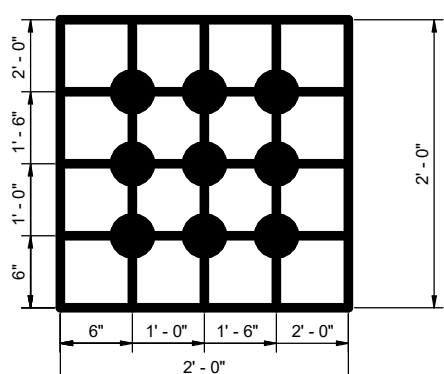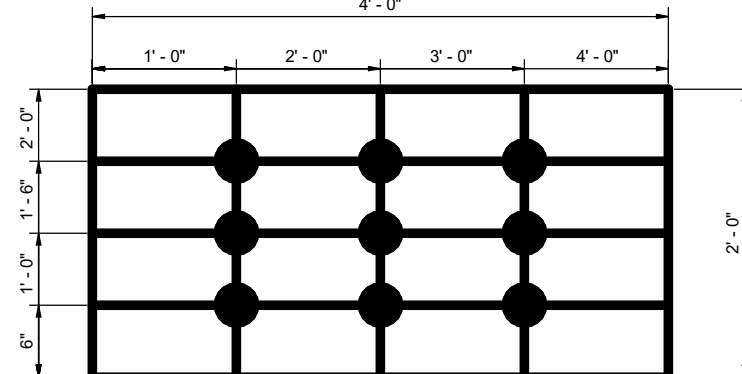

NOTES:
1. SPRINKLER HEADS SHALL BE LOCATED IN THE CENTER OF ALL CEILING TILES WHERE POSSIBLE.
2. WHEN REQUIRED DUE TO CONFLICTS OR ODD SIZED ROOMS, SPRINKLERS SHALL BE PERMITTED TO BE INSTALLED IN THE QUARTER POINTS AS SHOWN IN THIS DETAIL.

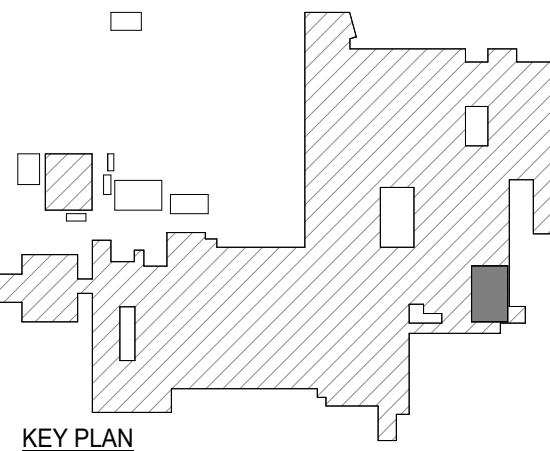

SCALE: 1/4" = 1'-0"

POND

3500 Parkway Lane
Suite 500
Peachtree Corners
Georgia 30092

Copyright © 2025 by Pond & Company. All rights reserved. No copying or duplication of these documents is allowed without the expressed written agreement of Pond & Company.

EOR/AOR SEAL

COA SEAL

CLIENT INFORMATION

Vantive

PROJECT NAME

**VANTIVE TUBING
CLEAN ROOM**

1900 AR-201
MOUNTAIN HOME,
ARKANSAS 72653

DRAWING ISSUE

24APRIL26	27FEB26	24APR26	14NOV26
DATE	DATE	DATE	DATE

ISSUED FOR BID	EQ BID	ISSUED FOR BID	ISSUED FOR BID	ISSUED FOR BID	DESCRIPTION
G	D	D	B	MARK	

DESIGNED BY: TB
DRAWN BY: MP
CHECKED BY: JS
SUBMITTED BY: JM
DATE: 04/24/2026
PROJECT #: 1241011

SHEET TITLE

**AREA 565 - LEVEL
1 - RCP**

SHEET NUMBER

dA-141ORIGINAL SHEET SIZE:
36" X 42"

ISSUED FOR BID

1


2

3

4

5

6

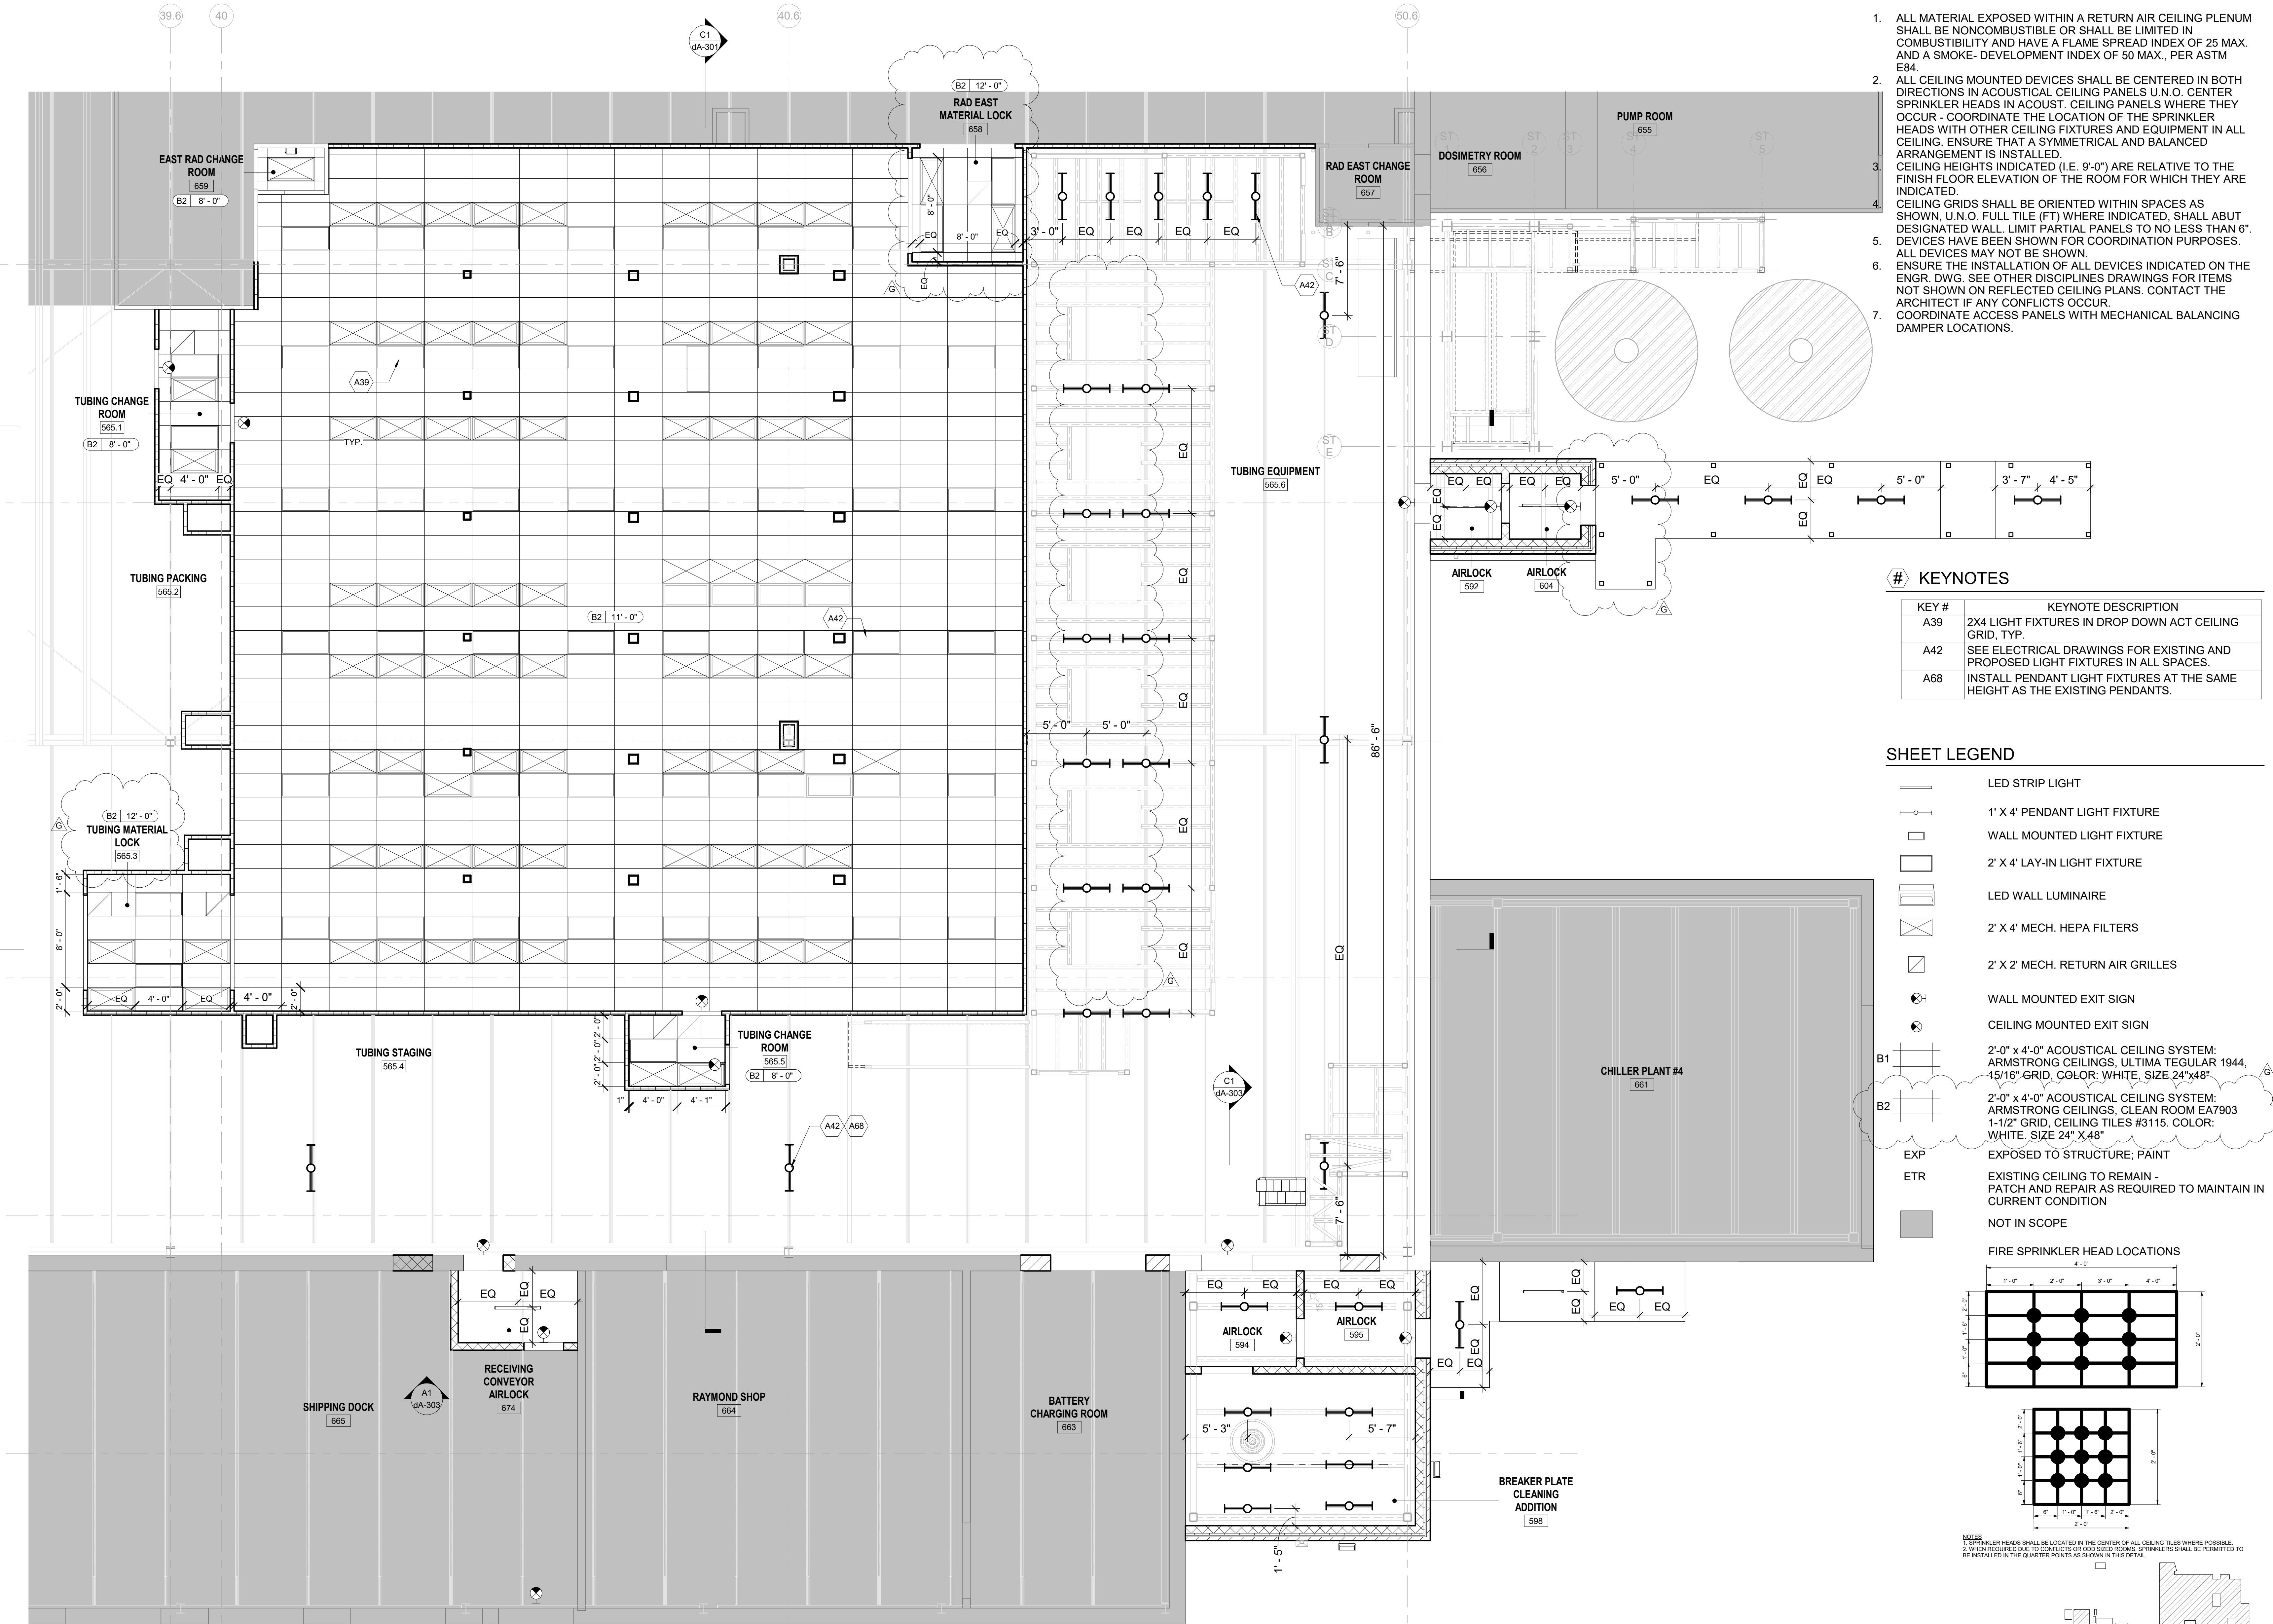**A1 AREA 565 - LEVEL 1 - RCP**

SCALE: 3/16" = 1'-0"