

1

2

3

4

5

6

SHEET NOTES

- SEE SHEET A-001 FOR GENERAL NOTES, SYMBOLS AND MATERIALS.
- REFER TO OTHER DISCIPLINES DRAWINGS FOR THE LOCATION OF ALL MEP WORK, INCLUDING BUT NOT LIMITED TO LIGHTS, DIFFUSERS, PIPES AND DUCTWORK. ELEVATIONS GIVEN ARE RELATIVE TO GROUND LEVEL T.O. SLAB (0'-0"). SEE CIVIL FOR HEIGHT ABOVE SEA LEVEL. SEE PLANS AND WALL SECTIONS FOR ROUGH OPENING LOCATIONS.

KEYNOTES

KEY #	KEYNOTE DESCRIPTION
A30	OVERHEAD DOOR, SEE DOOR SCHEDULE.
A47	42" HIGH GALV. STEEL PIPE GUARDRAILS WITH 4'-0" MAX POST SPACING AND 36" HIGH HANDRAIL. 1-1/2" THICK. SEE STRUCTURAL DRAWINGS FOR MOUNTING DETAILS.
A50	ACT CEILING.
A53	SEE ELECTRICAL DRAWINGS FOR EXISTING AND PROPOSED LIGHT FIXTURES.
A68	INSTALL PENDANT LIGHT FIXTURES AT THE SAME HEIGHT AS THE EXISTING PENDANTS.
A70	ALL HVAC DUCTWORK, WIREWAYS, UTILITY PIPING, MISCELLANEOUS EQUIPMENT ETC. SHOULD BE INSTALLED ABOVE 17'-6" AFF TO ALLOW FOR CEILING TO BE RAISED TO 17'-0" IN THE FUTURE.

SHEET LEGEND

	AREA ABOVE DROPPED CEILING TO BE LEFT EMPTY FROM HORIZONTAL MISCELLANEOUS PIPING AND EQUIPMENT.
--	---

POND3500 Parkway Lane
Suite 500
Peachtree Corners
Georgia 30092

Copyright © 2025 by Pond & Company. All rights reserved. No copying or duplication of these documents is allowed without the expressed written agreement of Pond & Company.

EOR/AOR SEAL

COA SEAL

CLIENT INFORMATION

Vantive

PROJECT NAME

VANTIVE TUBING
CLEAN ROOM1900 AR-201
MOUNTAIN HOME,
ARKANSAS 72653

DRAWING ISSUE

24APRIL26
27FEB26
27FEB26
14NOV25
DATEISSUED FOR BID, EQ BID
CLARIFICATIONS
ISSUED FOR BID
ISSUED FOR REVIEW
DESCRIPTION

G D O B MARK


DESIGNED BY: TB
DRAWN BY: MP
CHECKED BY: JS
SUBMITTED BY: JM
DATE: 04/24/2026
PROJECT #: 1241011

SHEET TITLE

AREA 565 -
BUILDING
SECTIONS


SHEET NUMBER

dA-301

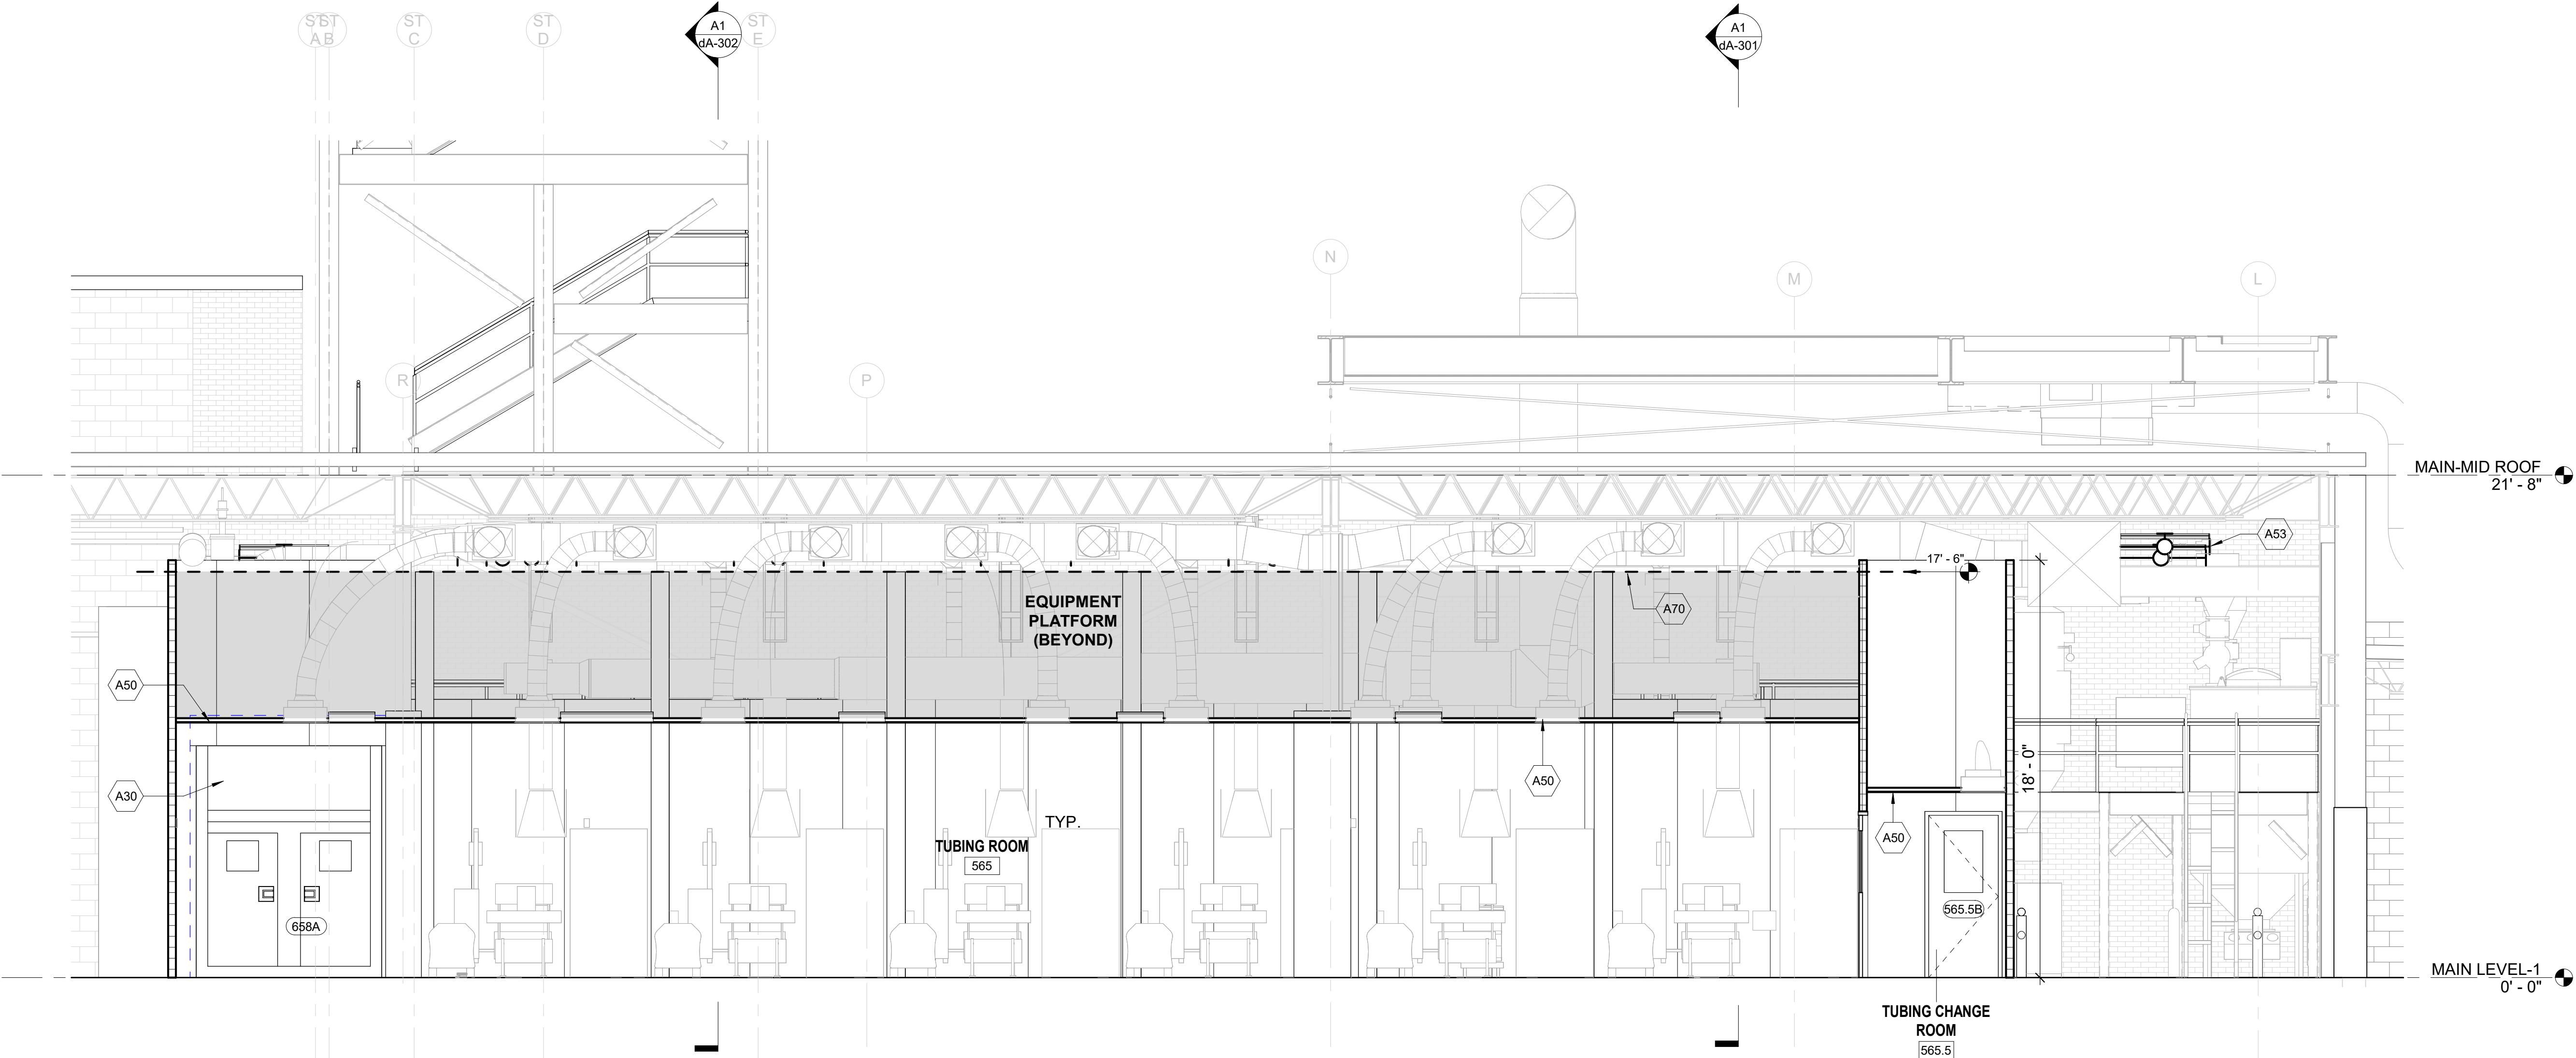ORIGINAL SHEET SIZE:
36" X 42"

C1 AREA 565 - SECTION 2

SCALE: 1/4" = 1'-0"

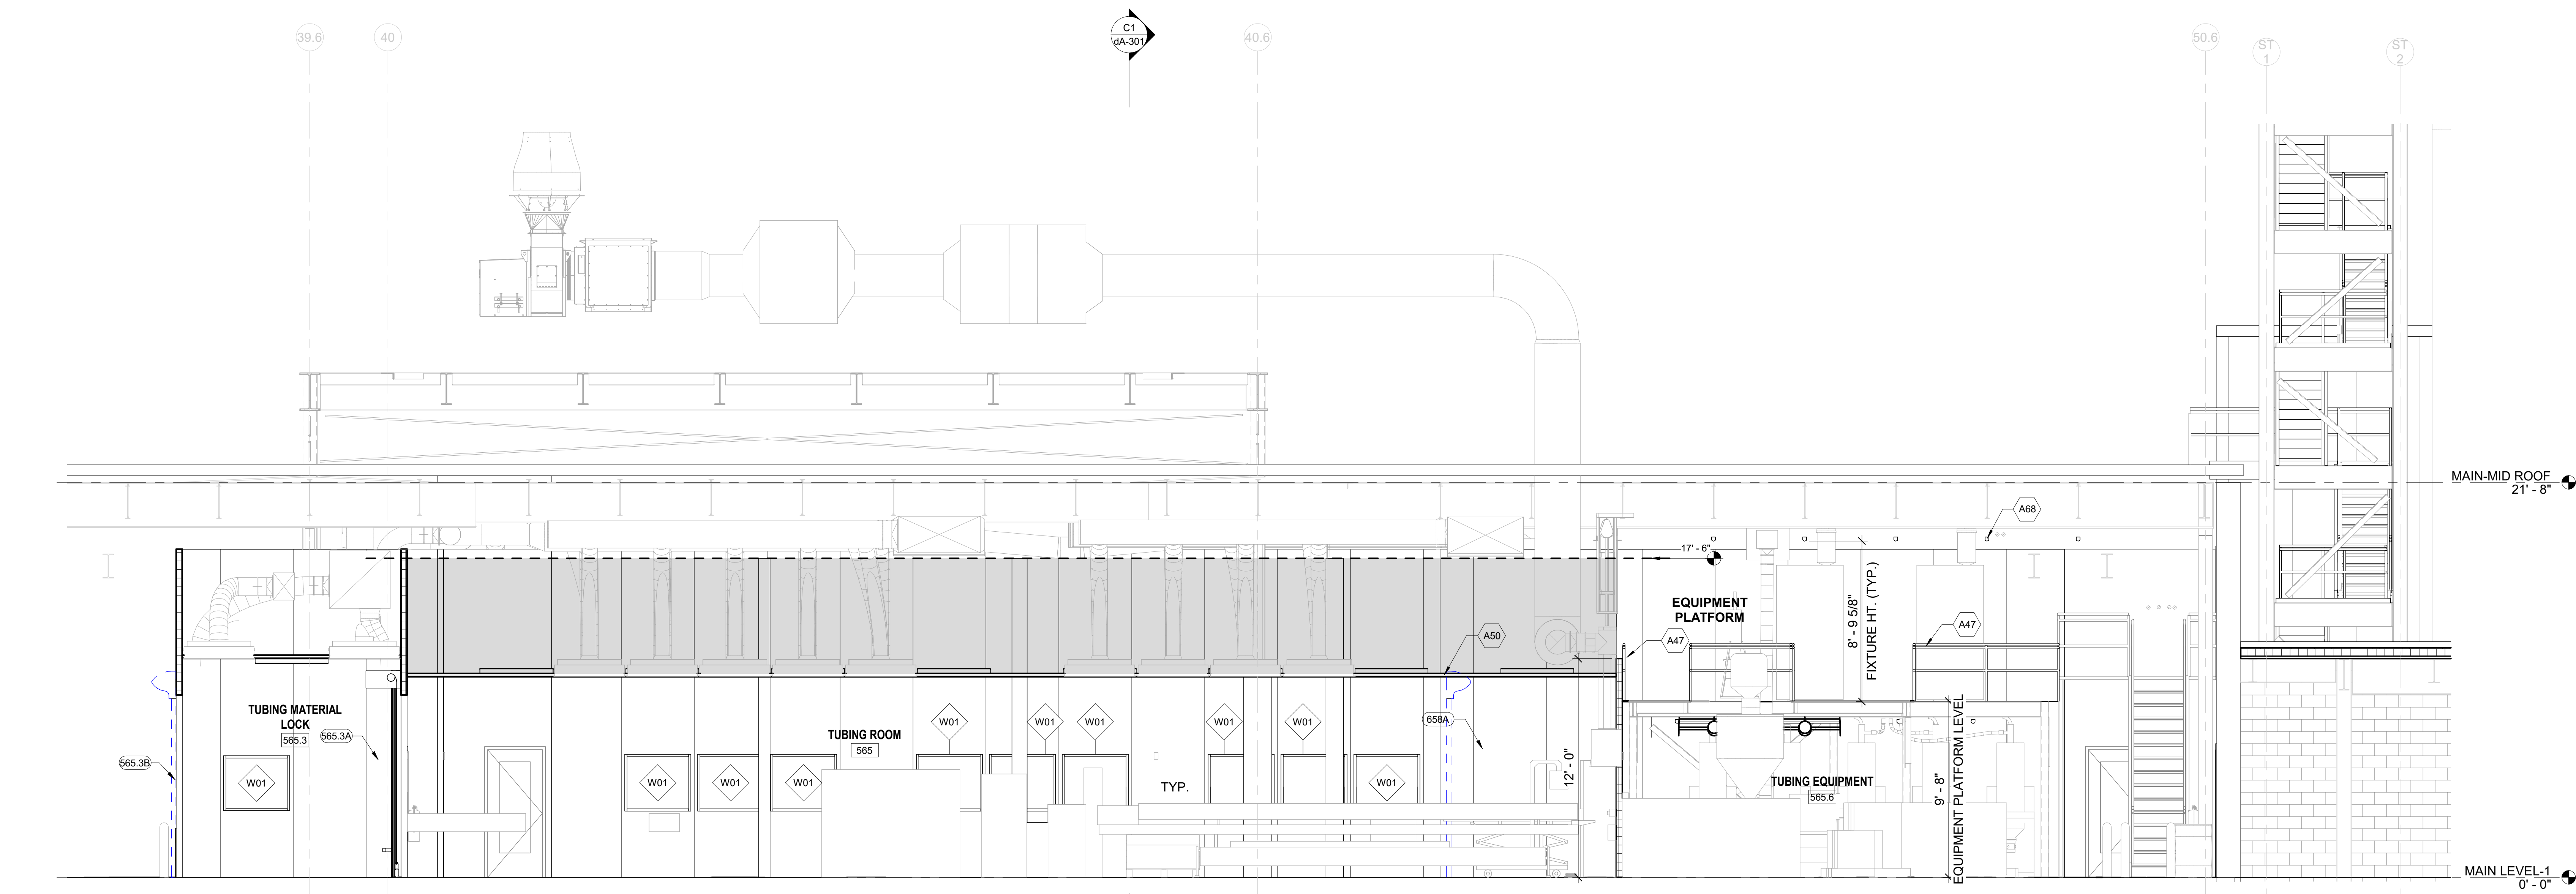

A1 AREA 565 - SECTION 1

SCALE: 1/4" = 1'-0"

0 2' 4' 8'
SCALE: 1/4" = 1'-0"

ISSUED FOR BID