



4/24/2026 3:31:08 PM Autodesk Docs/Baxter and Vantive - Mountain Home/Baxter_Vantive_Mountain Home/Baxter_Vantive_Mechanical - Master Base File_Mechanical - V25.rvt

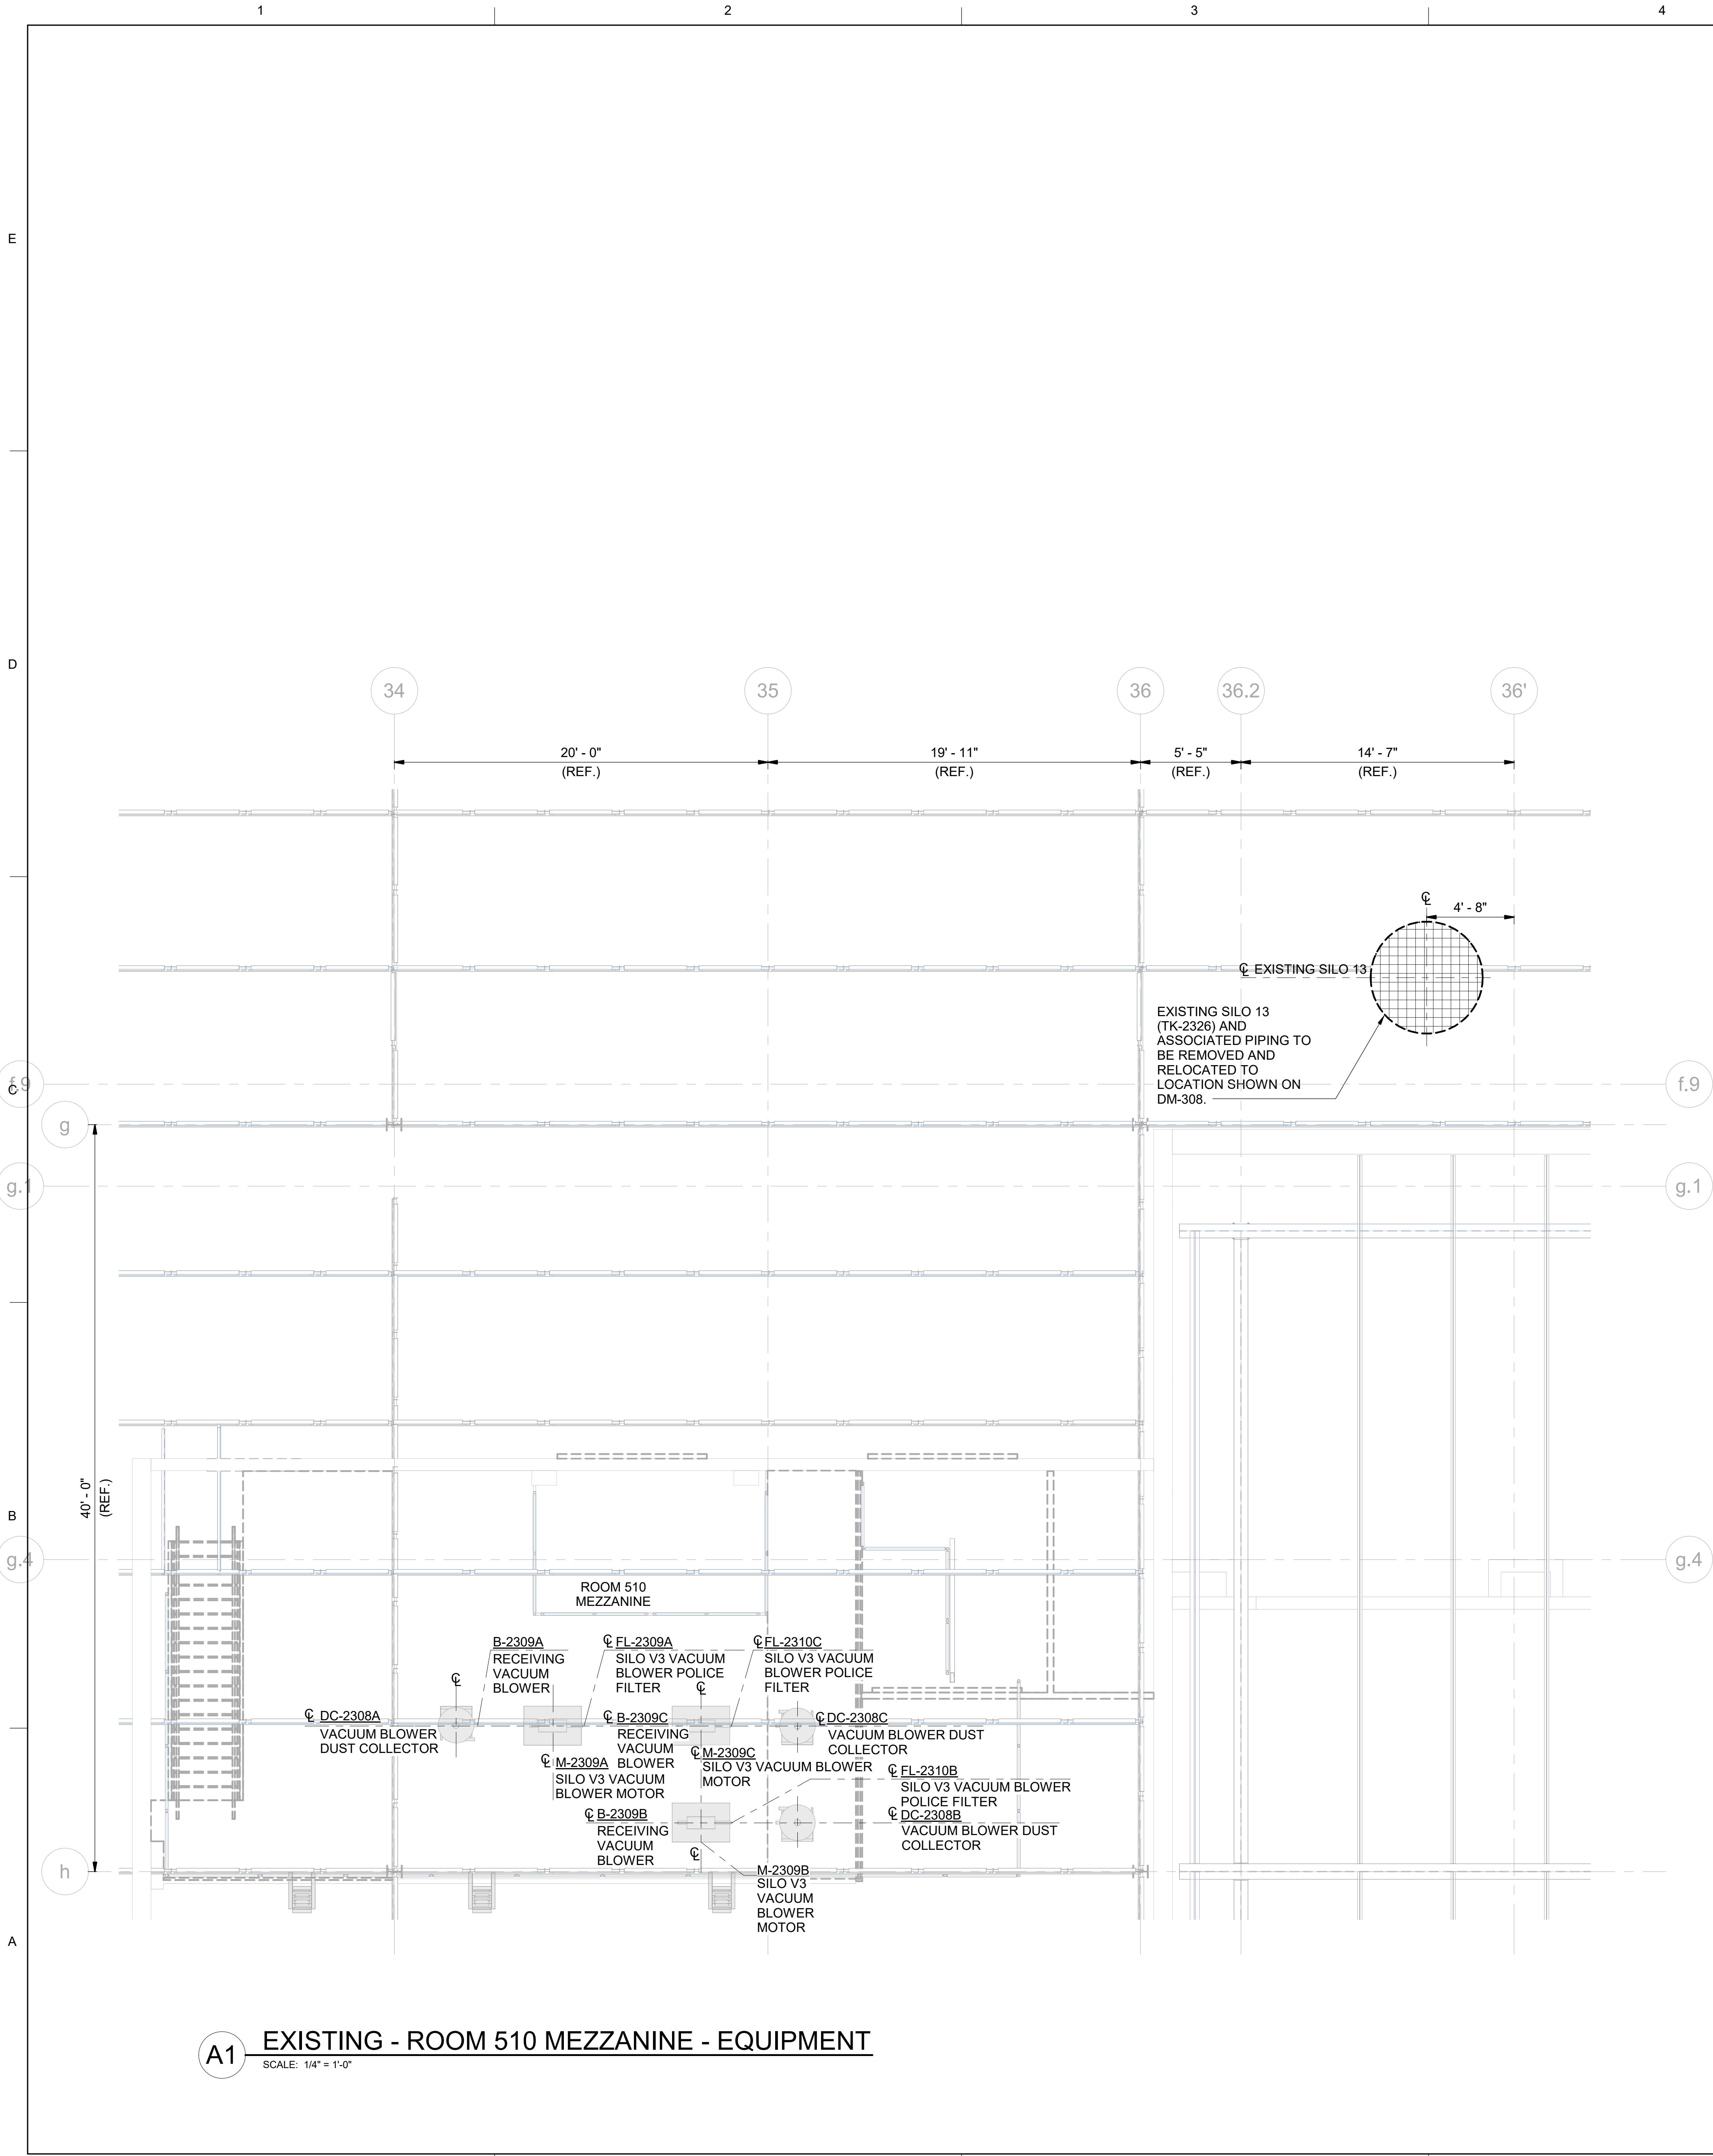

SHEET NOTES

1. REFER TO DM001 FOR PROCESS GENERAL NOTES AND DESIGN CRITERIA.
2. REFER TO DM002 FOR PROCESS ABBREVIATIONS AND LEGENDS.
3. REFER TO PROCESS FLOW DIAGRAMS FOR PROCESS INFORMATION
4. VACUUM BLOWERS AND DUST COLLECTORS TO REMAIN FOR REPURPOSING

LEGEND

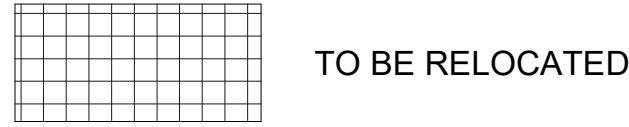

POND

3500 Parkway Lane
Suite 500
Peachtree Corners
Georgia 30092

Copyright © 2026 by Pond & Company. All rights reserved. No copying or duplication of these documents is allowed without the expressed written agreement of Pond & Company.

EOR/AOR SEAL

COA SEAL

CLIENT INFORMATION

Vantive

PROJECT NAME

**VANTIVE
TUBING
CLEAN ROOM**

1900 AR-201
MOUNTAIN HOME,
ARKANSAS 72653

DRAWING ISSUE

DATE	DESCRIPTION
04/24/2026	ISSUED FOR BID, EQ BID
01/23/2026	ISSUED FOR APPROVAL
10/03/2025	ISSUED FOR ESTIMATE

DATE	DESCRIPTION
04/24/2026	ISSUED FOR BID, EQ BID
01/23/2026	ISSUED FOR APPROVAL
10/03/2025	ISSUED FOR ESTIMATE

MARK	DESCRIPTION
D	DESIGNED BY: JC
C	CHECKED BY: JS
A	SUBMITTED BY: CL

DESIGNED BY: JC
DRAWN BY: JS
CHECKED BY: JC
SUBMITTED BY: CL
DATE: 04/24/2026
PROJECT #: 1241011


SHEET TITLE

**EXISTING - ROOM
510 MEZZANINE -
EQUIPMENT**

SHEET NUMBER

DM211

ORIGINAL SHEET SIZE:
30" X 42"

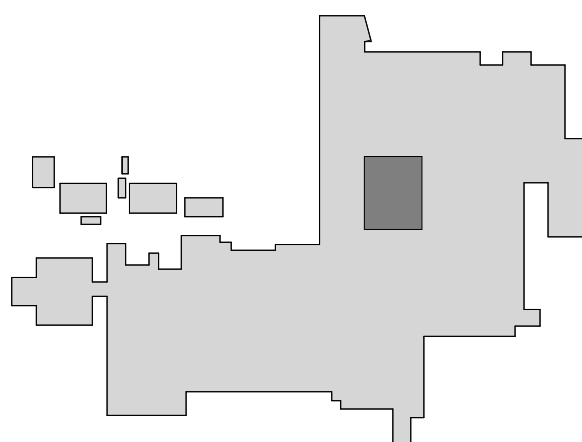

0 2' 4' 8'
SCALE: 1/4" = 1'-0"



ISSUED FOR BID