



4/24/2026 3:31:09 PM Autodesk Docs/Baxter and Vantive - Mountain Home/Baxter_Vantive_Mountain Home/Baxter_Vantive_Mech/ELECTRICAL_V25.rvt

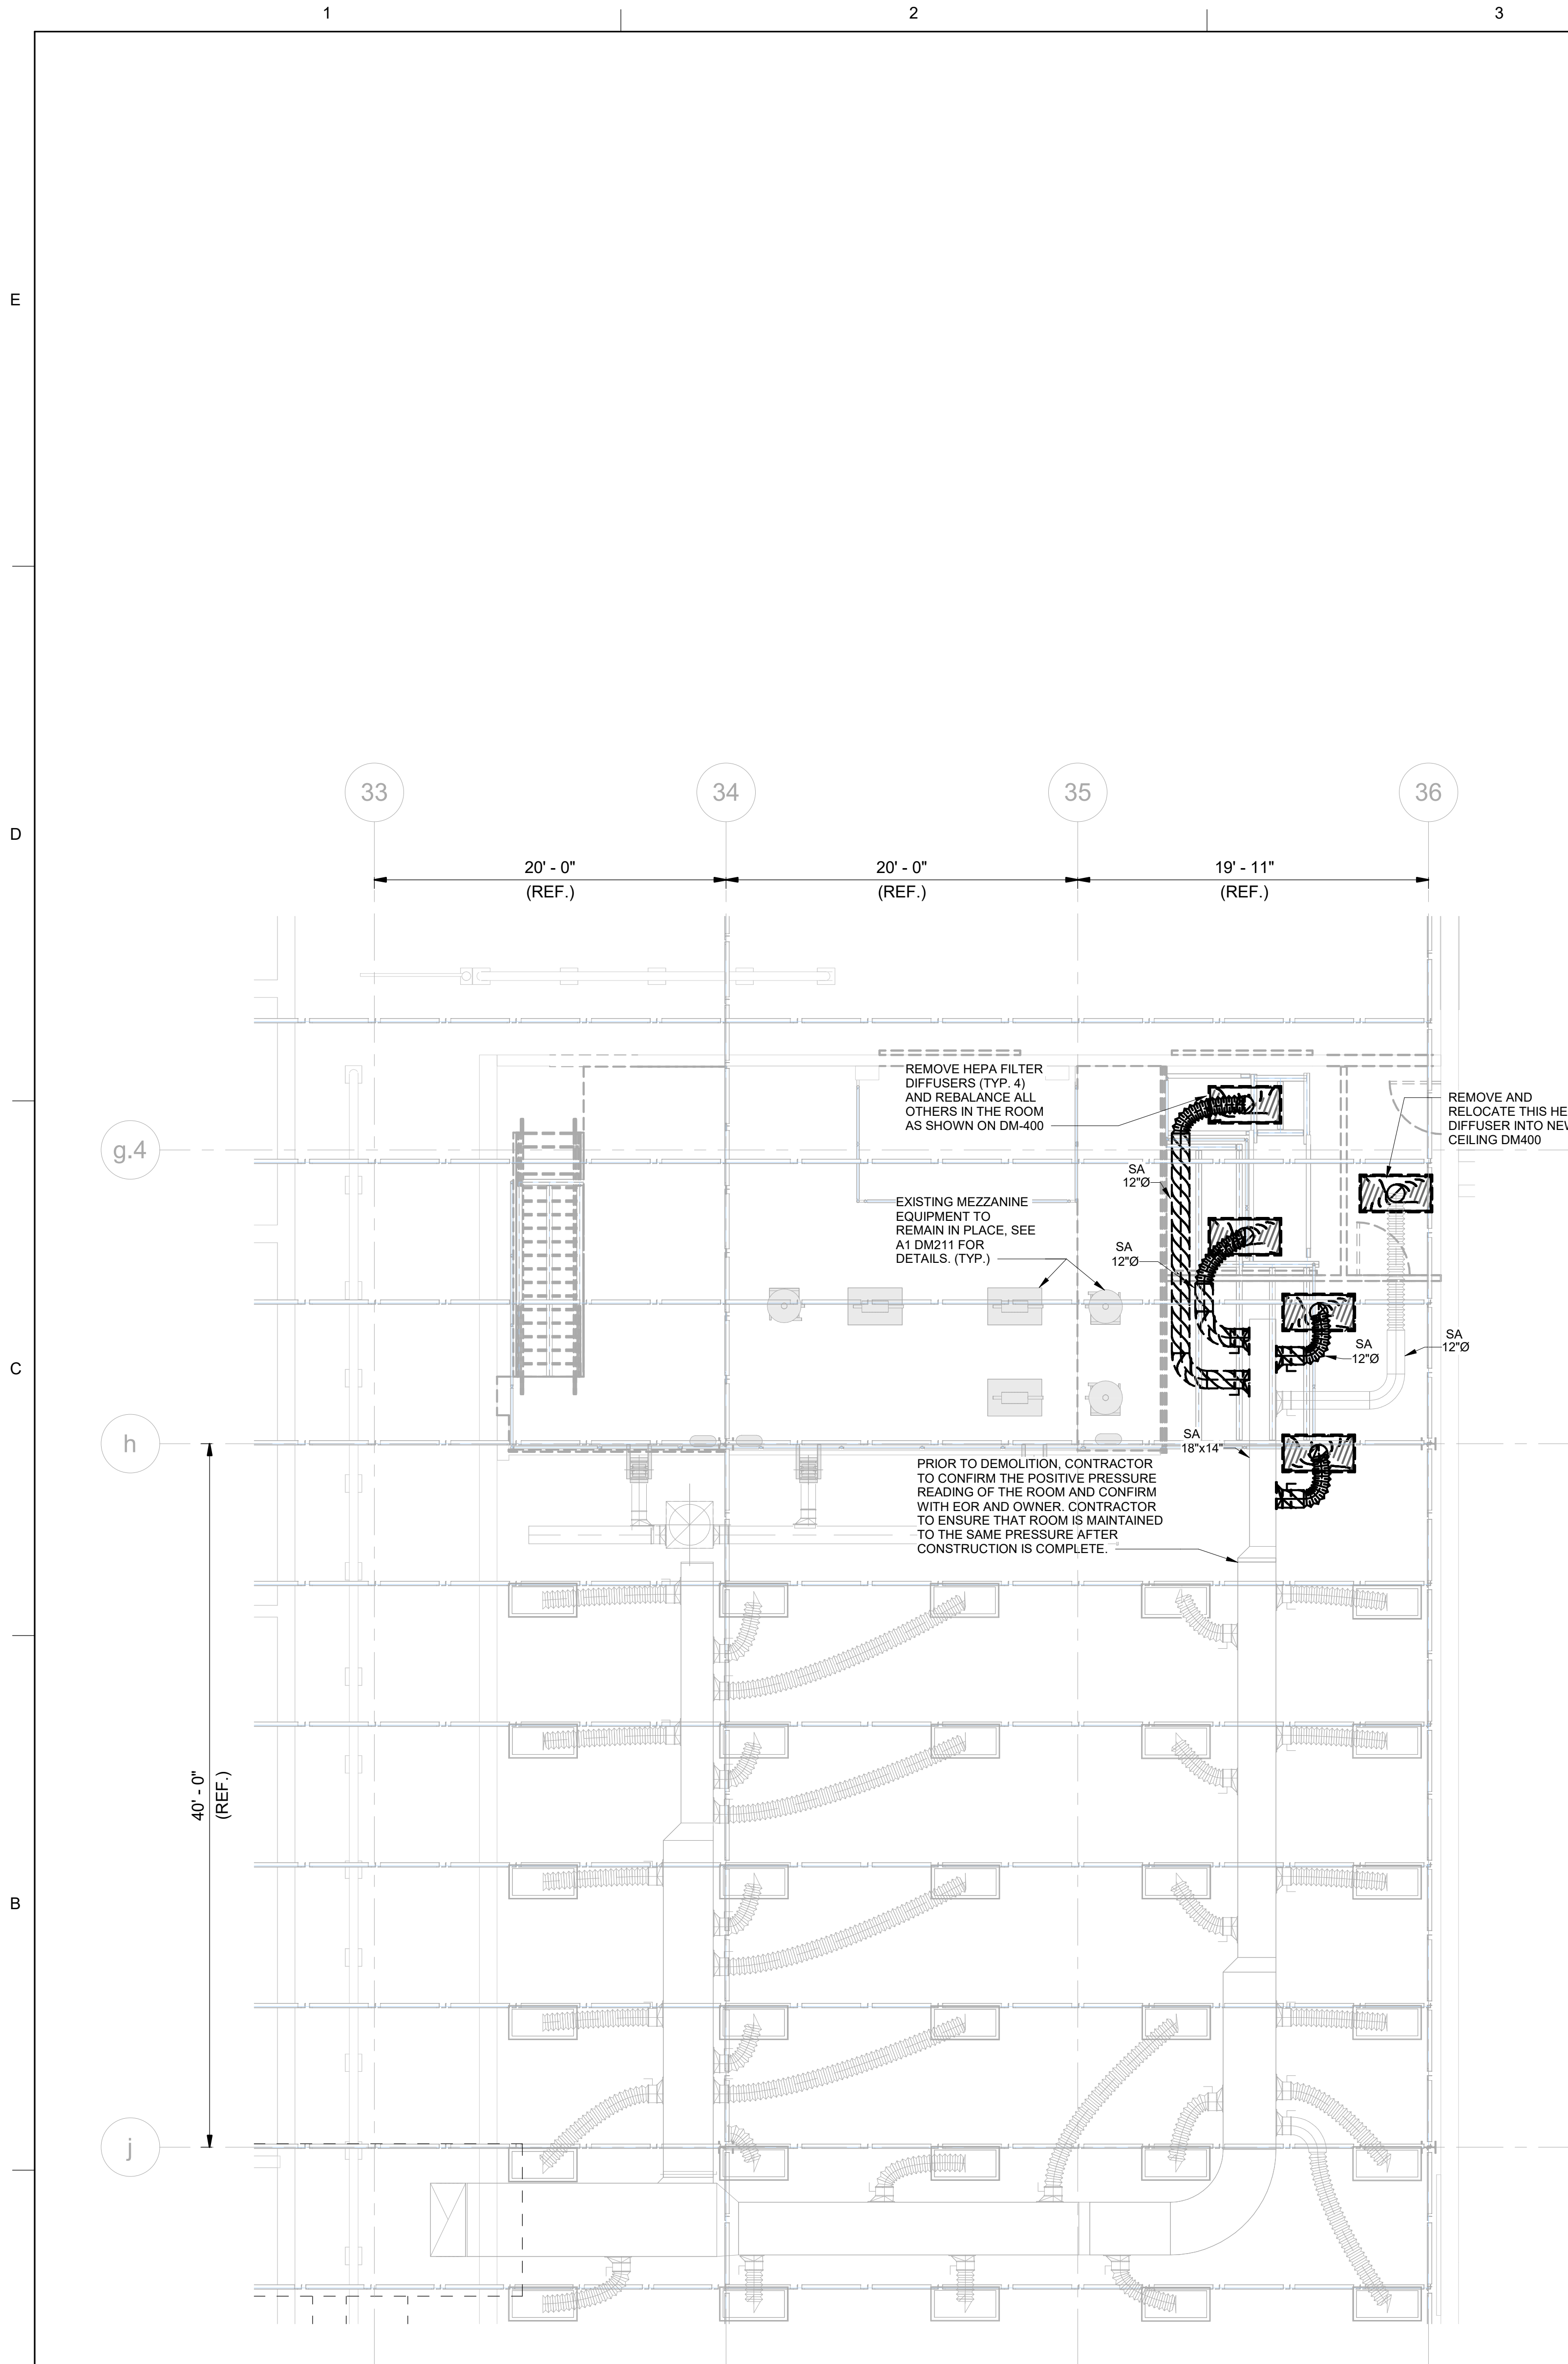


A1 **EXISTING - ROOM 510 FLOOR PLAN - DUCT**
SCALE: 3/16" = 1'-0"

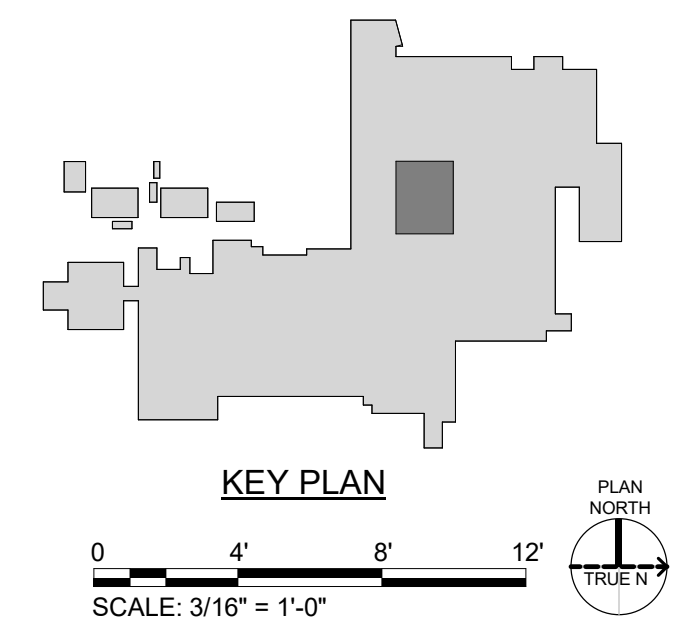

SHEET NOTES

1. REFER TO DM001 FOR PROCESS GENERAL NOTES AND DESIGN CRITERIA.
2. REFER TO DM002 FOR PROCESS ABBREVIATIONS AND LEGENDS.
3. REMOVE HEPA FILTER SYSTEM. RETURN TO VANTIVE FOR REPURPOSING
4. PRIOR TO DEMOLITION, CONTRACTOR TO CONFIRM & RECORD AIRFLOW FOR EOR.

LEGEND

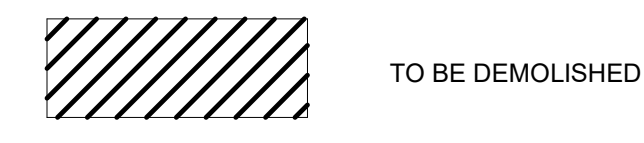

POND
3500 Parkway Lane
Suite 500
Peachtree Corners
Georgia 30092
Copyright © 2026 by Pond & Company. All rights reserved. No copying or duplication of these documents is allowed without the expressed written agreement of Pond & Company.

EOR/AOR SEAL

COA SEAL

CLIENT INFORMATION

Vantive

PROJECT NAME
**VANTIVE
TUBING
CLEAN ROOM**
1900 AR-201
MOUNTAIN HOME,
ARKANSAS 72653

DRAWING ISSUE	
DATE	DESCRIPTION
04/24/2026	ISSUED FOR BID, EQ BID
01/23/2026	CLARIFICATIONS
07/23/2025	ISSUED FOR APPROVAL
10/03/2025	ISSUED FOR ESTIMATE

MARK	DESCRIPTION
D	DESIGNED BY: JC
C	DRAWN BY: JS
A	CHECKED BY: JC
A	SUBMITTED BY: CL

DATE:	04/24/2026
PROJECT #:	1241011

SHEET TITLE
EXISTING - ROOM
510 FLOOR PLAN -
DUCT

SHEET NUMBER
DM212
ORIGINAL SHEET SIZE:
36" X 42"

ISSUED FOR BID