

1. REFER TO DM001 FOR PROCESS GENERAL NOTES AND DESIGN CRITERIA.
2. REFER TO DM002 FOR PROCESS ABBREVIATIONS AND LEGENDS.

FOR/AOR SEAL

COA SEAL

CLIENT INFORMATION



PROJECT NAME

VANTIVE
TUBING
CLEAN ROOM

1900 AR-201
MOUNTAIN HOME,
ARKANSAS 72653

DRAWING ISSUE

DATE
04/24/2026
01/23/2026
12/19/2025
11/14/2025

ISSUED FOR BID, EQ BID CLARIFICATIONS	ISSUED FOR APPROVAL	ISSUED FOR APPROVAL	ISSUED FOR REVIEW	DESCRIPTION
--	---------------------	---------------------	-------------------	-------------

MARK	A	B	C	D
------	---	---	---	---

DESIGNED BY: JC
DRAWN BY: JS
CHECKED BY: JC
SUBMITTED BY: CL
DATE: 04/24/2026
PROJECT #: 1241011



SHEET TITLE

EXISTING - ROOM
510 ROOF PLAN -
EQUIPMENT &
DUCT

SHEET NUMBER

DM213

ORIGINAL SHEET SIZE:
30" X 42"

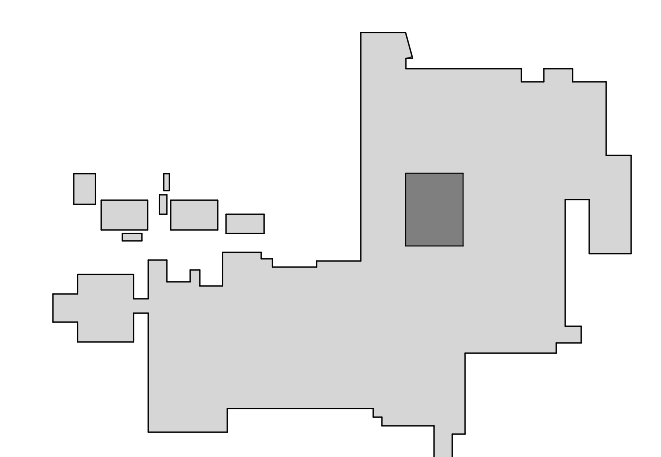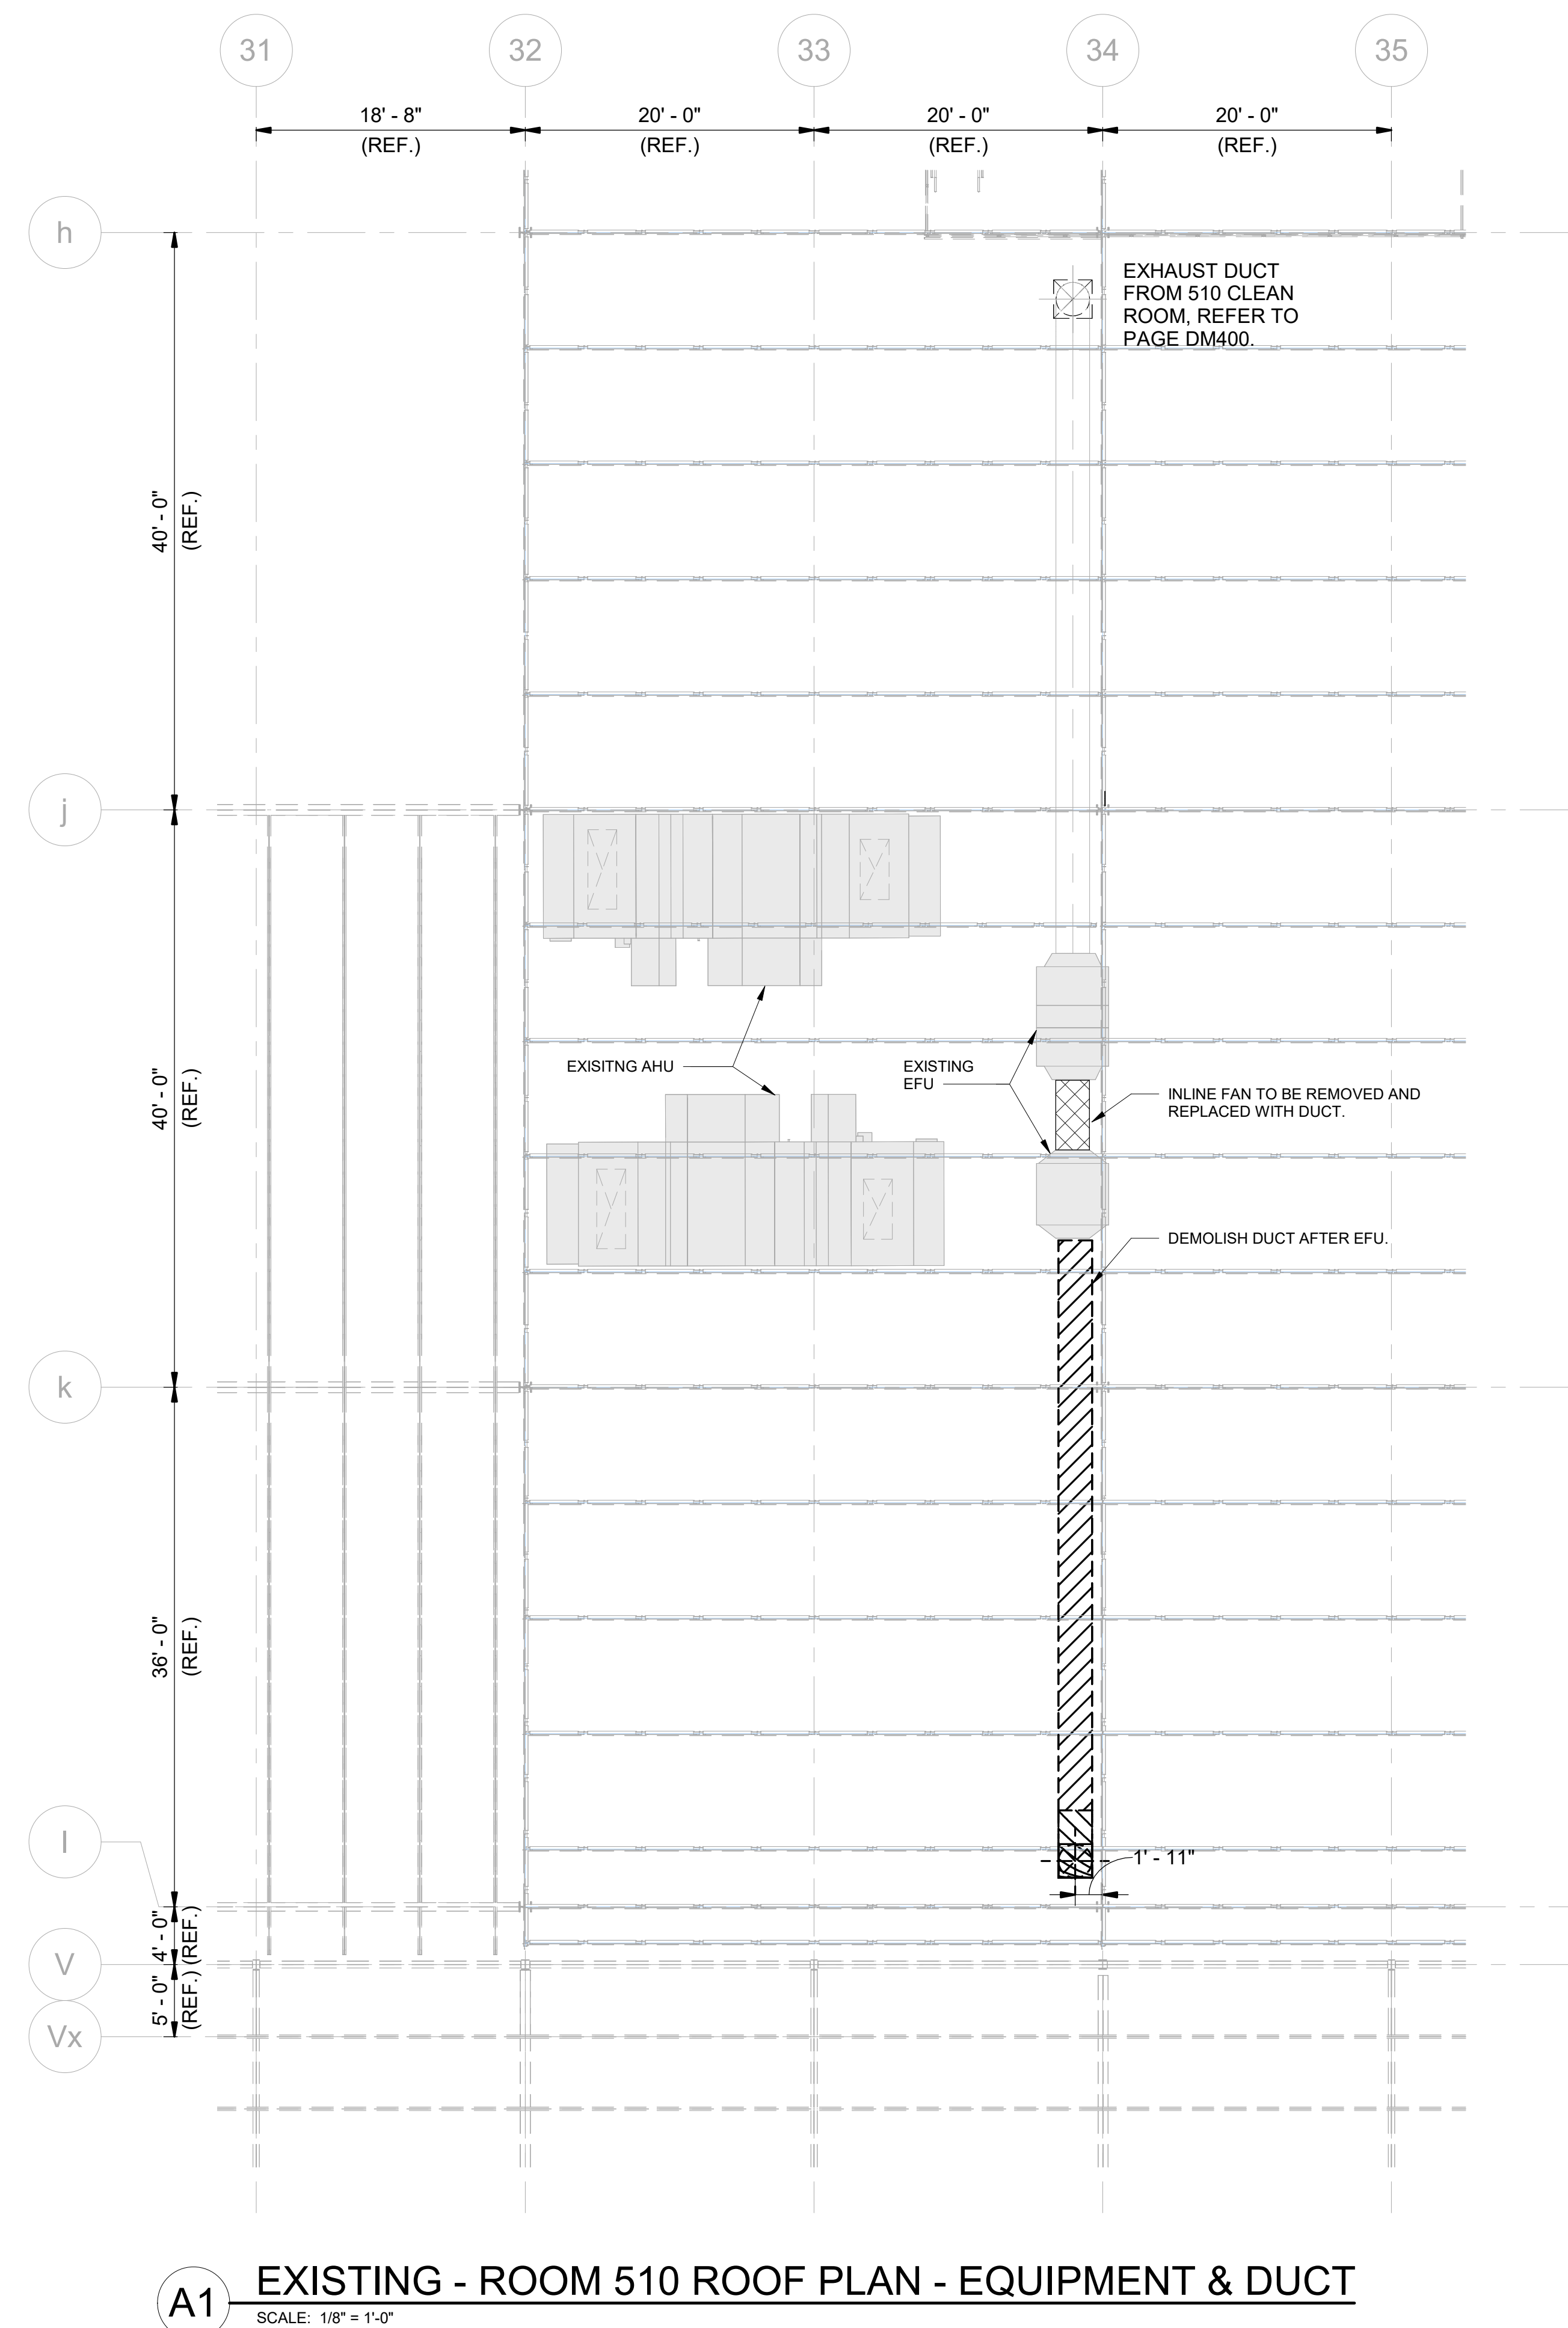

KEY PLAN

0 4' 8' 12'

SCALE: 3/16" = 1'-0"

