

1

2

3

4

5

6

E

D

C


B

A


SHEET NOTES

1. REFER TO DM001 FOR PROCESS GENERAL NOTES AND DESIGN CRITERIA.
2. REFER TO DM002 FOR PROCESS ABBREVIATIONS AND LEGENDS.
3. CONTRACTOR TO MAKE NOTE OF CURRENT PAHU OPERATIONS. CONTRACTOR TO MATCH CURRENT OPERATIONAL CONDITIONS AT NEW LOCATION.

LEGEND

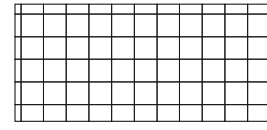

TO BE RELOCATED

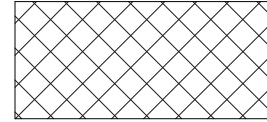TO BE REMOVED AND
RETURNED TO OWNER**POND**3500 Parkway Lane
Suite 500
Peachtree Corners
Georgia 30092

Copyright © 2024 by Pond & Company. All rights reserved. No copying or duplication of these documents is allowed without the expressed written agreement of Pond & Company.

EOR/AOR SEAL

COA SEAL

CLIENT INFORMATION

Vantive

PROJECT NAME

**VANTIVE
TUBING
CLEAN ROOM**1900 AR-201
MOUNTAIN HOME,
ARKANSAS 72653

DRAWING ISSUE

DATE	DESCRIPTION
04/24/2026	ISSUED FOR BID, EQ BID
01/23/2026	CLARIFICATIONS
07/23/2025	ISSUED FOR APPROVAL
11/14/2025	ISSUED FOR REVIEW

MARK	DESCRIPTION
D	DESIGNED BY:
C	DRAWN BY:
B	CHECKED BY:
A	SUBMITTED BY:

DESIGNED BY:	JC
DRAWN BY:	JS
CHECKED BY:	JC
SUBMITTED BY:	CL
DATE:	04/24/2026
PROJECT #:	1241011


SHEET TITLE

**EXISTING - 565
FLOOR PLAN -
EQUIPMENT &
DUCT**

SHEET NUMBER

DM230ORIGINAL SHEET SIZE:
30" X 42"**A1 EXISTING - 565 FLOOR PLAN - EQUIPMENT & DUCT**

SCALE: 3/16" = 1'-0"

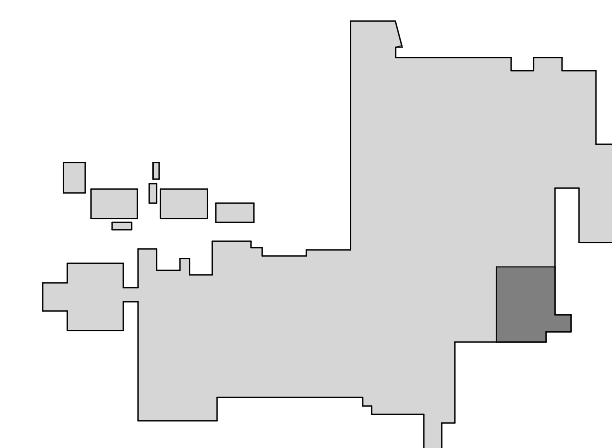

KEY PLAN

SCALE: 3/16" = 1'-0"

PLAN
NORTH
TILE # 7

ISSUED FOR BID