

SHEET NOTES

1. REFER TO DM001 FOR PROCESS GENERAL NOTES AND DESIGN CRITERIA.
2. REFER TO DM002 FOR PROCESS ABBREVIATIONS AND LEGENDS.
3. REFER TO PROCESS FLOW DIAGRAMS FOR PROCESS INFORMATION. PID SHEET DP202 FOR SILO V3 SYSTEM.
4. ALL NEW AND EXISTING EQUIPMENT DIMENSIONS, MAINTENANCE SPACE AND CONNECTIONS ARE TO BE CONFIRMED BY THE CONTRACTOR PRIOR TO INSTALLATION. ALL CONNECTIONS TO EQUIPMENT AND PIPING AND/OR DUCT TO BE CONNECTED ARE TO BE CONFIRMED BY THE CONTRACTOR PRIOR TO INSTALLATION.
5. CONTRACTOR TO INSTALL A DRIP PAN UNDER THE TEMPERED WATER SKID. RUN DRAIN DOWN TO FLOOR SINK BELOW.
6. ALL AZO EQUIPMENT IS BASED OFF 3/16/2026 SUBMITTAL PROVIDED TO VANTIVE. ANY INFORMATION MISSING OR CLASHING WILL BE COORDINATED BY CONTRACTOR BEFORE INSTALLATION.

EOR/AOR SEAL

COA SEAL

CLIENT INFORMATION

PROJECT NAME

VANTIVE
TUBING
CLEAN ROOM1900 AR-201
MOUNTAIN HOME,
ARKANSAS 72653

DRAWING ISSUE

DATE	DESCRIPTION
04/24/2026	ISSUED FOR BID, EQ BID
01/23/2026	ISSUED FOR APPROVAL
10/03/2025	ISSUED FOR ESTIMATE

DATE	DESCRIPTION
04/24/2026	ISSUED FOR BID, EQ BID
01/23/2026	ISSUED FOR APPROVAL
10/03/2025	ISSUED FOR ESTIMATE

D C A MARK

DESIGNED BY:	JC
DRAWN BY:	JS
CHECKED BY:	JC
SUBMITTED BY:	CL
DATE:	04/24/2026
PROJECT #:	1241011

SHEET TITLE

GENERAL
ARRANGEMENT -
ROOM 510
MEZZANINE
ENLARGED PLAN


SHEET NUMBER

DM301

ORIGINAL SHEET SIZE:
36" X 42"


KEYNOTES

1. EXISTING SILO V3 VACUUM BLOWER. CURRENTLY UNDER FEASIBILITY STUDY TO DETERMINE IF IT CAN BE USED A THIRD EXTRUDER VACUUM PUMP FOR REDUNDANCY.
2. TEMPERED WATER SKID TO INCLUDE STAINLESS STEEL DRIP PAN THAT SITS ON MEZZANINE THAT WILL BE ROUTED TO NEAREST FLOOR DRAIN.

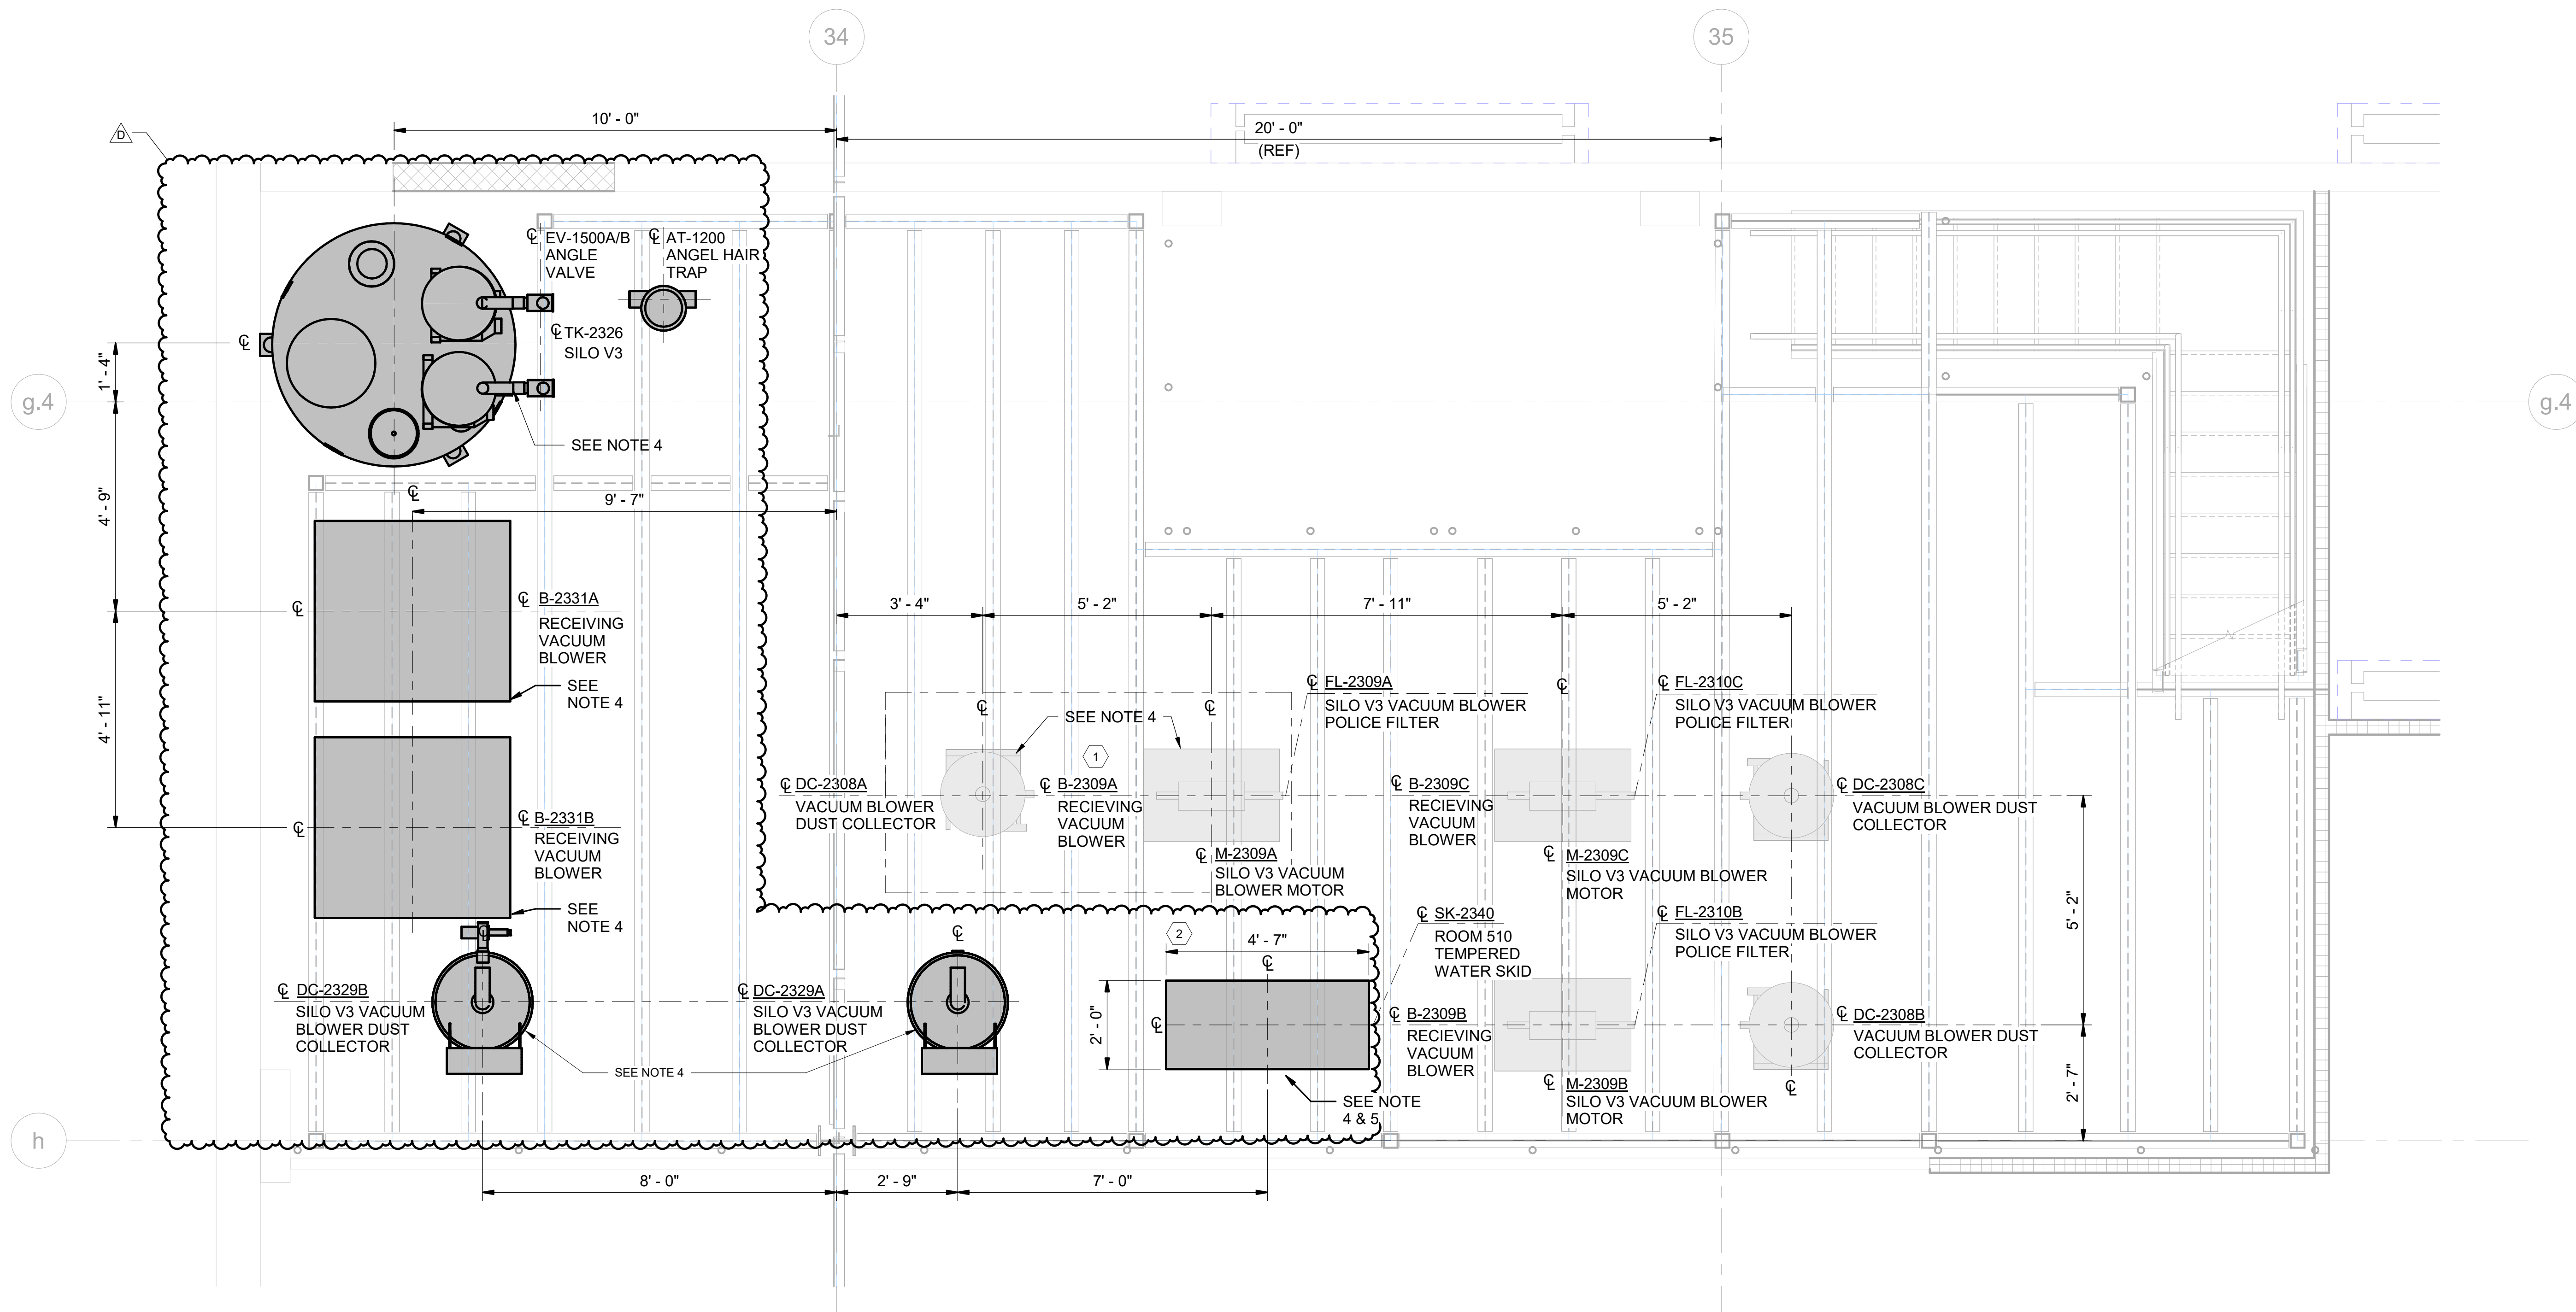

A1 GENERAL ARRANGEMENT - ROOM 510 MEZZANINE ENLARGED

SCALE: 1/2" = 1'-0"

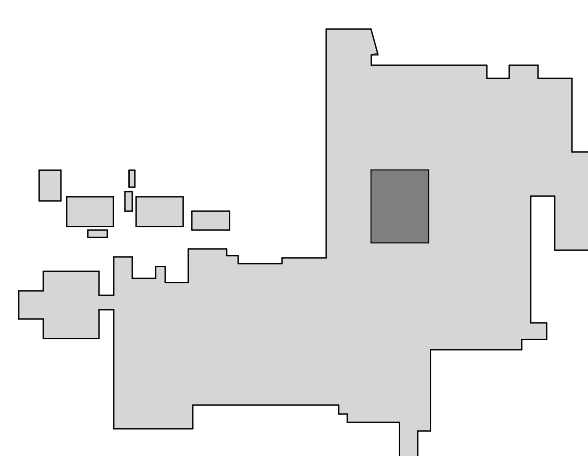

KEY PLAN

0 1' 2' 4'
SCALE: 1/2" = 1'-0"PLAN
NORTH
1" = 1' 0"

ISSUED FOR BID