


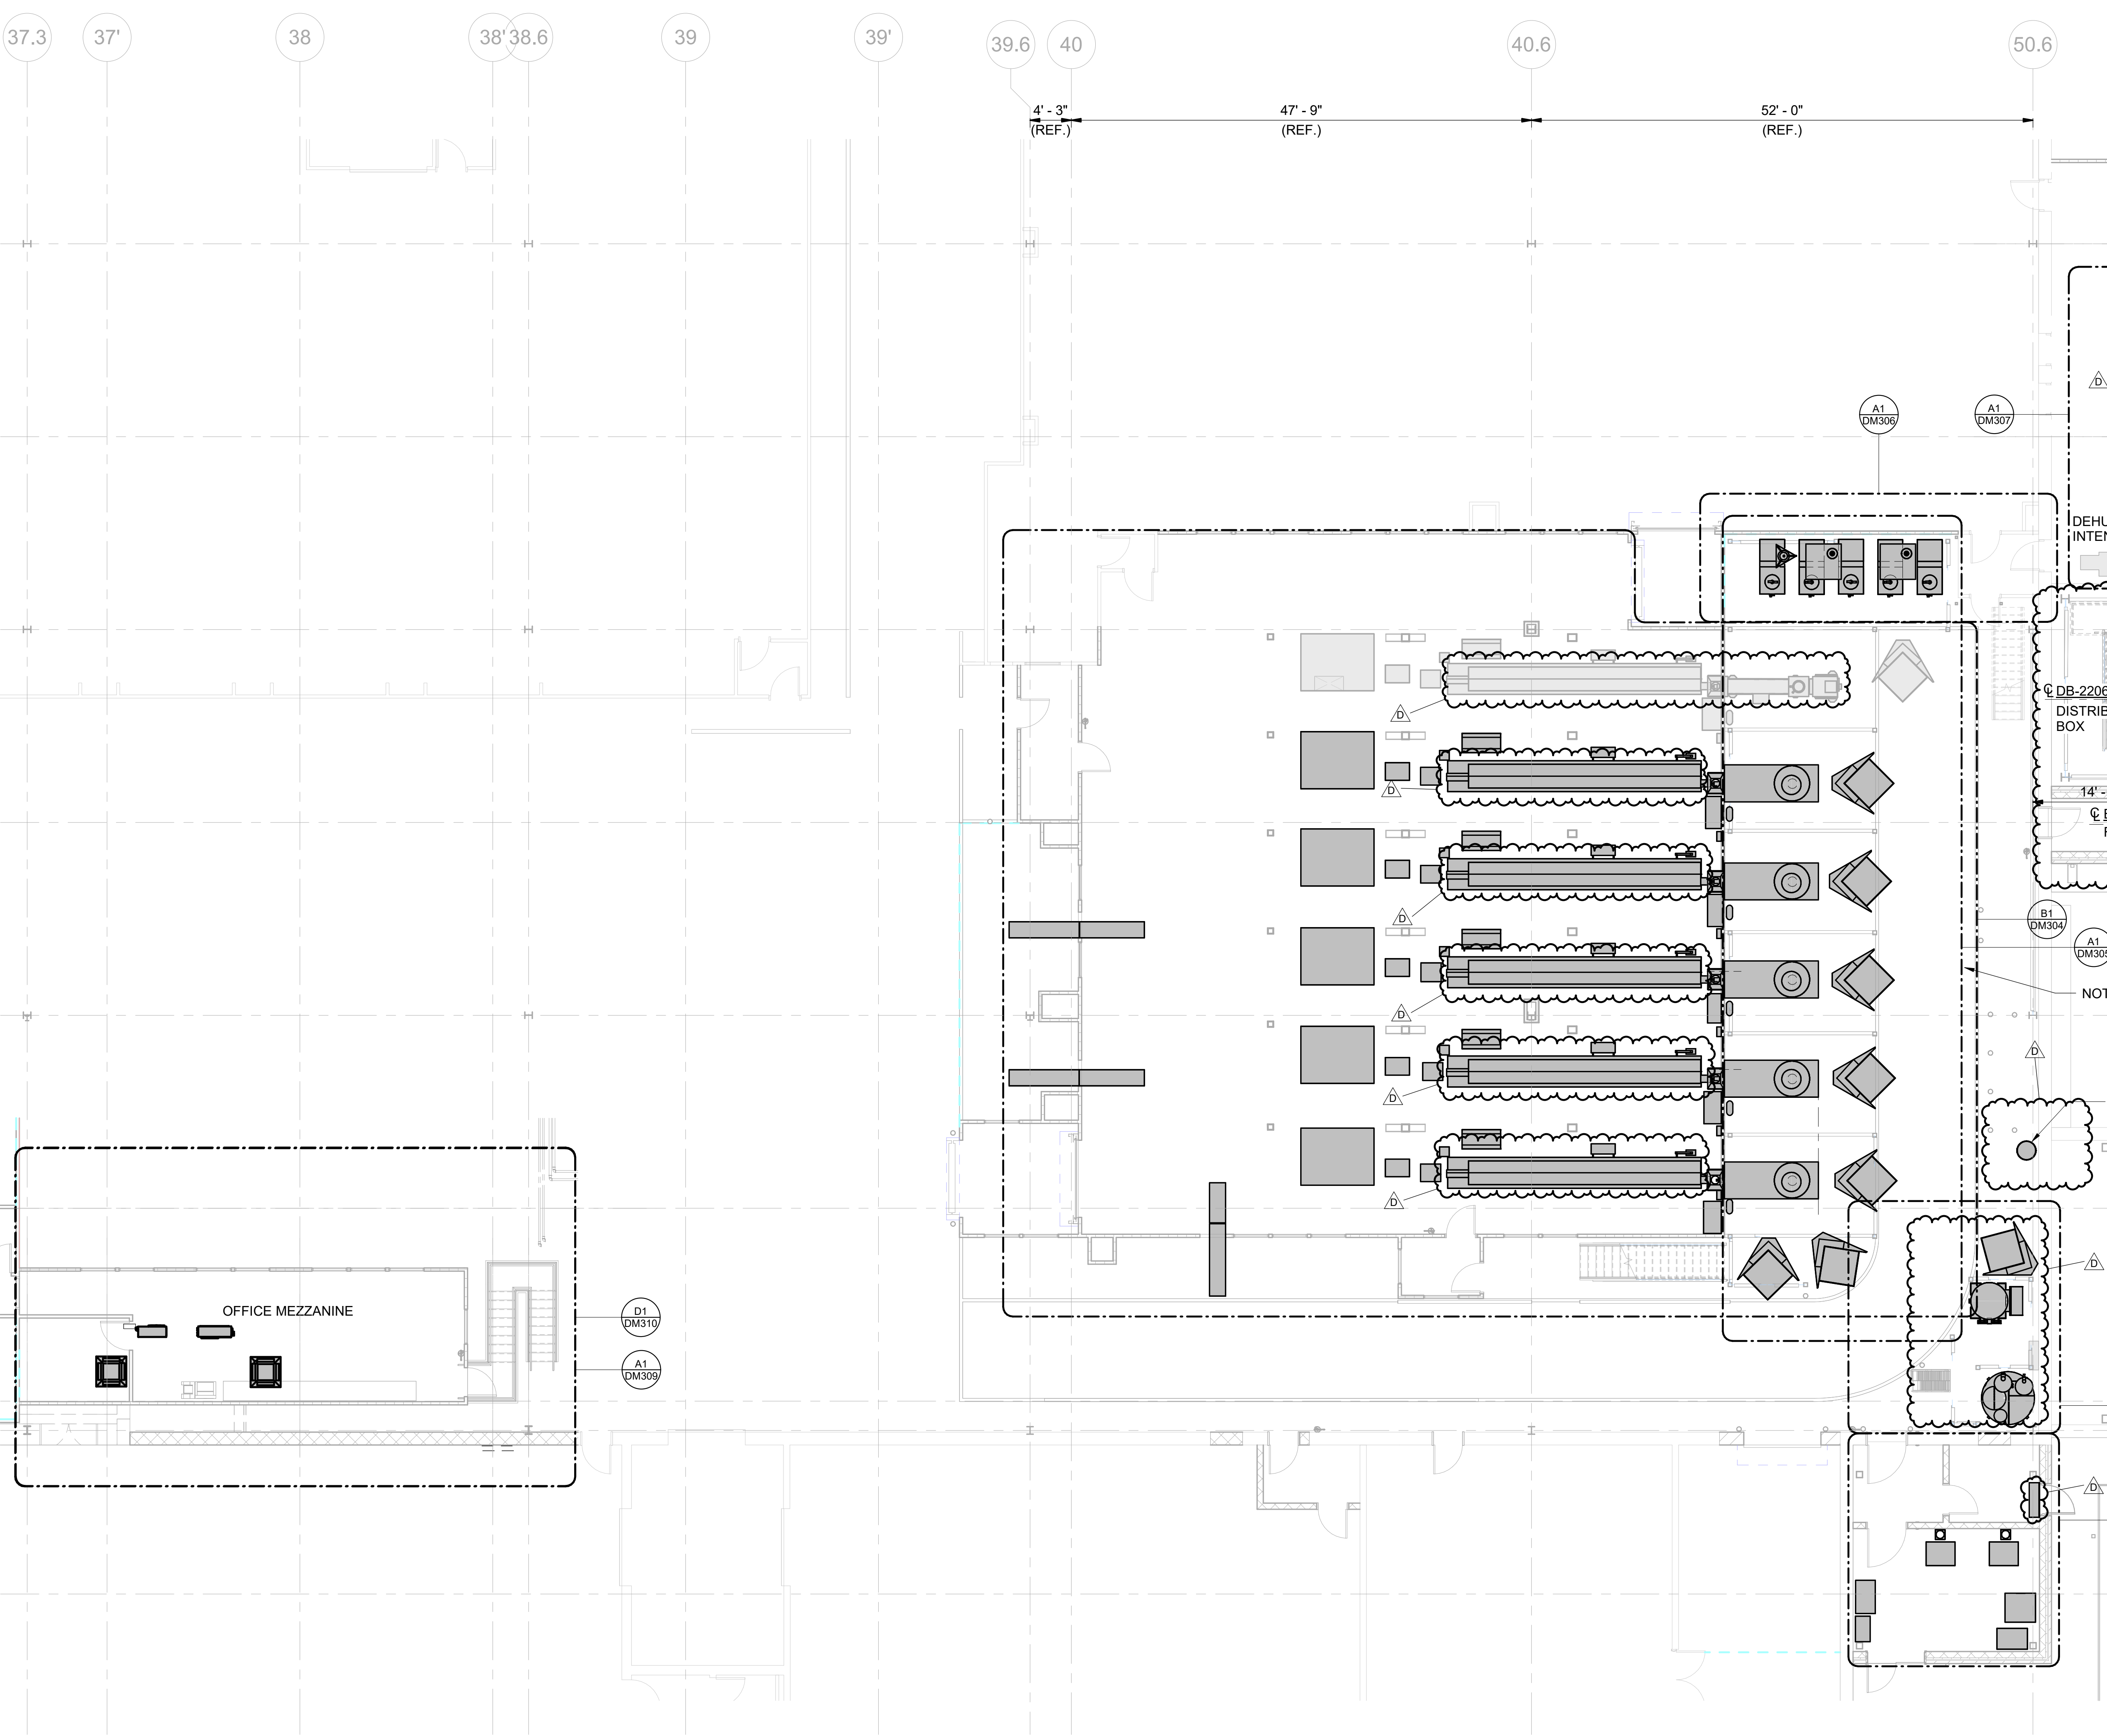

- SHEET NOTES**
1. REFER TO DM001 FOR PROCESS GENERAL NOTES AND DESIGN CRITERIA.
 2. REFER TO DM002 FOR PROCESS ABBREVIATIONS AND LEGENDS.
 3. REFER TO A1 DM305 FOR MEZZANINE LEVEL GENERAL ARRANGEMENT.
 4. FLY FANS TO HAVE AN AUTOMATIC SHUTOFF WHEN TEMPERATURES ARE BELOW 45 DEGREES F
 5. ALL AZO EQUIPMENT IS BASED OFF 3/16 SUBMITTAL PROVIDED TO VANTIVE. ANY INFORMATION MISSING OR CLASHING WILL BE COORDINATED BY CONTRACTOR BEFORE INSTALLATION.

POND

3500 Parkway Lane
Suite 500
Peachtree Corners
Georgia 30092

Copyright © 2024 by Pond & Company. All rights reserved. No copying or duplication of these documents is allowed without the expressed written agreement of Pond & Company.

EOR/AOR SEAL

COA SEAL

CLIENT INFORMATION

Vantive

PROJECT NAME

**VANTIVE
TUBING
CLEAN ROOM**

1900 AR-201
MOUNTAIN HOME,
ARKANSAS 72653

DRAWING ISSUE

DATE	DESCRIPTION
04/24/2026	ISSUED FOR BID, EQ BID
01/23/2026	CLARIFICATIONS
07/22/2025	ISSUED FOR APPROVAL
11/14/2025	ISSUED FOR REVIEW

MARK	A	C	D
MARK			

DESIGNED BY: JC

DRAWN BY: JS

CHECKED BY: JC

SUBMITTED BY: CL

DATE: 04/24/2026

PROJECT #: 1241011

SHEET TITLE


GENERAL
ARRANGEMENT -
565 FLOOR PLAN

SHEET NUMBER

DM303

ORIGINAL SHEET SIZE:
30" X 42"

A1 GENERAL ARRANGEMENT - 565 FLOOR PLAN
SCALE: 1/8" = 1'-0"

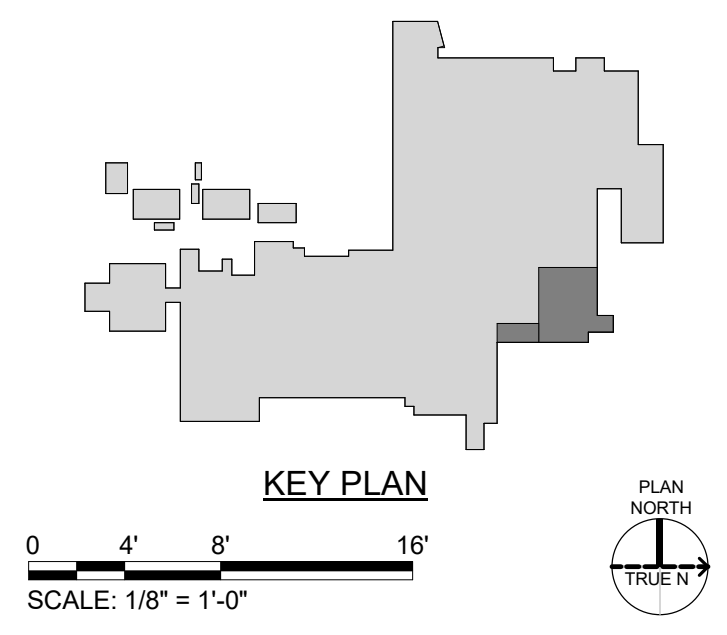

4/24/2026 3:31:20 PM Autodesk Docs/Baxter and Vantive Mountain Home/Baxter_Vantive_Mountain_Home/BAXTER_VANTIVE_Master_Base_File_MECH/ELEC/FP_025.rvt