


4/24/2026 3:31:36 PM Autodesk Docs/Baxter and Vantive Mountain Home/BAXTER_VANTIVE_Mountain Home/BAXTER_VANTIVE_Mech/ELEC/CP_025.rvt

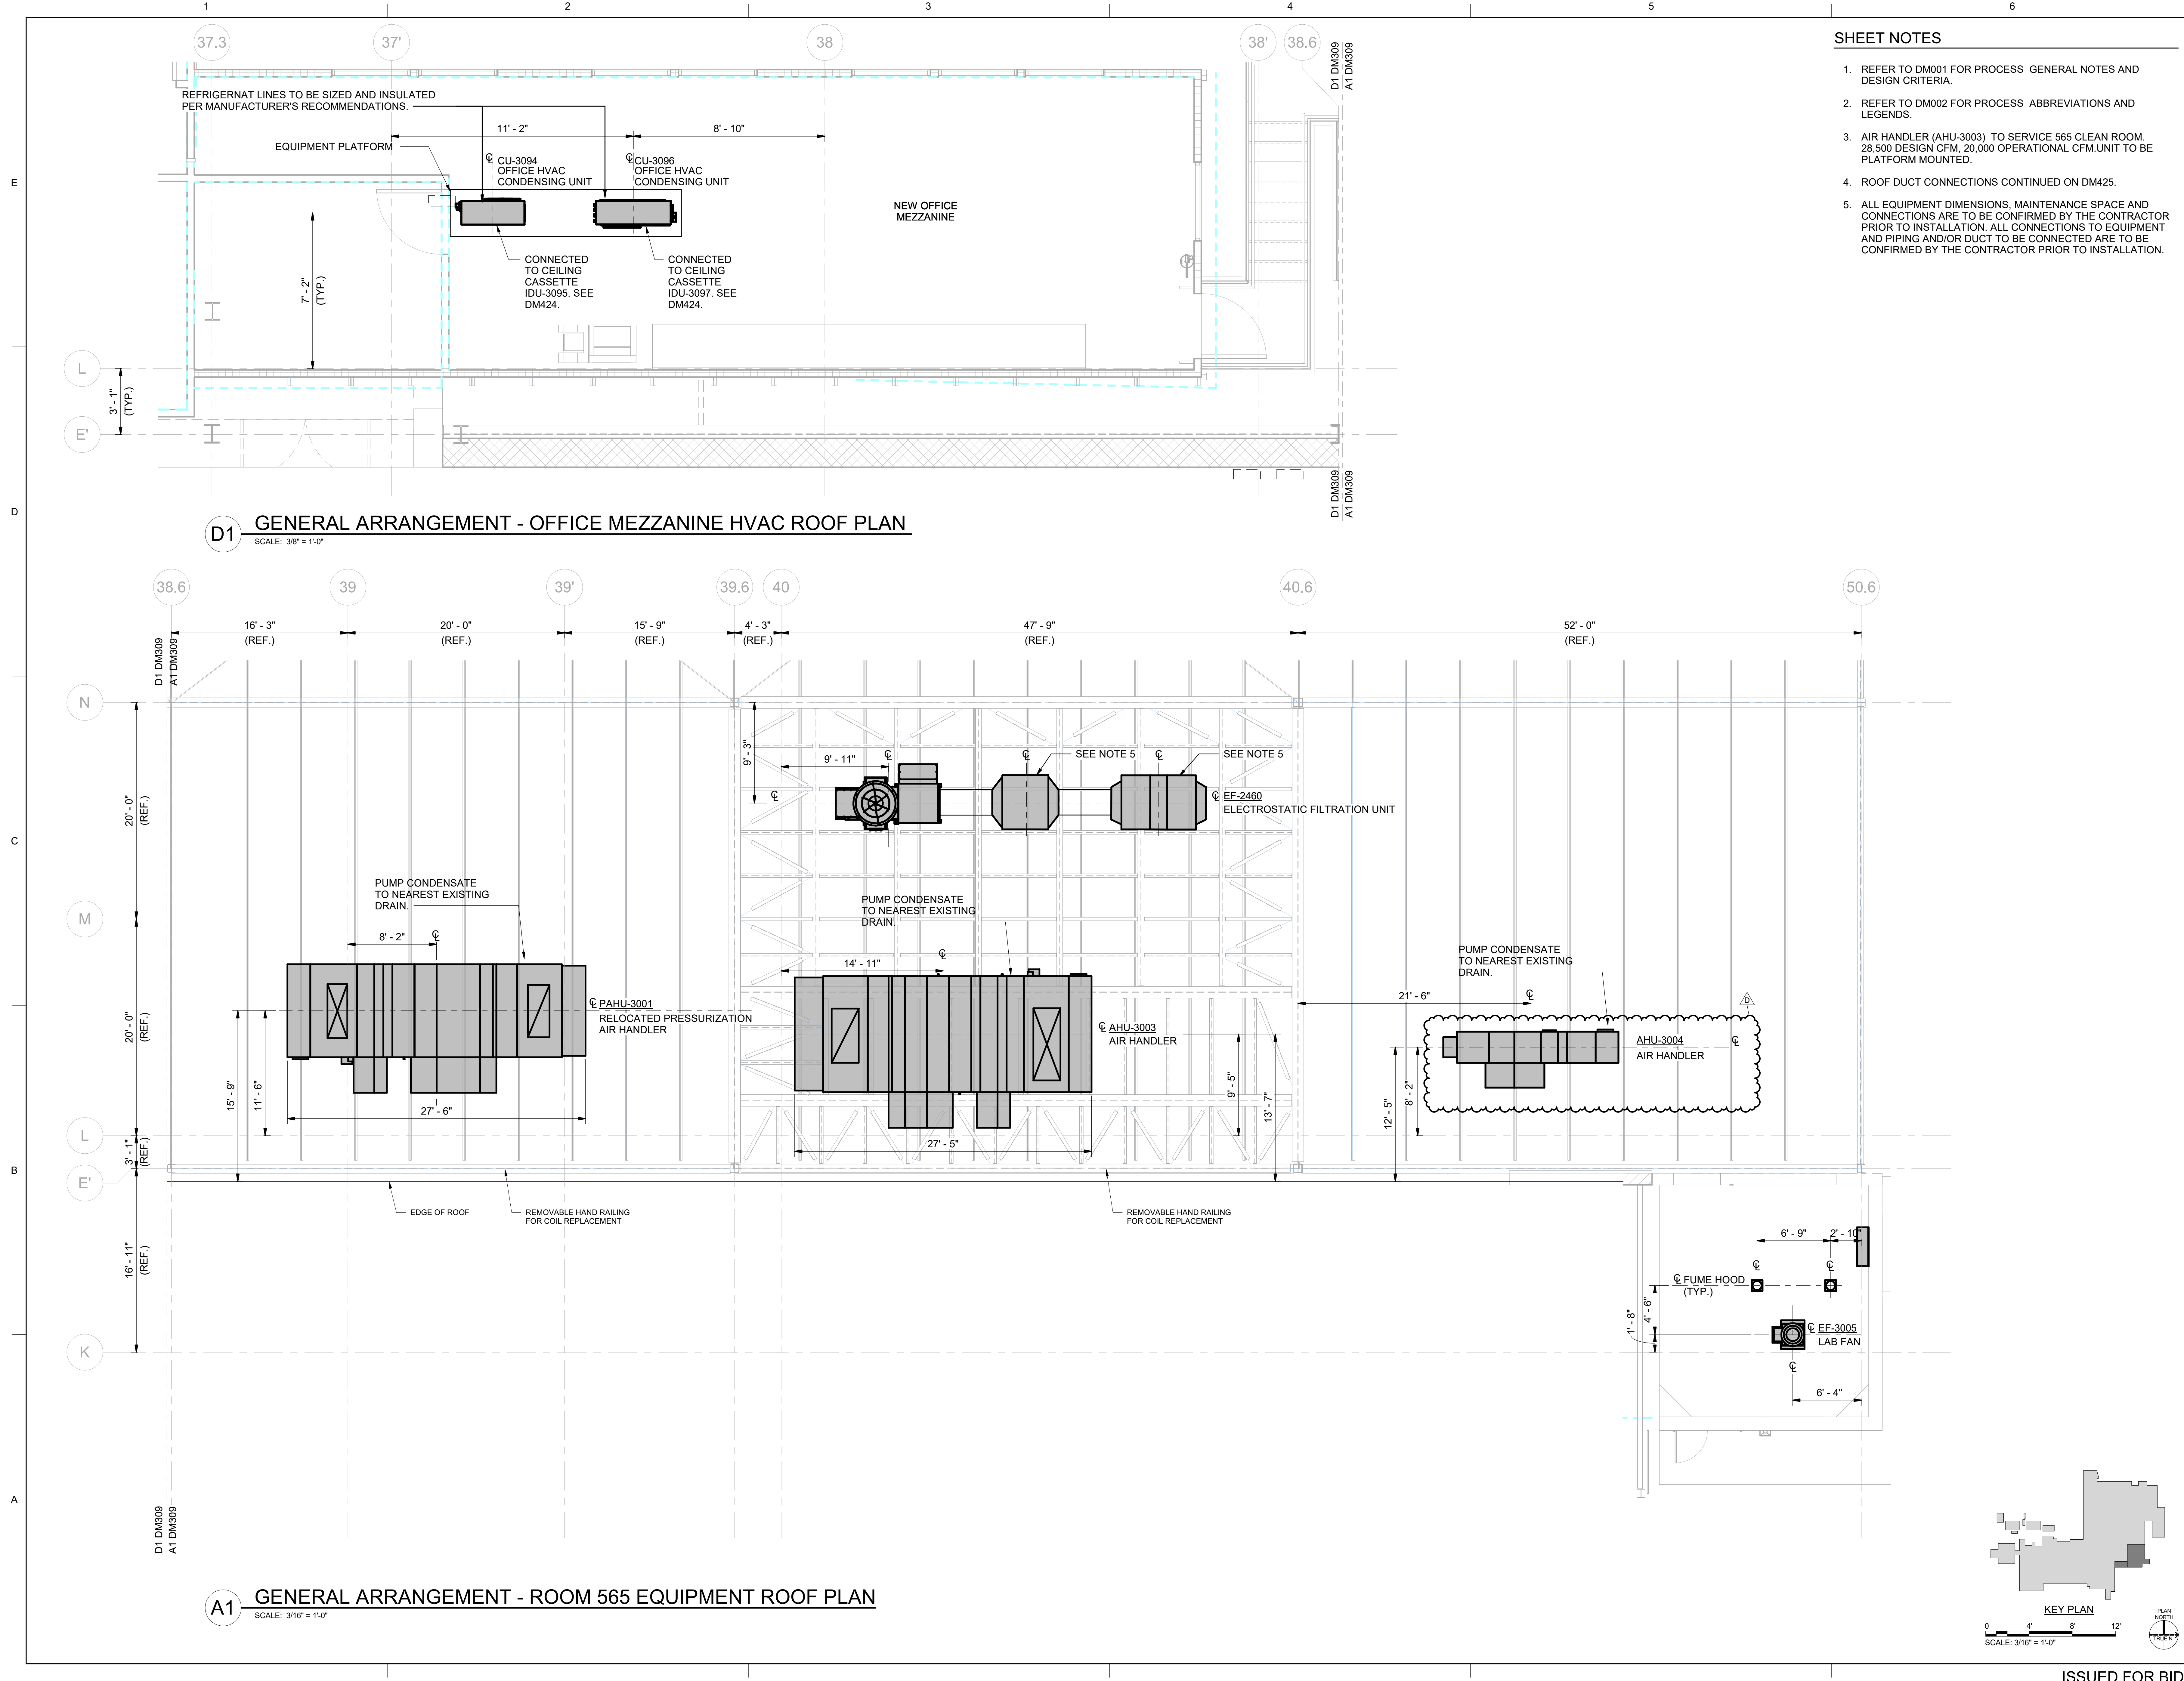

SHEET NOTES

1. REFER TO DM001 FOR PROCESS GENERAL NOTES AND DESIGN CRITERIA.
2. REFER TO DM002 FOR PROCESS ABBREVIATIONS AND LEGENDS.
3. AIR HANDLER (AHU-3003) TO SERVICE 565 CLEAN ROOM. 28,500 DESIGN CFM, 20,000 OPERATIONAL CFM. UNIT TO BE PLATFORM MOUNTED.
4. ROOF DUCT CONNECTIONS CONTINUED ON DM425.
5. ALL EQUIPMENT DIMENSIONS, MAINTENANCE SPACE AND CONNECTIONS ARE TO BE CONFIRMED BY THE CONTRACTOR PRIOR TO INSTALLATION. ALL CONNECTIONS TO EQUIPMENT AND PIPING AND/OR DUCT TO BE CONNECTED ARE TO BE CONFIRMED BY THE CONTRACTOR PRIOR TO INSTALLATION.



3500 Parkway Lane
Suite 500
Peachtree Corners
Georgia 30092

Copyright © 2026 by Pond & Company. All rights reserved. No copying or duplication of these documents is allowed without the expressed written agreement of Pond & Company.

EOR/AOR SEAL

COA SEAL

CLIENT INFORMATION



PROJECT NAME

**VANTIVE
TUBING
CLEAN ROOM**

1900 AR-201
MOUNTAIN HOME,
ARKANSAS 72653

DRAWING ISSUE

DATE	DESCRIPTION
04/24/2026	ISSUED FOR BID, EQ BID
01/23/2026	CLARIFICATIONS
07/23/2025	ISSUED FOR APPROVAL
11/14/2025	ISSUED FOR REVIEW

MARK	DESCRIPTION
D	ISSUED FOR BID, EQ BID
C	CLARIFICATIONS
A	ISSUED FOR APPROVAL

DESIGNED BY: JC
DRAWN BY: JS
CHECKED BY: JC
SUBMITTED BY: CL
DATE: 04/24/2026
PROJECT #: 1241011


SHEET TITLE

**GENERAL
ARRANGEMENT -
565 ROOF PLAN**

SHEET NUMBER

DM310

ORIGINAL SHEET SIZE:
36" X 42"

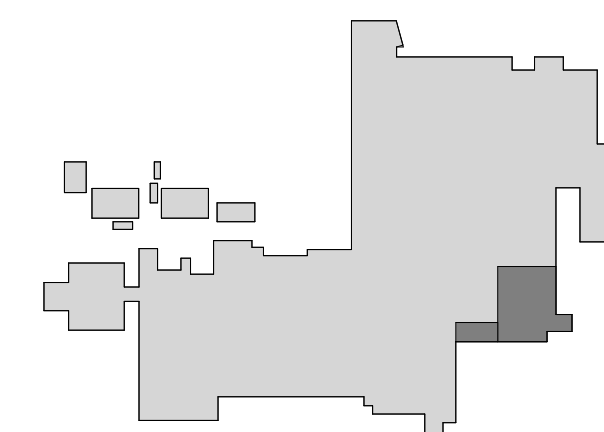

0 4' 8' 12'
SCALE: 3/16" = 1'-0"



ISSUED FOR BID