

1

2

3

4

5

6

SHEET NOTES

1. REFER TO DM001 FOR PROCESS GENERAL NOTES AND DESIGN CRITERIA.
2. REFER TO DM002 FOR PROCESS ABBREVIATIONS AND LEGENDS.
3. REFER TO PROCESS FLOW DIAGRAMS FOR PROCESS INFORMATION.
4. ALL EQUIPMENT DIMENSIONS, MAINTENANCE SPACE AND CONNECTIONS ARE TO BE CONFIRMED BY THE CONTRACTOR PRIOR TO INSTALLATION. ALL CONNECTIONS TO EQUIPMENT AND PIPING AND/OR DUCT TO BE CONNECTED ARE TO BE CONFIRMED BY THE CONTRACTOR PRIOR TO INSTALLATION.

POND3500 Parkway Lane
Suite 500
Peachtree Corners
Georgia 30092

Copyright © 2026 by Pond & Company. All rights reserved. No copying or duplication of these documents is allowed without the expressed written agreement of Pond & Company.

EOR/AOR SEAL

COA SEAL

CLIENT INFORMATION

Vantive

PROJECT NAME

**VANTIVE
TUBING
CLEAN ROOM**1900 AR-201
MOUNTAIN HOME,
ARKANSAS 72653

DRAWING ISSUE

04/24/2026
01/23/2026
11/14/2025
DATEISSUED FOR BID, EQ BID
CLARIFICATIONS
ISSUED FOR APPROVAL
ISSUED FOR APPROVAL
ISSUED FOR REVIEW
DESCRIPTION

D C A MARK

DESIGNED BY: JC
DRAWN BY: JS
CHECKED BY: JC
SUBMITTED BY: CL
DATE: 04/24/2026
PROJECT #: 1241011


SHEET TITLE

**DUCT -
ENLARGED-
OFFICE
MEZZANINE HVAC
FLOOR PLAN**


SHEET NUMBER

DM424ORIGINAL SHEET SIZE:
30" X 42"

4/24/2026 3:31:45 PM Autodesk Docs/Baxter and Vantive Mountain Home/Baxter and Vantive Mountain Home/Baxter_Vantive_MechElec_Floor_Plan_025.rvt

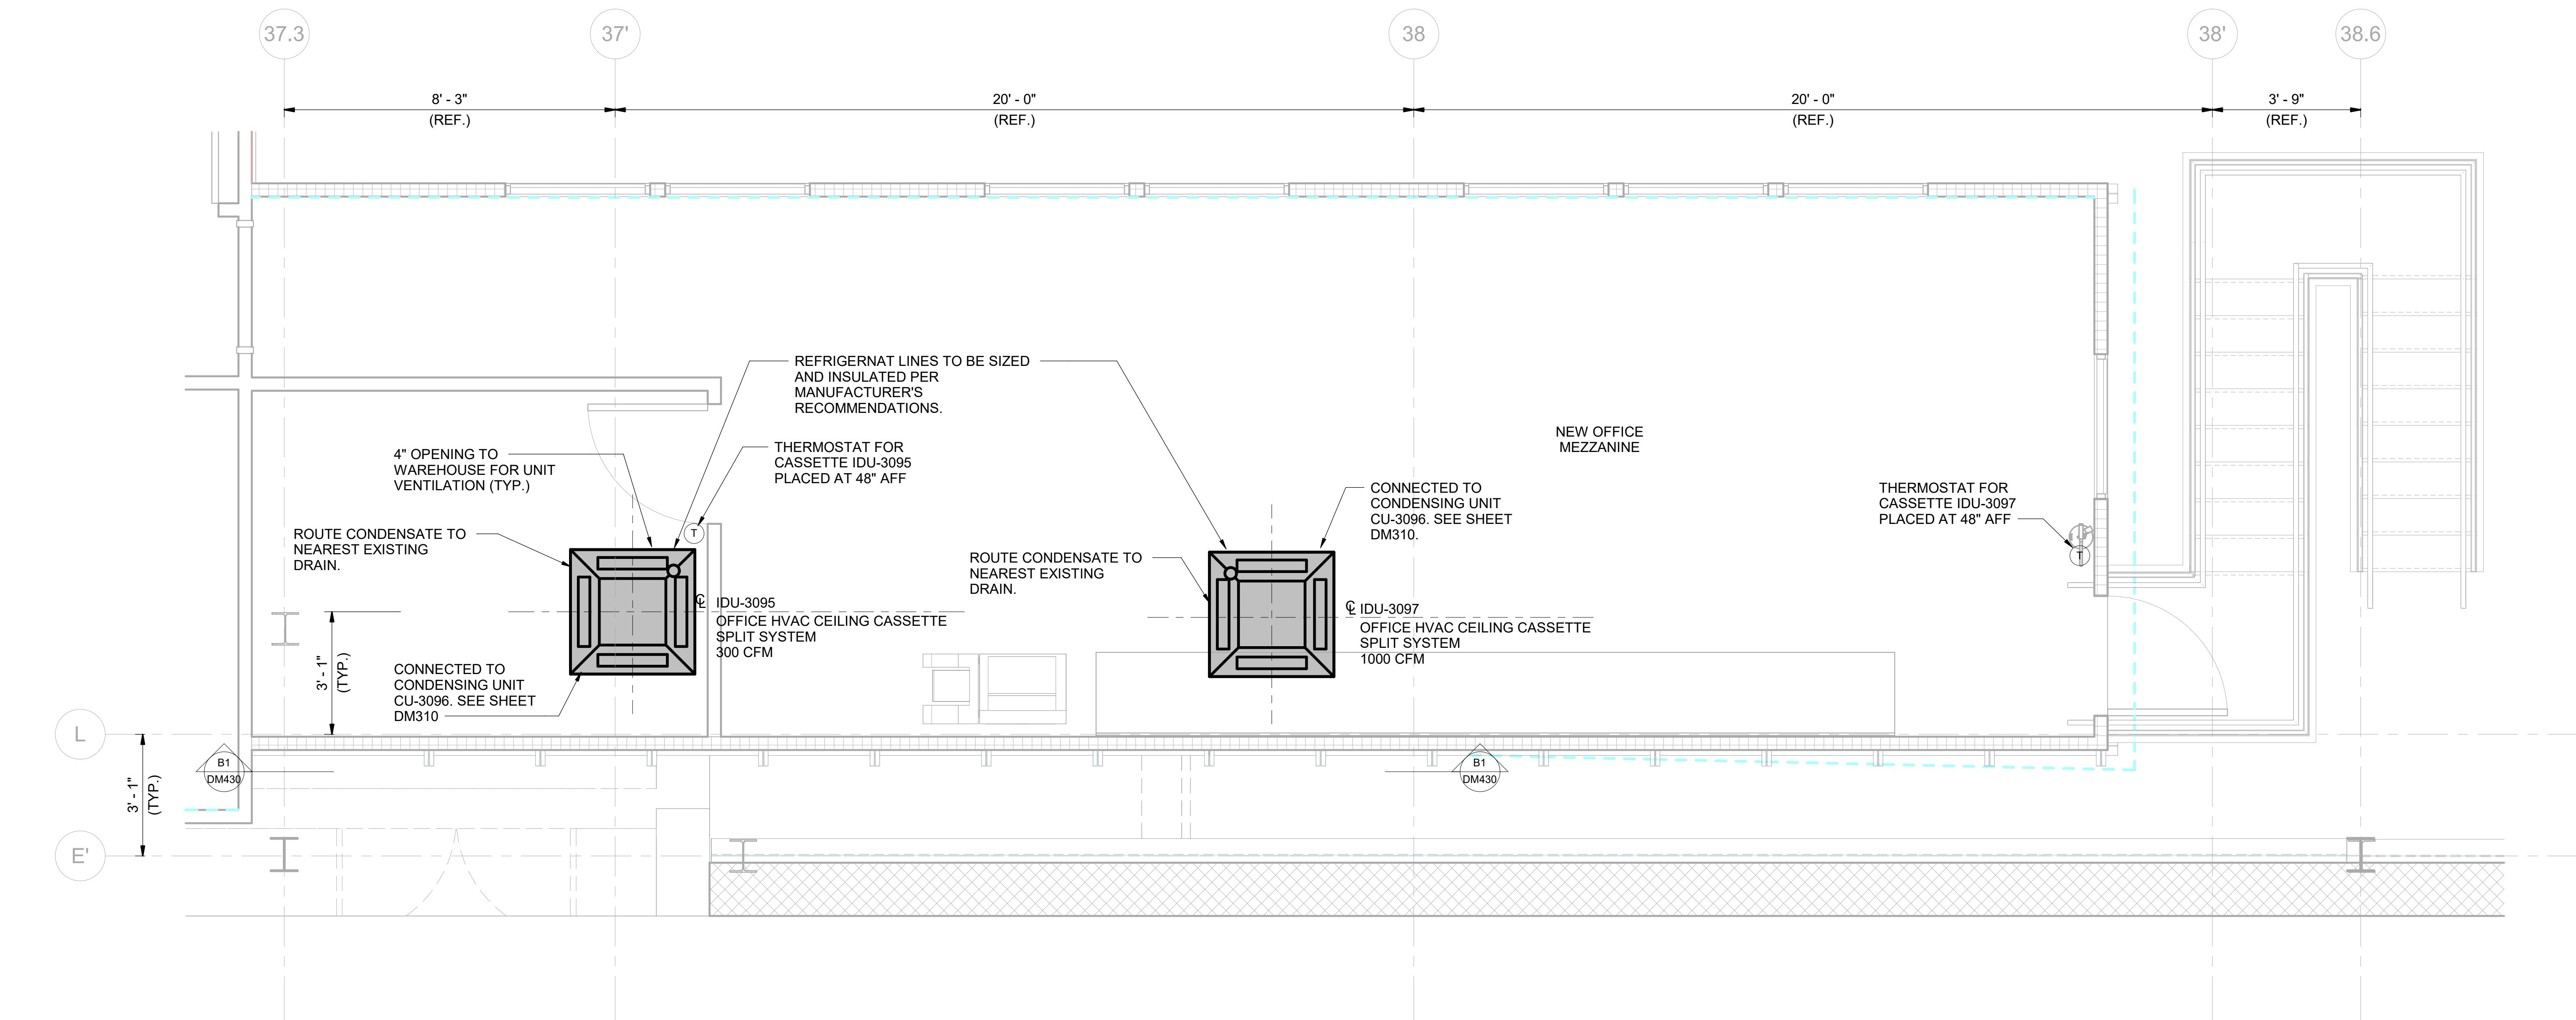**A1 FLOOR PLAN - OFFICE MEZZANINE HVAC**

SCALE: 1/2" = 1'-0"

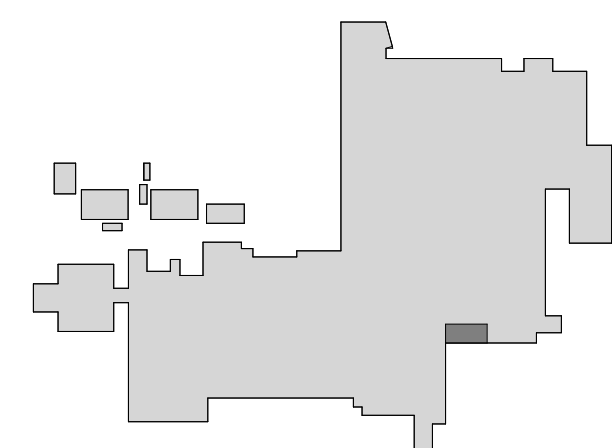

KEY PLAN

0 4' 8' 16'
SCALE: 1/8" = 1'-0"PLAN NORTH
TRUE N

ISSUED FOR BID