


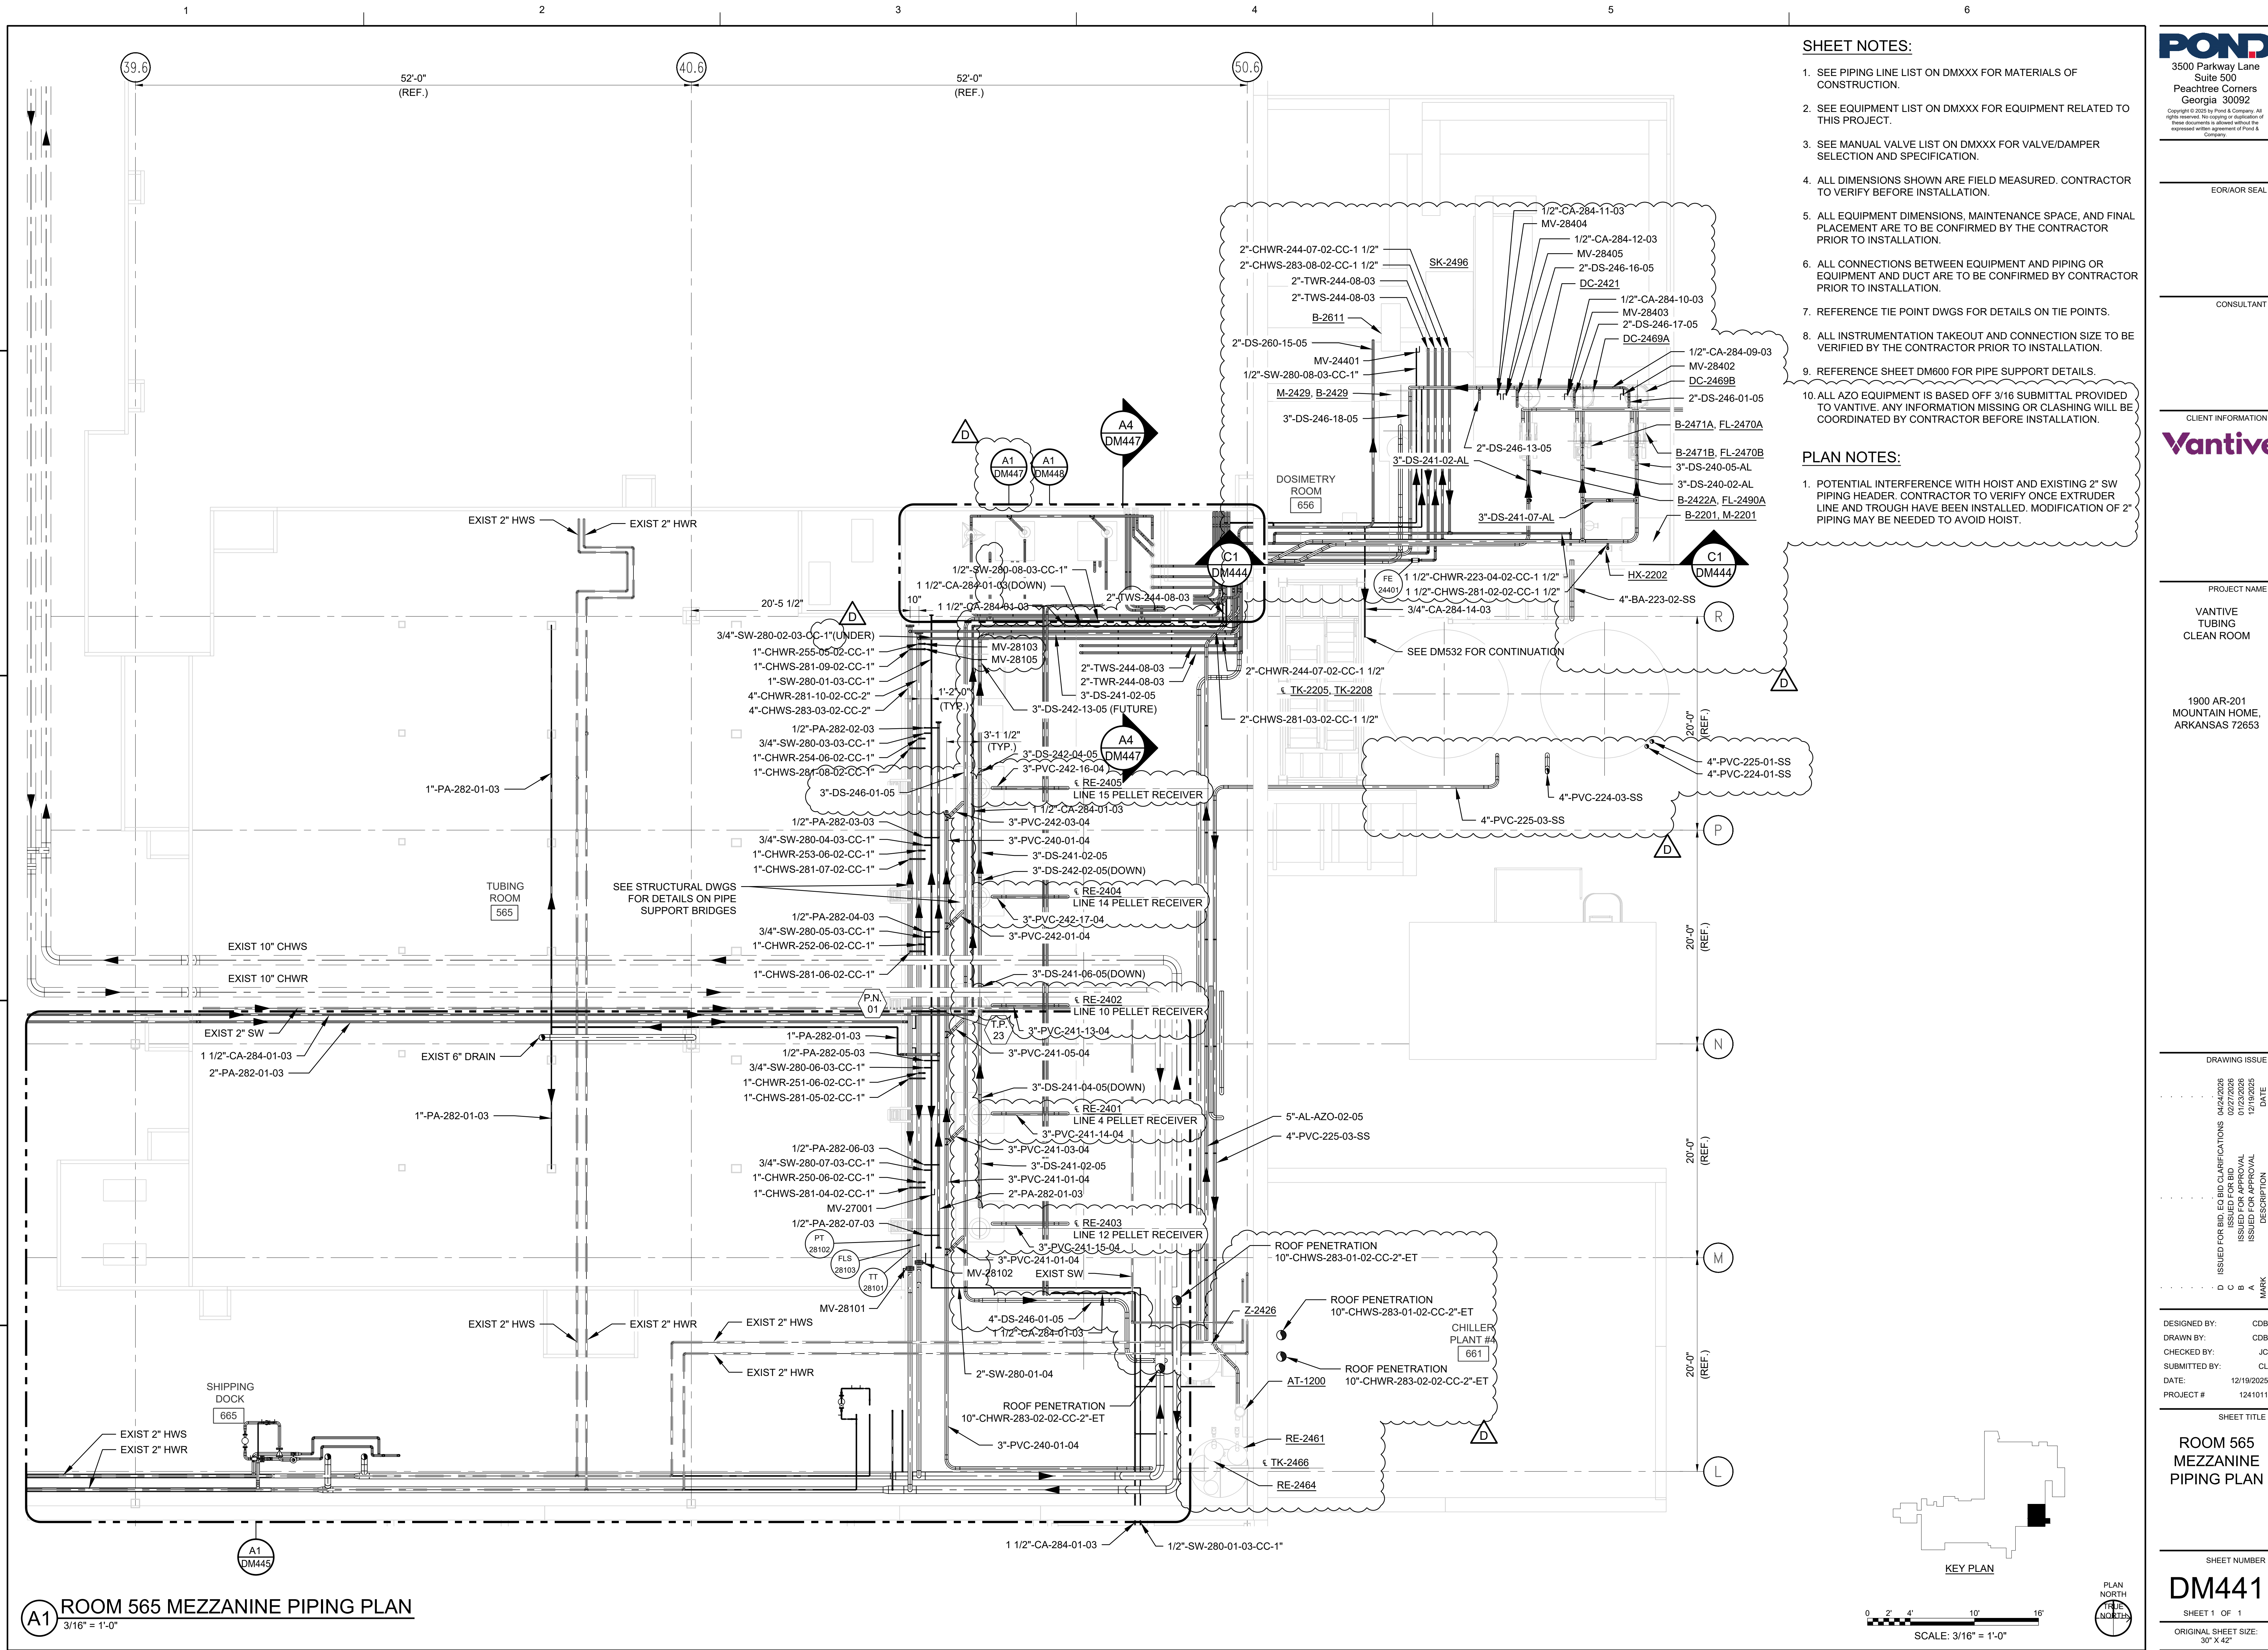

- SHEET NOTES:**
- SEE PIPING LINE LIST ON DMXXX FOR MATERIALS OF CONSTRUCTION.
 - SEE EQUIPMENT LIST ON DMXXX FOR EQUIPMENT RELATED TO THIS PROJECT.
 - SEE MANUAL VALVE LIST ON DMXXX FOR VALVE/DAMPER SELECTION AND SPECIFICATION.
 - ALL DIMENSIONS SHOWN ARE FIELD MEASURED. CONTRACTOR TO VERIFY BEFORE INSTALLATION.
 - ALL EQUIPMENT DIMENSIONS, MAINTENANCE SPACE, AND FINAL PLACEMENT ARE TO BE CONFIRMED BY THE CONTRACTOR PRIOR TO INSTALLATION.
 - ALL CONNECTIONS BETWEEN EQUIPMENT AND PIPING OR EQUIPMENT AND DUCT ARE TO BE CONFIRMED BY CONTRACTOR PRIOR TO INSTALLATION.
 - REFERENCE TIE POINT DWGS FOR DETAILS ON TIE POINTS.
 - ALL INSTRUMENTATION TAKEOUT AND CONNECTION SIZE TO BE VERIFIED BY THE CONTRACTOR PRIOR TO INSTALLATION.
 - REFERENCE SHEET DM600 FOR PIPE SUPPORT DETAILS.
 - ALL AZO EQUIPMENT IS BASED OFF 3/16 SUBMITTAL PROVIDED TO VANTIVE. ANY INFORMATION MISSING OR CLASHING WILL BE COORDINATED BY CONTRACTOR BEFORE INSTALLATION.
- PLAN NOTES:**
- POTENTIAL INTERFERENCE WITH HOIST AND EXISTING 2" SW PIPING HEADER. CONTRACTOR TO VERIFY ONCE EXTRUDER LINE AND TROUGH HAVE BEEN INSTALLED. MODIFICATION OF 2" PIPING MAY BE NEEDED TO AVOID HOIST.

POND
3500 Parkway Lane
Suite 500
Peachtree Corners
Georgia 30092
Copyright © 2025 by POND & COMPANY. All rights reserved. No copying or duplication of these documents is allowed without the expressed written agreement of POND & COMPANY.

EOR/AOR SEAL

CONSULTANT

CLIENT INFORMATION

Vantive

PROJECT NAME

VANTIVE
TUBING
CLEAN ROOM

1900 AR-201
MOUNTAIN HOME,
ARKANSAS 72653

DRAWING ISSUE

DATE	DESCRIPTION	MARK
04/24/2025	ISSUED FOR BID	D
02/27/2025	ISSUED FOR BID	C
01/22/2025	ISSUED FOR BID	B
12/19/2024	ISSUED FOR BID	A

DESIGNED BY: CDB
DRAWN BY: CDB
CHECKED BY: JC
SUBMITTED BY: CL
DATE: 12/19/2025
PROJECT #: 1241011

SHEET TITLE

**ROOM 565
MEZZANINE
PIPING PLAN**

SHEET NUMBER

DM441

SHEET 1 OF 1
ORIGINAL SHEET SIZE:
30" X 42"

KEY PLAN

PLAN NORTH

SCALE: 3/16" = 1'-0"

ISSUED FOR BID