



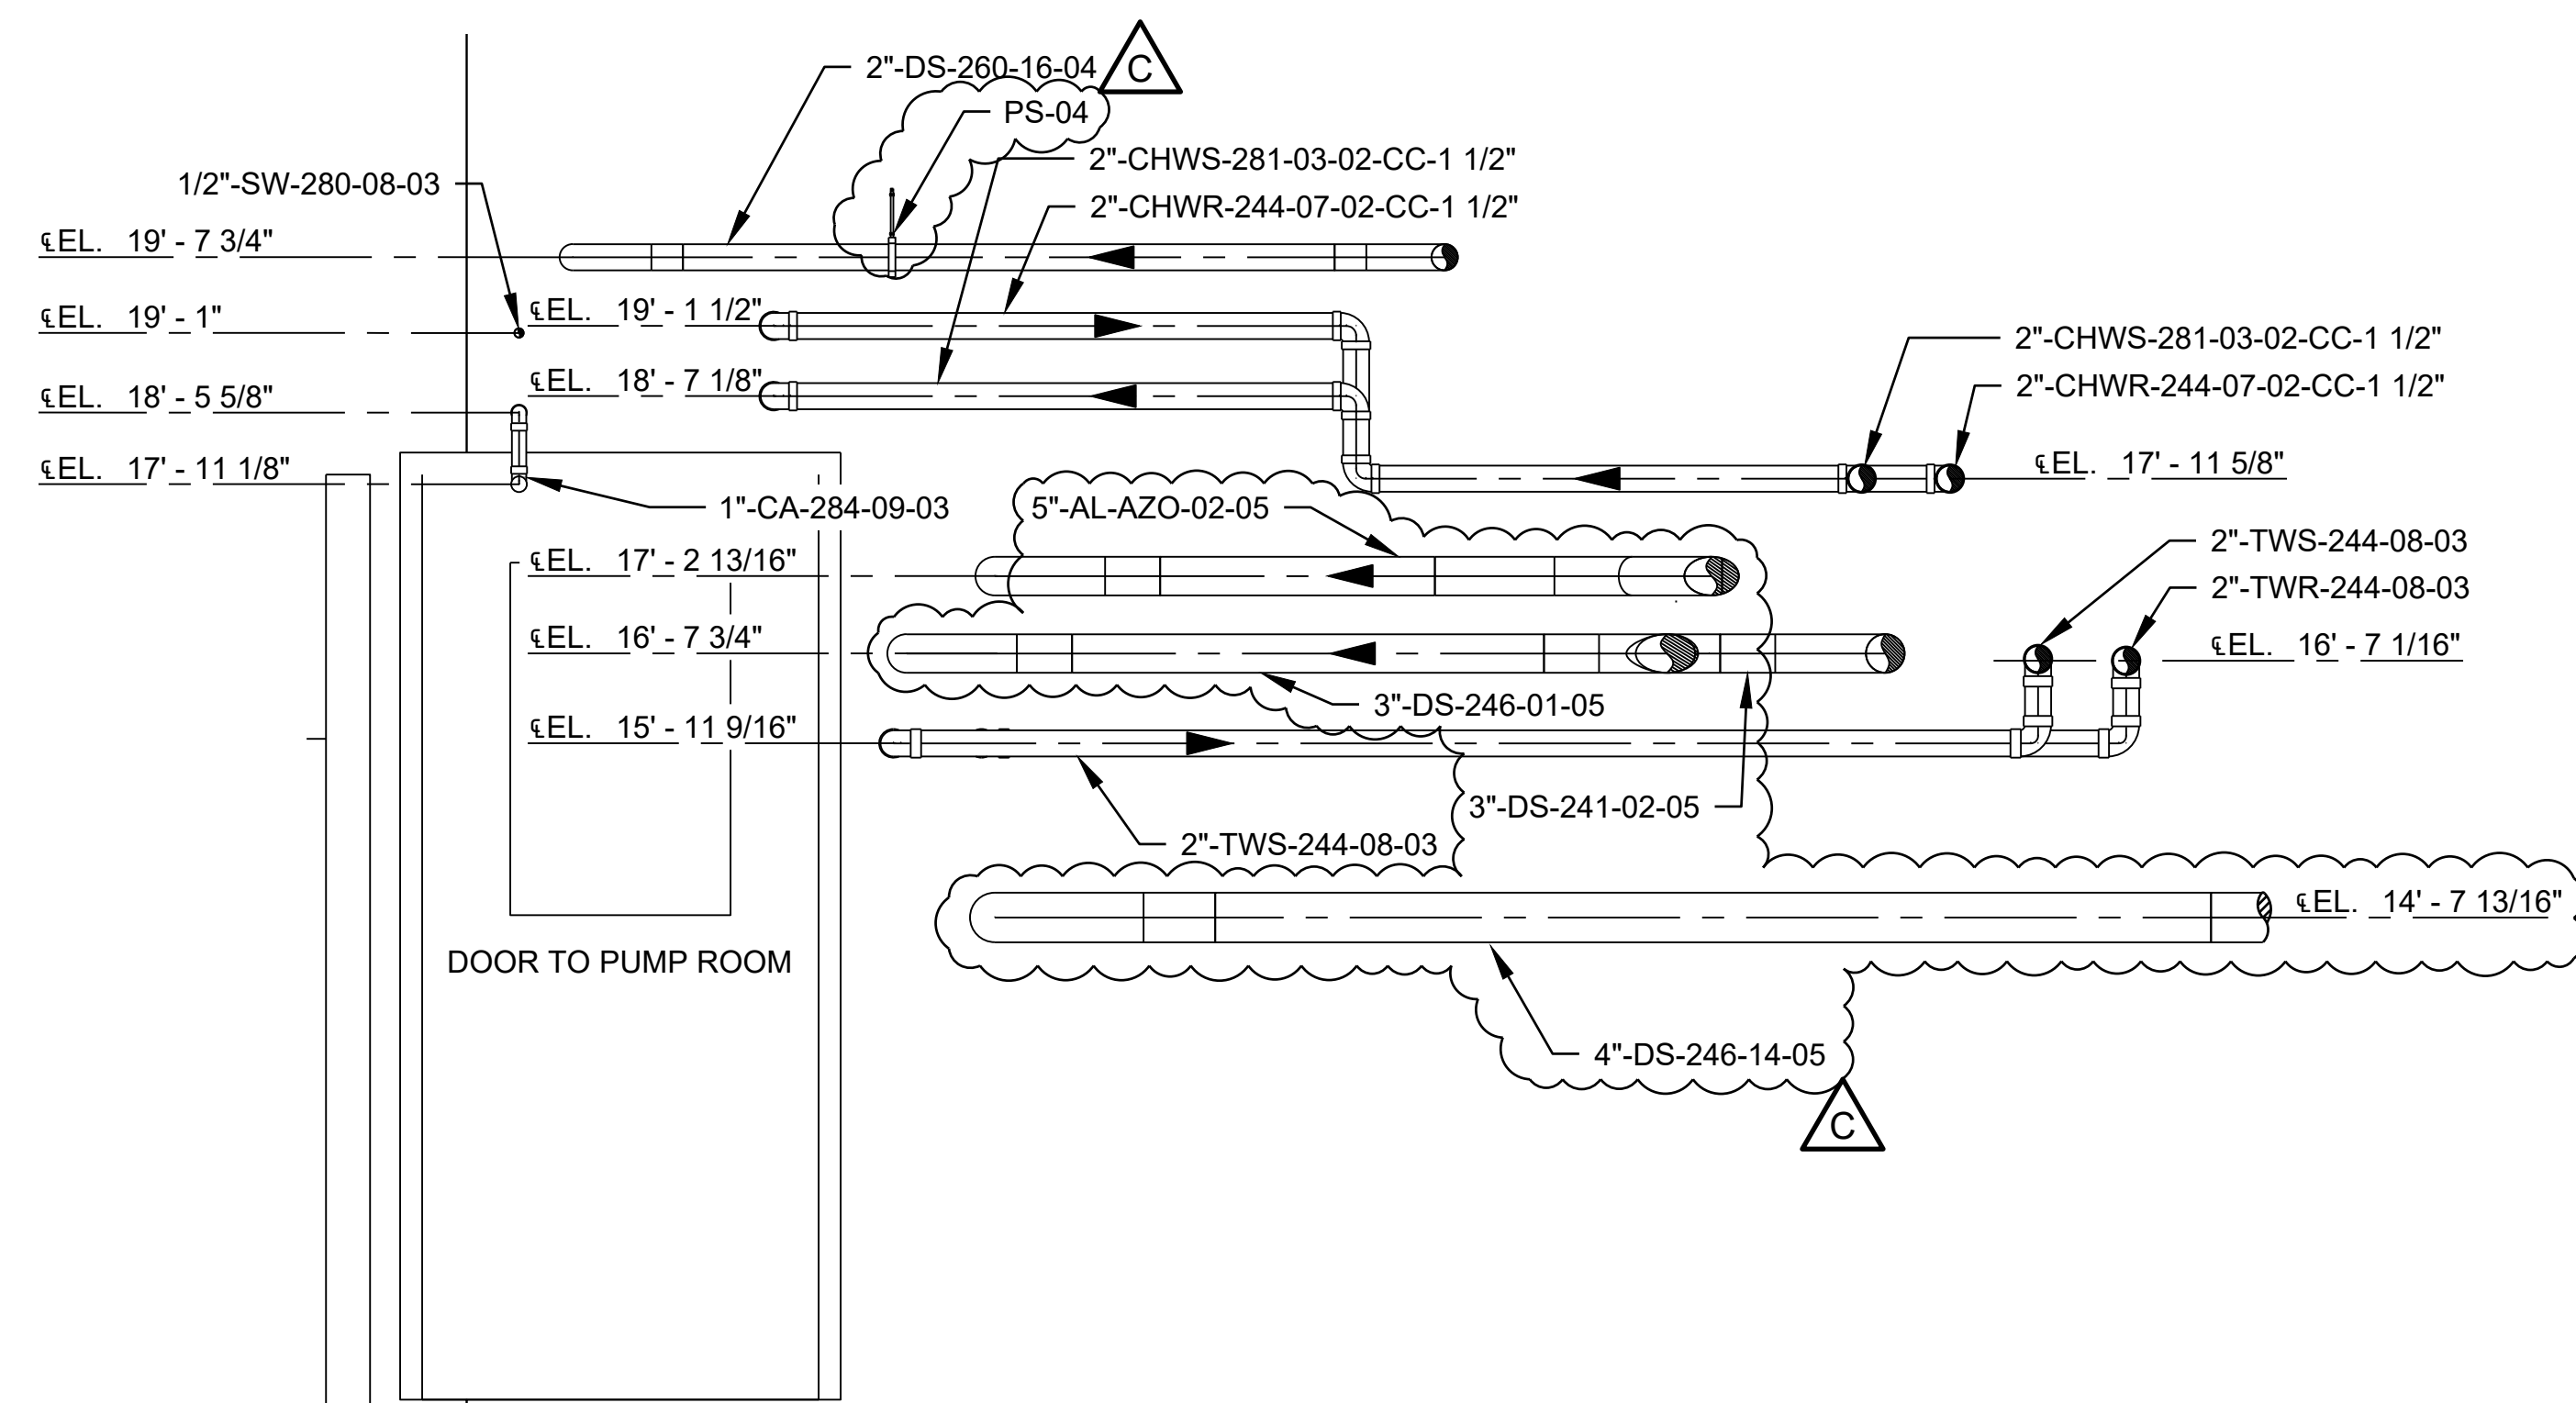

(C3) PUMP ROOM ENTRANCE PIPING ELEVATION VIEW
3/4" = 1'-0"

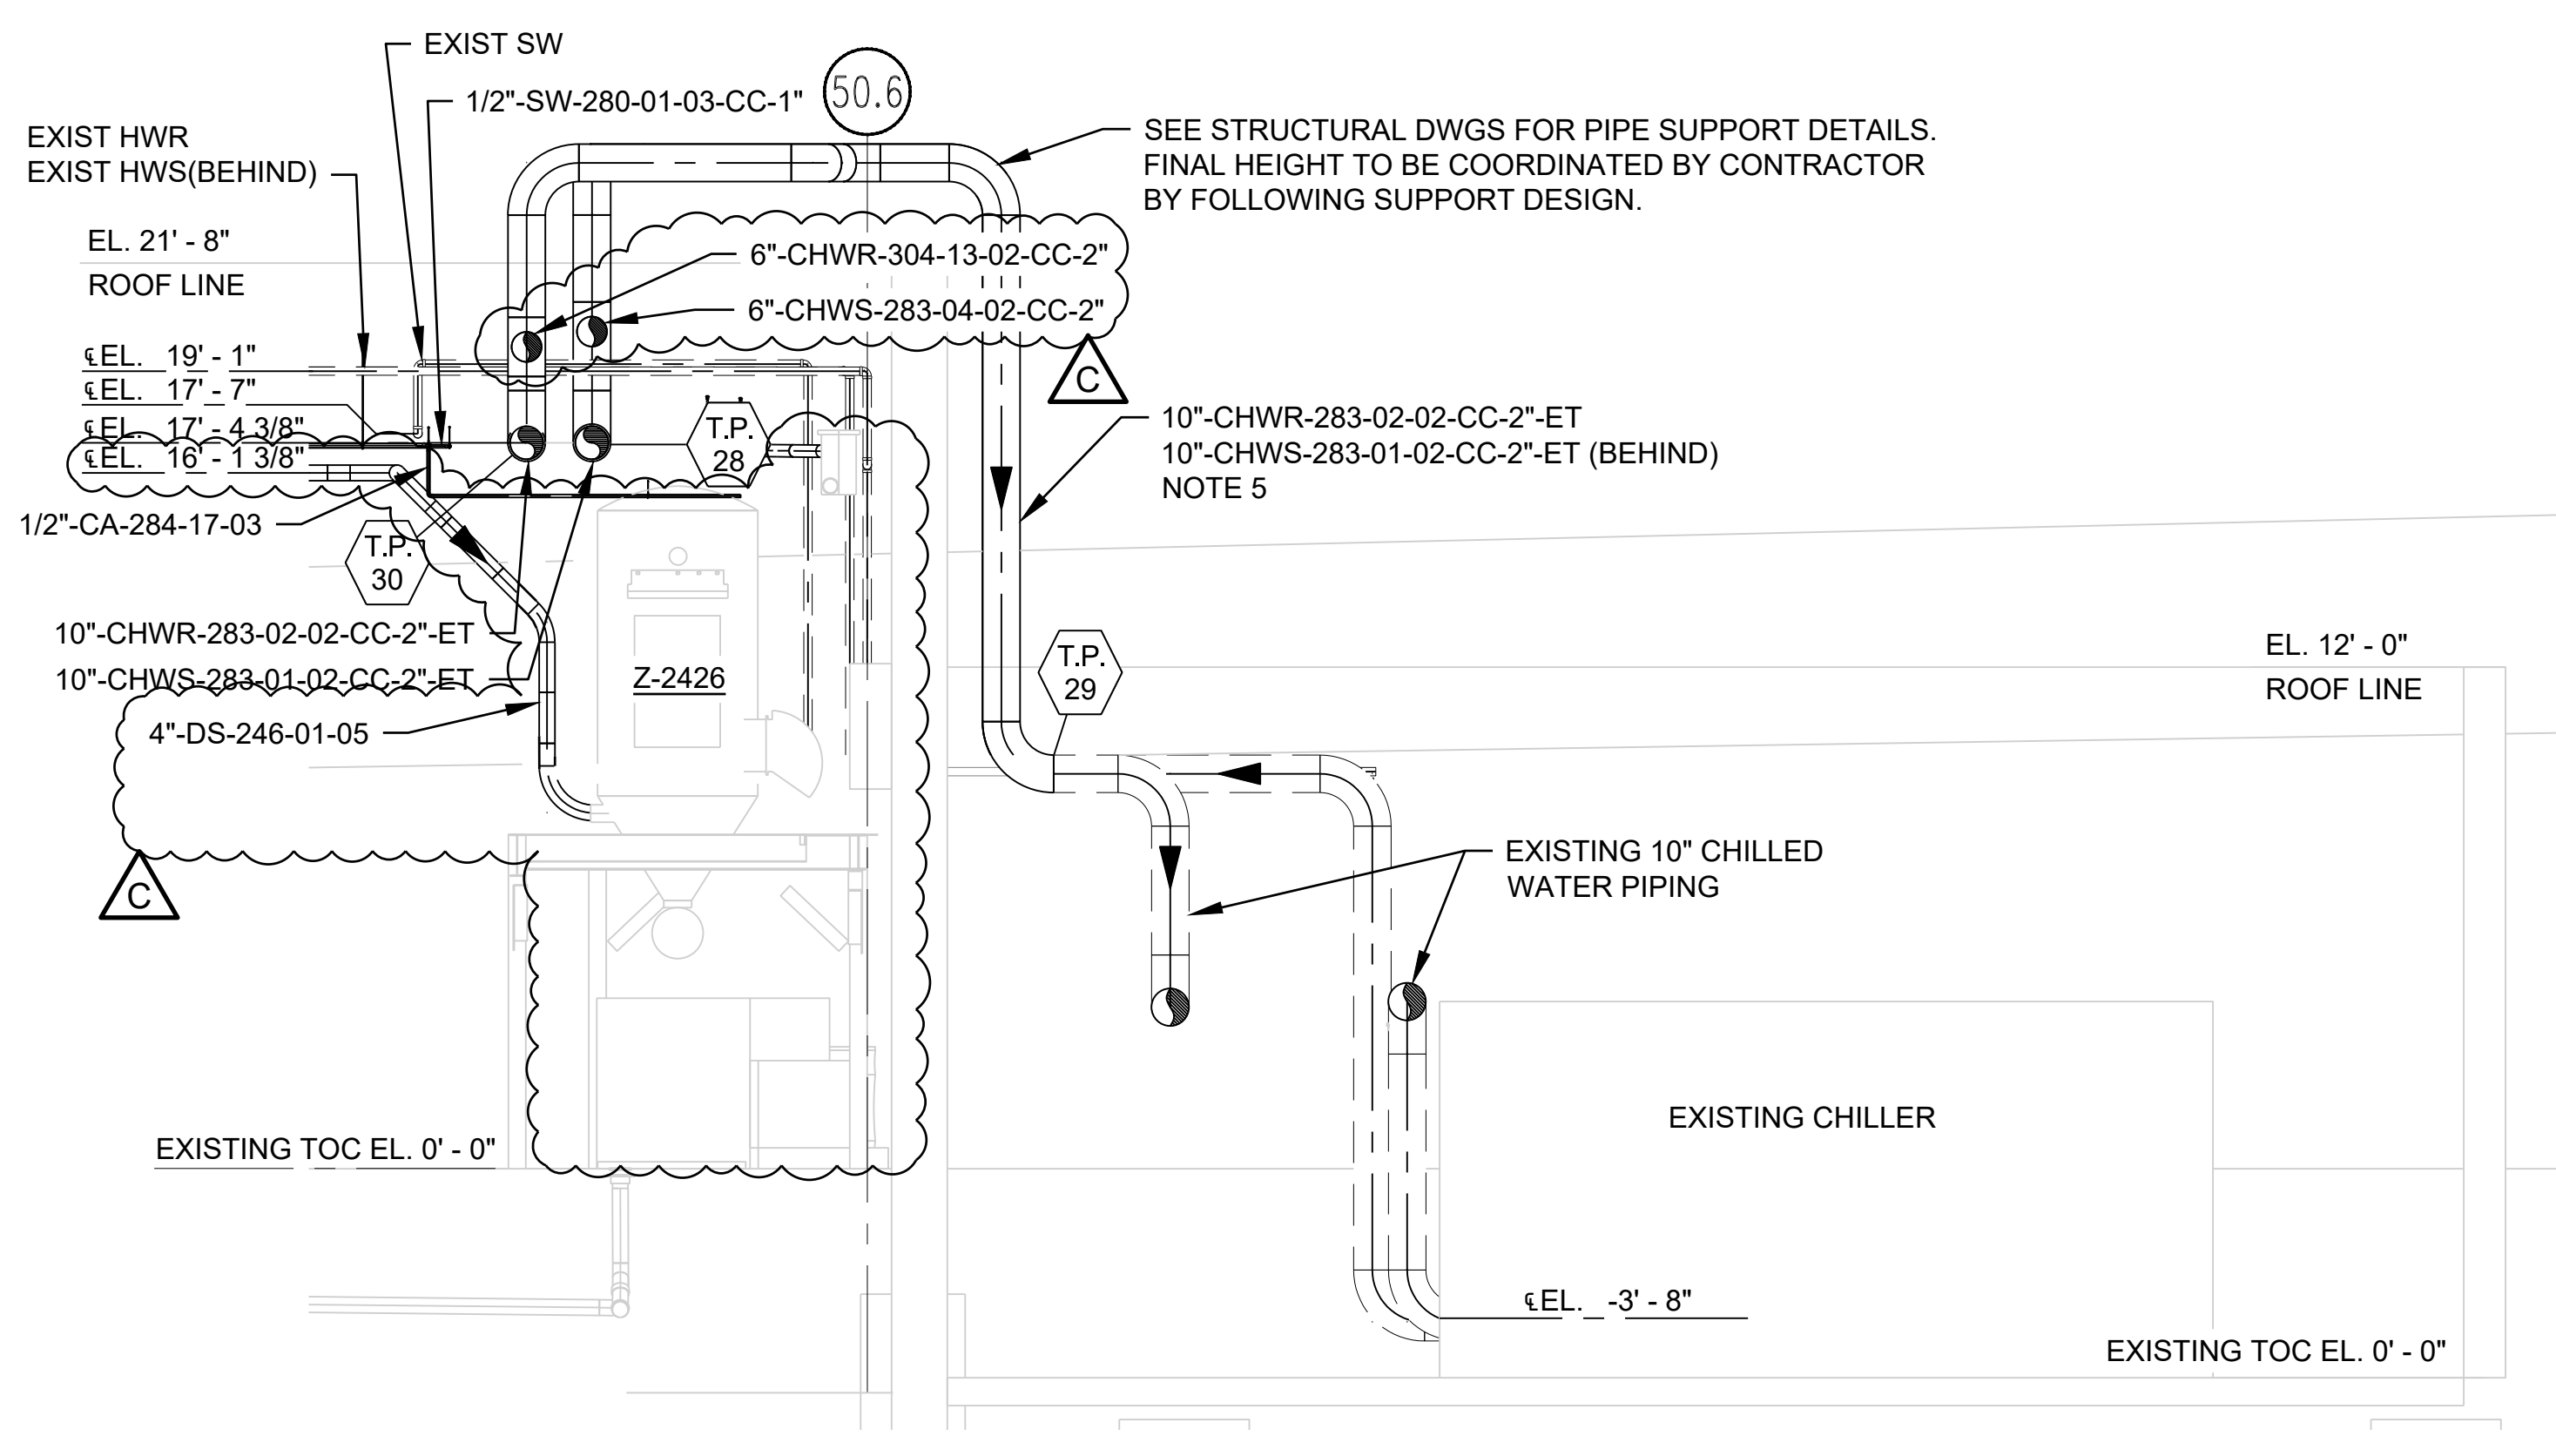

(A3) CHILLER PLANT 4 ELEVATION VIEW
1/4" = 1'-0"

1. SEE PIPING LINE LIST ON DMXXX FOR MATERIALS OF CONSTRUCTION.
2. SEE EQUIPMENT LIST ON DMXXX FOR EQUIPMENT RELATED TO THIS PROJECT.
3. SEE MANUAL VALVE LIST ON DMXXX FOR VALVE/DAMPER SELECTION AND SPECIFICATION.
4. ALL DIMENSIONS SHOWN ARE FIELD MEASURED. CONTRACTOR TO VERIFY BEFORE INSTALLATION.
5. ALL OUTSIDE PIPING TO BE HEAT TRACED.
6. ALL EQUIPMENT DIMENSIONS, MAINTENANCE SPACE, AND FINAL PLACEMENT ARE TO BE CONFIRMED BY THE CONTRACTOR PRIOR TO INSTALLATION.
7. ALL CONNECTIONS BETWEEN EQUIPMENT AND PIPING OR EQUIPMENT AND DUCT ARE TO BE CONFIRMED BY CONTRACTOR PRIOR TO INSTALLATION.
8. REFERENCE TIE POINT DWGS FOR DETAILS ON TIE POINTS.

9. REFERENCE SHEET DM600 FOR PIPE SUPPORT DETAILS.

10. ALL AZO EQUIPMENT IS BASED OFF 3/16 SUBMITTAL PROVIDED TO VANTIVE. ANY INFORMATION MISSING OR CLASHING WILL BE COORDINATED BY CONTRACTOR BEFORE INSTALLATION.

VANTIVE
TUBING
CLEAN ROOM

1900 AR-201
MOUNTAIN HOME,
ARKANSAS 72653

MARK	A	DESCRIPTION	ISSUED FOR BID	ISSUED FOR APPROVAL	DATE
C		ISSUED FOR BID, EQ BID CLARIFICATIONS			04/24/2026
B		ISSUED FOR BID			02/27/2026
A		ISSUED FOR APPROVAL			01/23/2026

DESIGNED BY: CDB
DRAWN BY: CDB
CHECKED BY: JC
SUBMITTED BY: CL
DATE: 01/23/2026
PROJECT # 1241011


CHILLER ROOM
AND
BREAKER PLATE
ROOM
PIPING PLAN

DM443

SHEET 1 OF 1

ORIGINAL SHEET SIZE:
30" X 42"

ISSUED FOR BID

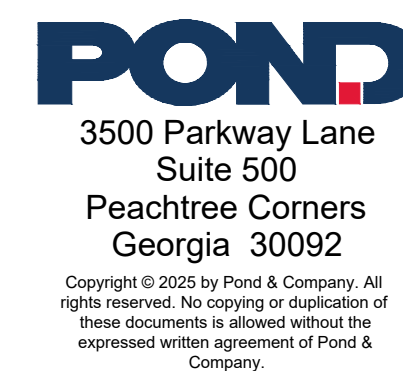

EOR/AOR SEAL

CONSULTANT

CLIENT INFORMATION

PROJECT NAME

VANTIVE
TUBING
CLEAN ROOM

1900 AR-201
MOUNTAIN HOME,
ARKANSAS 72653

DRAWING ISSUE

MARK	DESCRIPTION	ISSUED FOR APPROVAL	ISSUED FOR BID	C	04/24/2026
A					02/27/2026
B					01/23/2026

DESIGNED BY: CDB
DRAWN BY: CDB
CHECKED BY: JC
SUBMITTED BY: CL
DATE: 01/23/2026
PROJECT # 1241011

CHILLER ROOM
AND
BREAKER PLATE
ROOM
PIPING PLAN

SHEET NUMBER

DM443

SHEET 1 OF 1

ORIGINAL SHEET SIZE:
30" X 42"

ISSUED FOR BID