



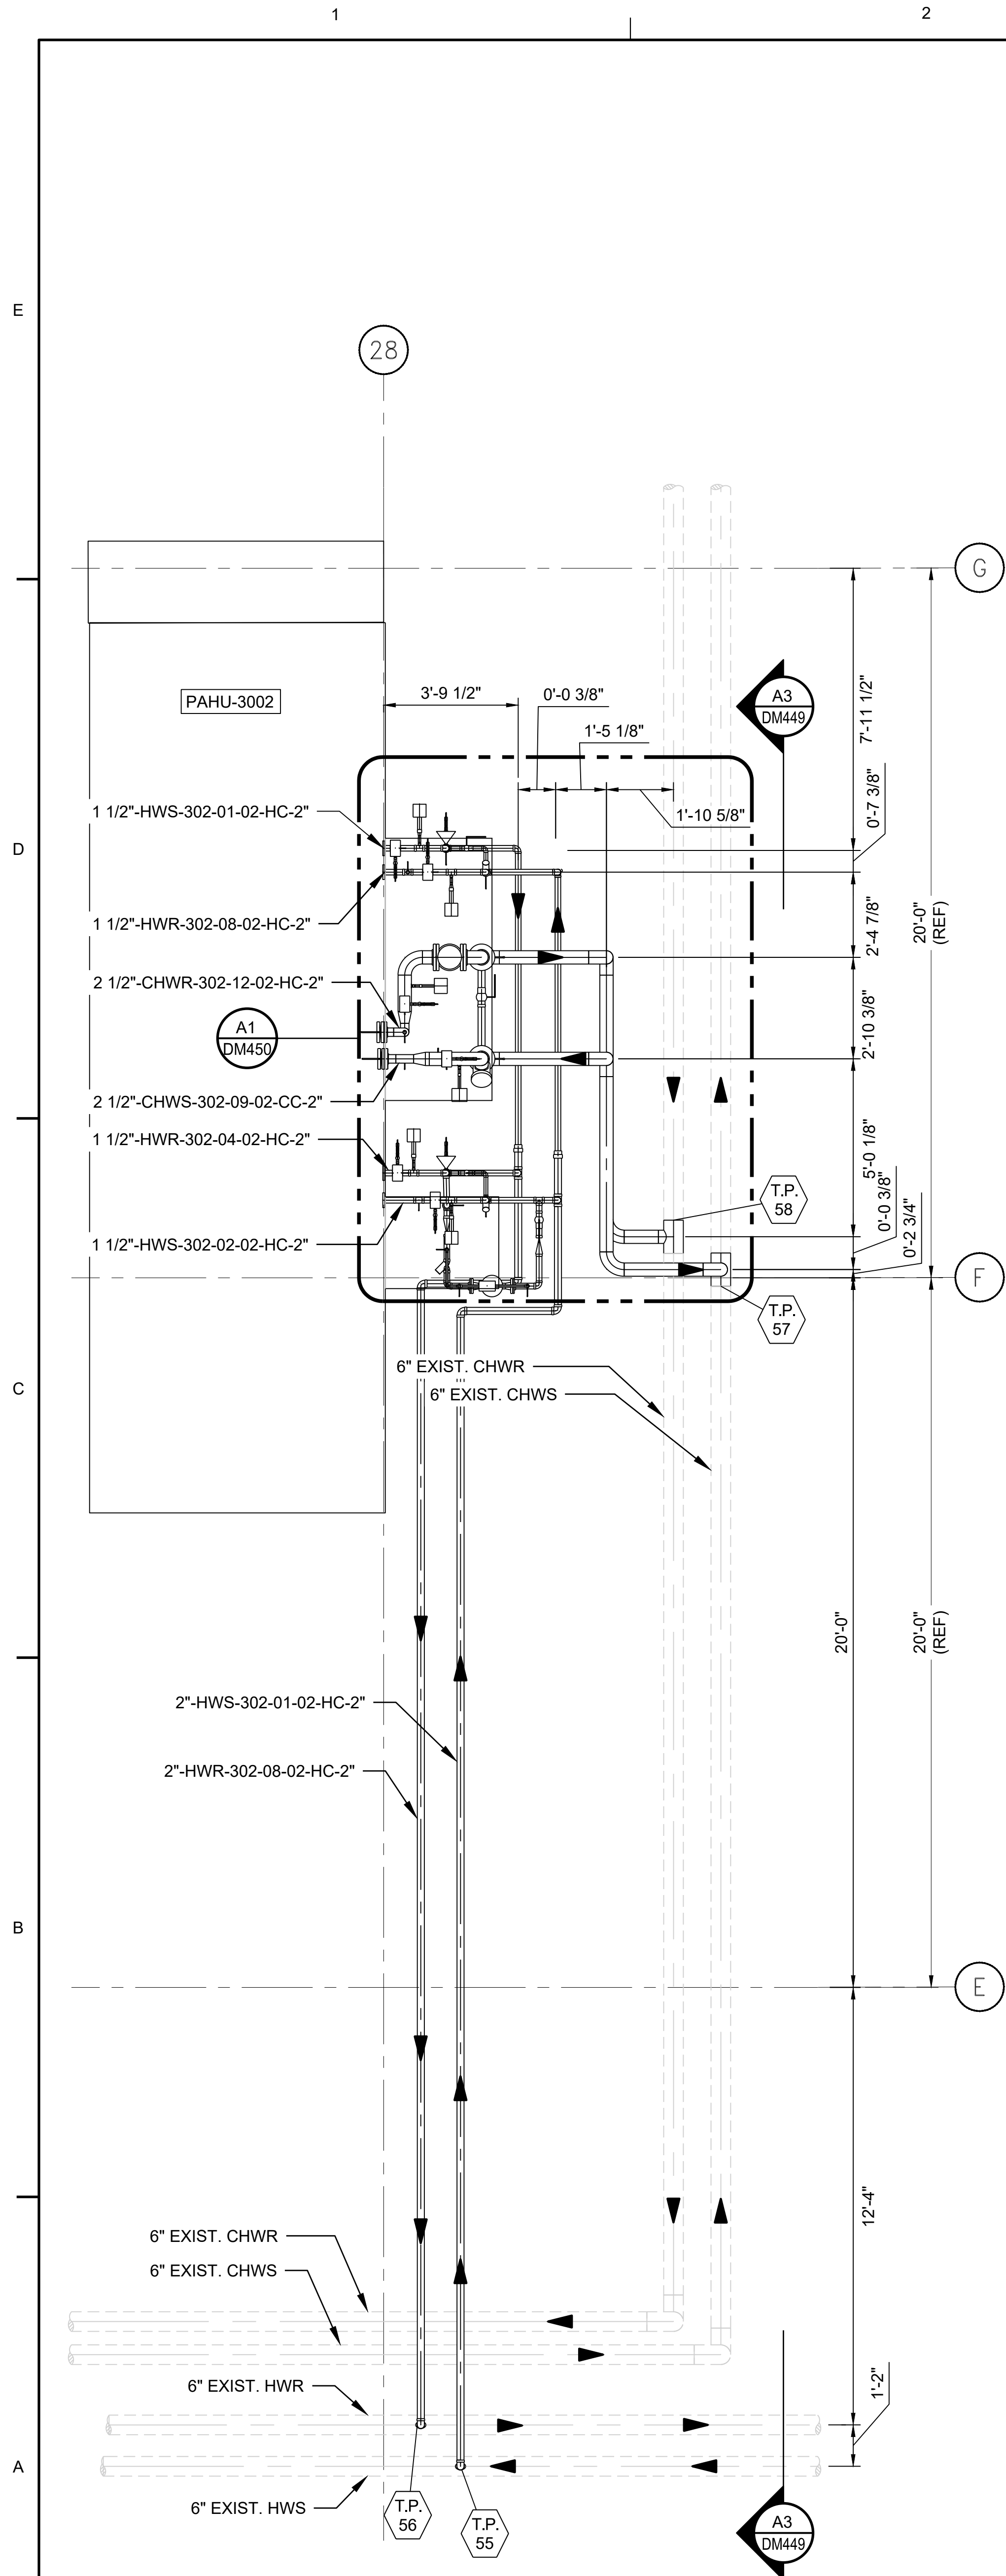

A1 ROOM 510 AIR HANDLING UNIT PLAN VIEW
1" = 1'-0"

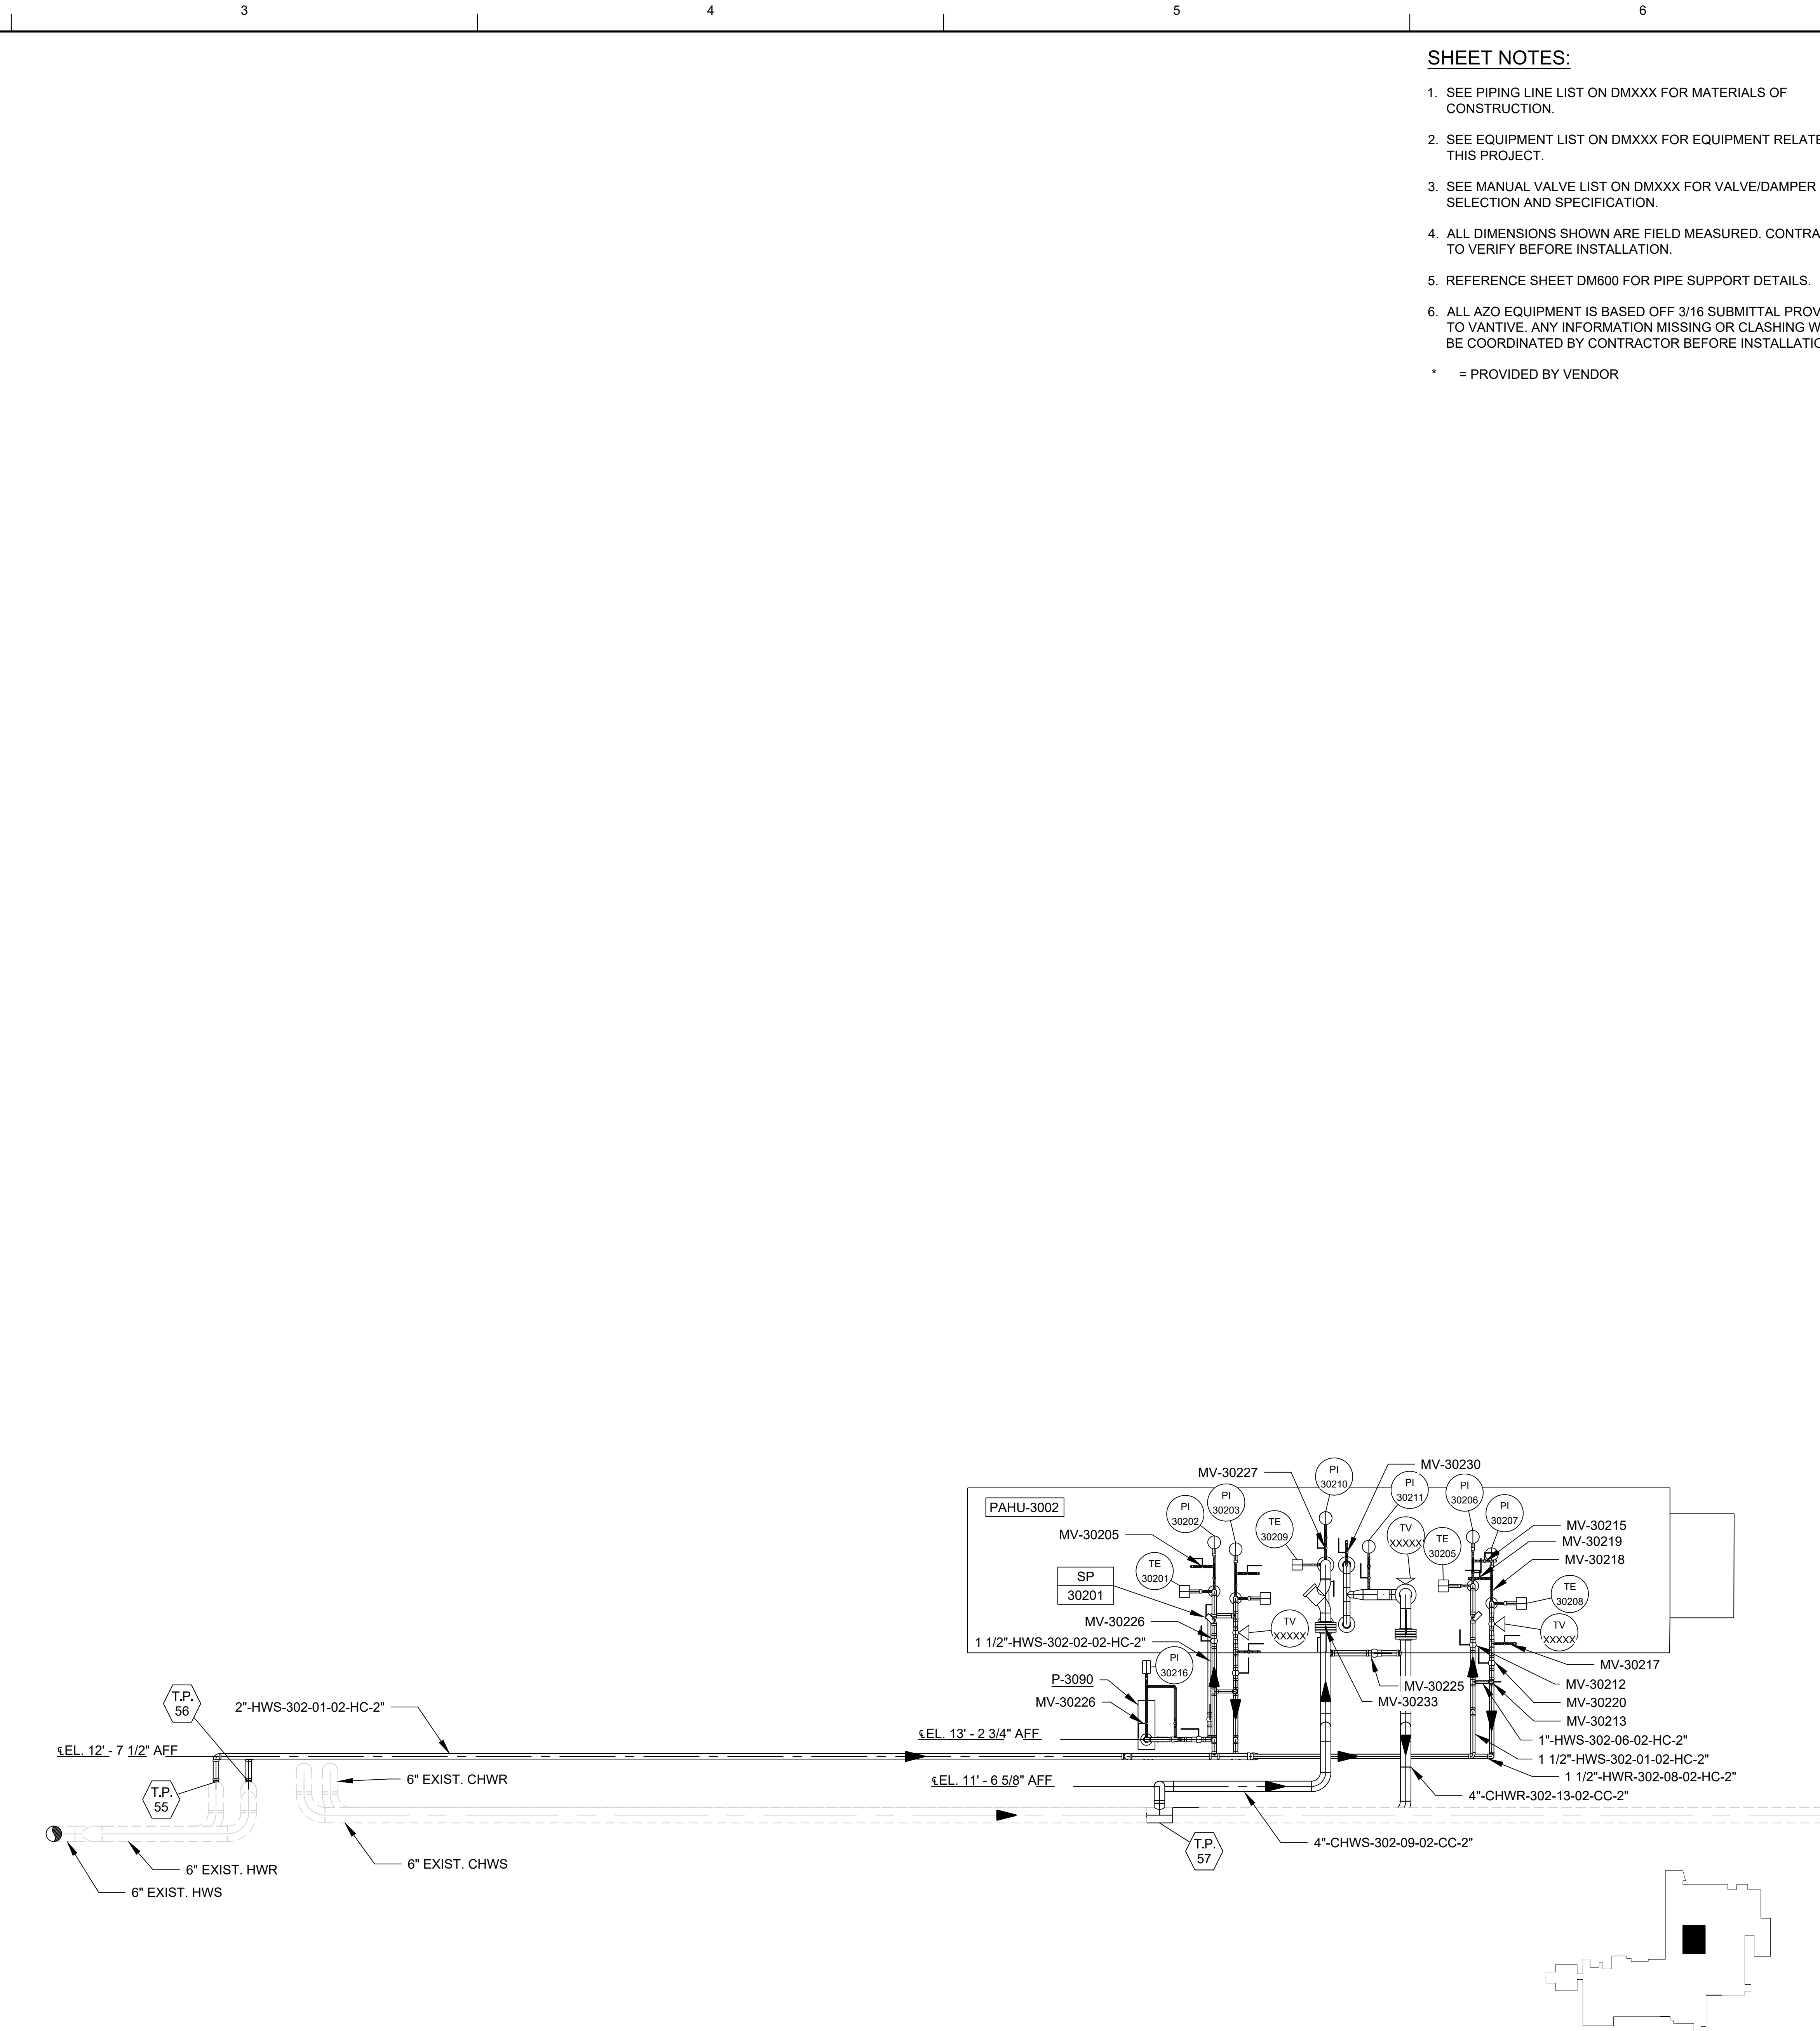

A3 ROOM 510 AIR HANDLING UNIT ELEVATION VIEW
1" = 1'-0"

SHEET NOTES:

1. SEE PIPING LINE LIST ON DMXXX FOR MATERIALS OF CONSTRUCTION.
2. SEE EQUIPMENT LIST ON DMXXX FOR EQUIPMENT RELATED TO THIS PROJECT.
3. SEE MANUAL VALVE LIST ON DMXXX FOR VALVE/DAMPER SELECTION AND SPECIFICATION.
4. ALL DIMENSIONS SHOWN ARE FIELD MEASURED. CONTRACTOR TO VERIFY BEFORE INSTALLATION.
5. REFERENCE SHEET DM600 FOR PIPE SUPPORT DETAILS.
6. ALL AZO EQUIPMENT IS BASED OFF 3/16 SUBMITTAL PROVIDED TO VANTIVE. ANY INFORMATION MISSING OR CLASHING WILL BE COORDINATED BY CONTRACTOR BEFORE INSTALLATION.

* = PROVIDED BY VENDOR

EOR/AOR SEAL

CONSULTANT

CLIENT INFORMATION

Vantive

PROJECT NAME

VANTIVE
TUBING
CLEAN ROOM

1900 AR-201
MOUNTAIN HOME,
ARKANSAS 72653

DRAWING ISSUE

DATE	DESCRIPTION	MARK
04/24/2026	ISSUED FOR BID, EQ BID CLARIFICATIONS	A

DESIGNED BY: FCC
DRAWN BY: FCC
CHECKED BY: JC
SUBMITTED BY: CL
DATE: 04/24/2026
PROJECT #: 1241011

SHEET TITLE

ROOM 510
AHU
PIPING PLANS

SHEET NUMBER

DM449
SHEET 1 OF 1
ORIGINAL SHEET SIZE:
30" X 42"

SCALE: 1" = 1'-0"

ISSUED FOR BID