



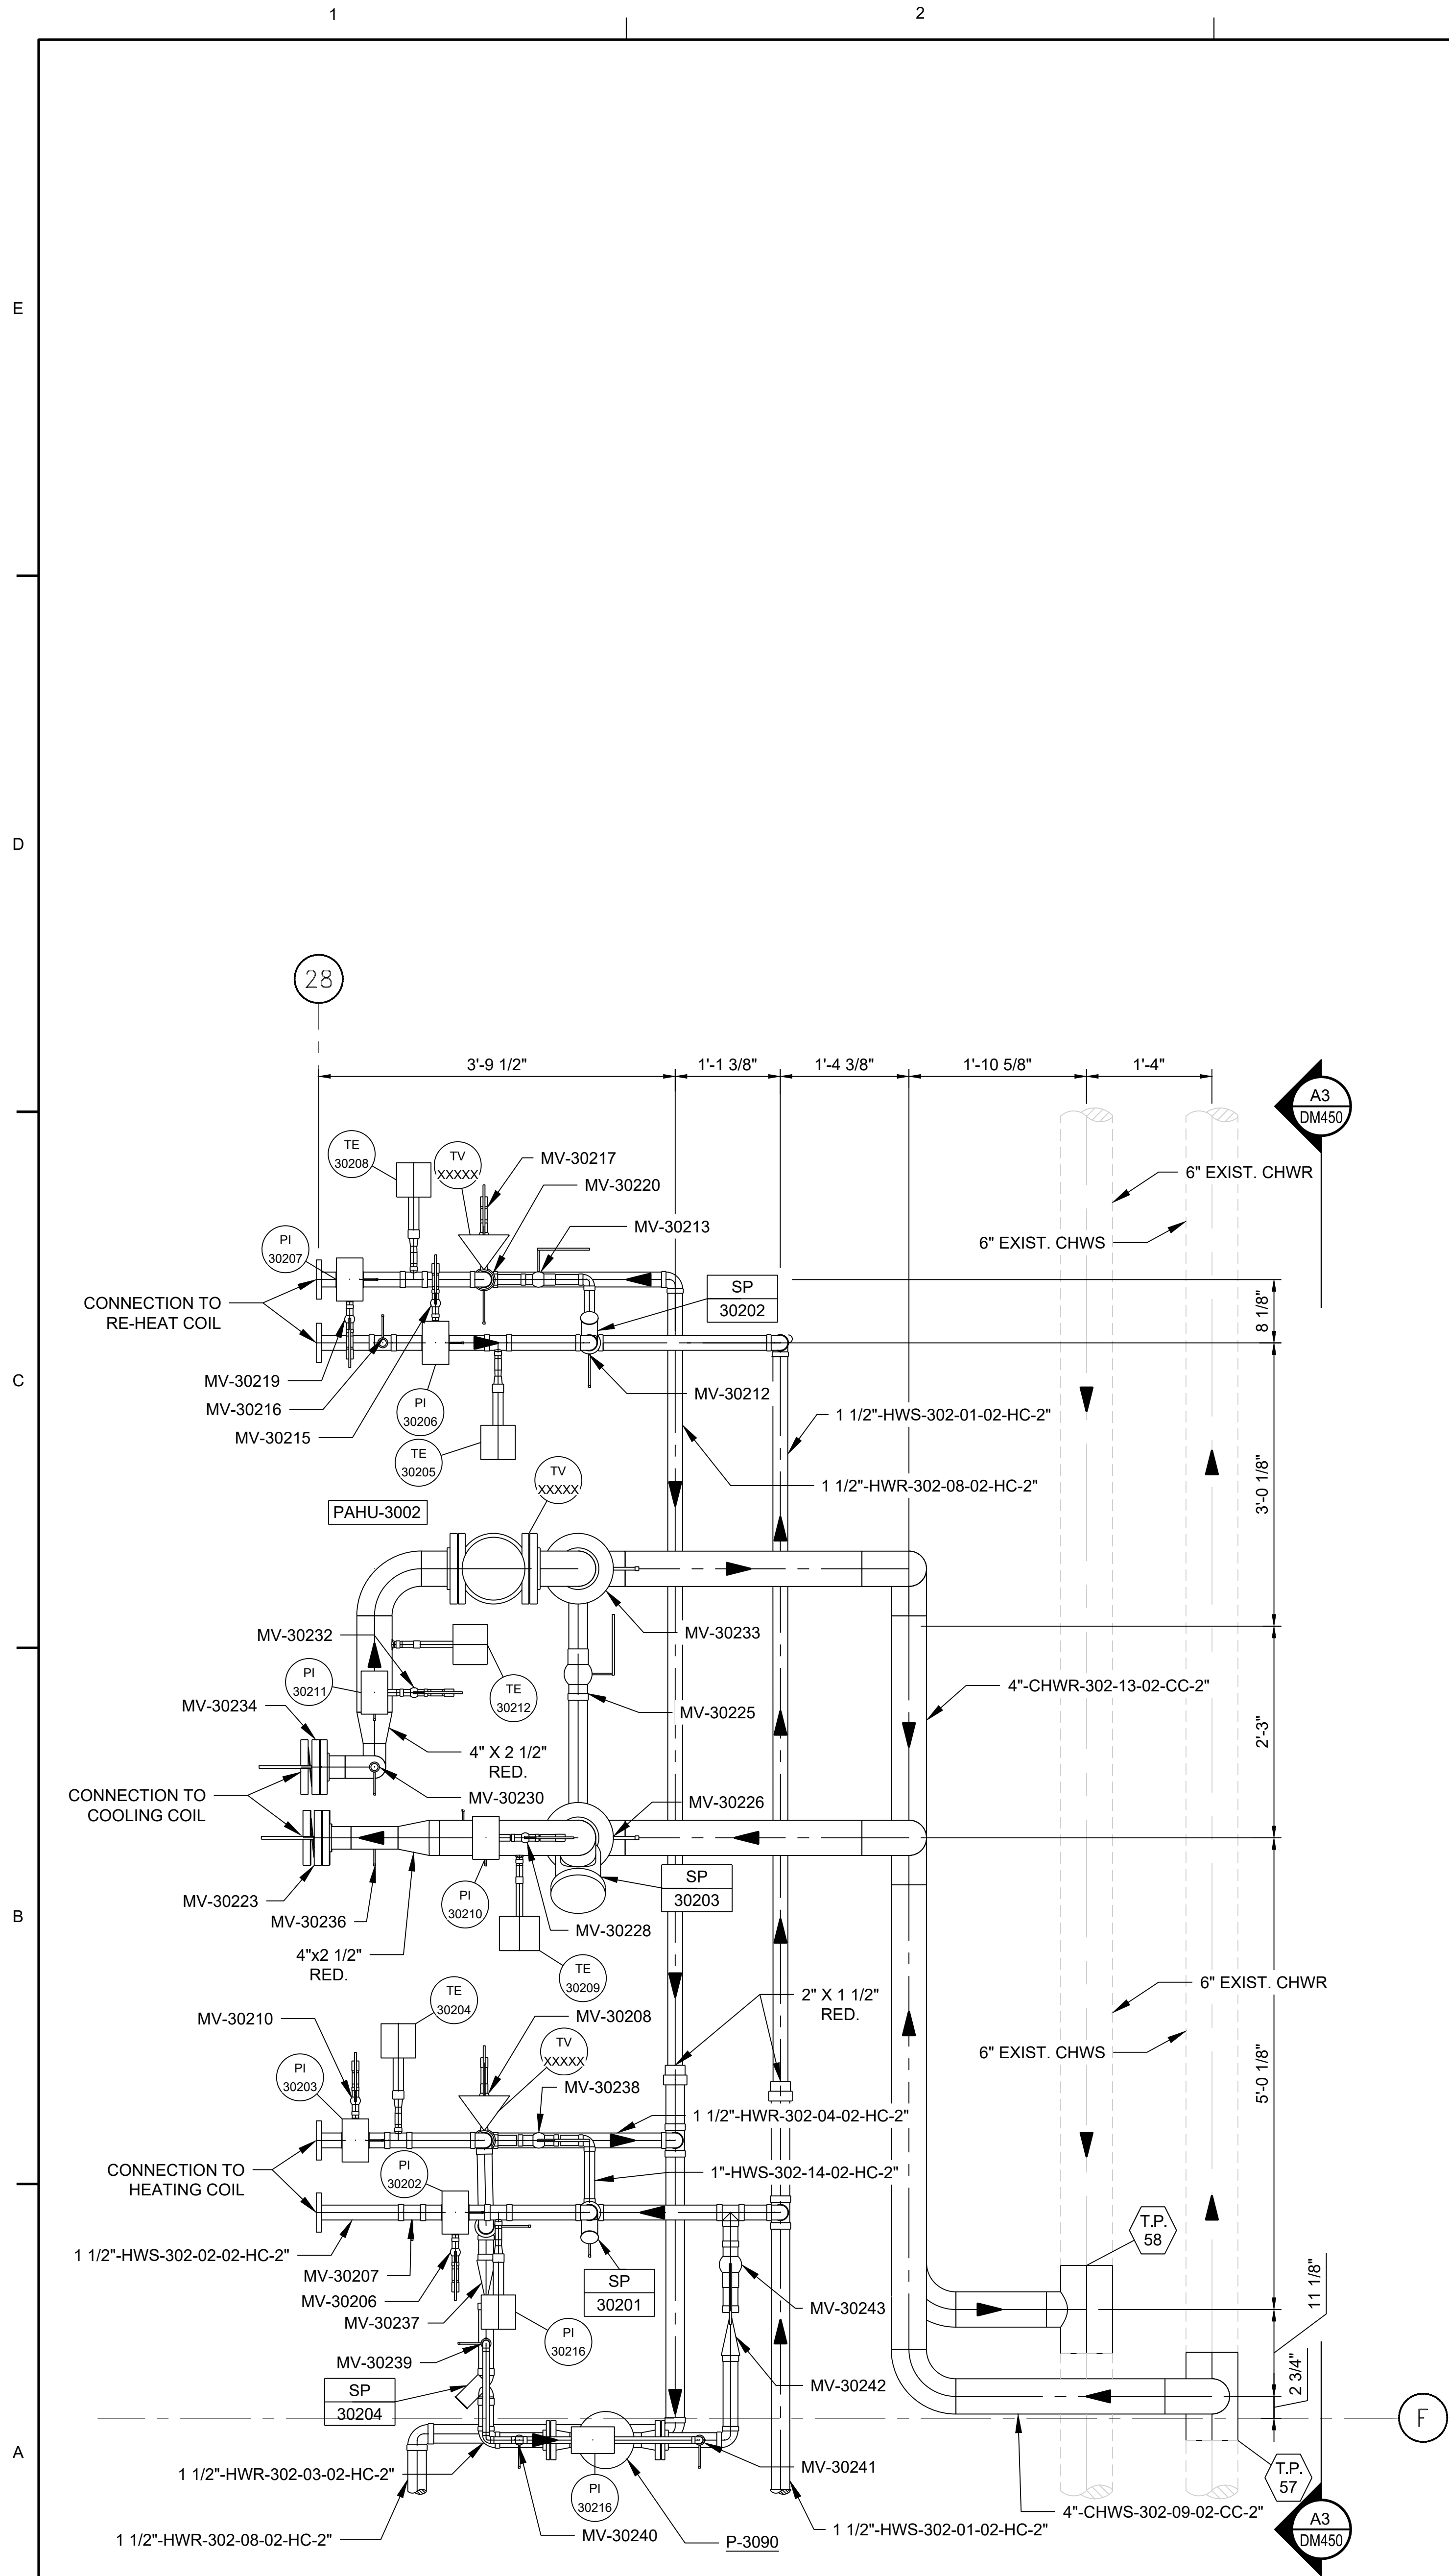

A1 ROOM 510 PAHU-3002 ENLARGED VIEW
1" = 1'-0"

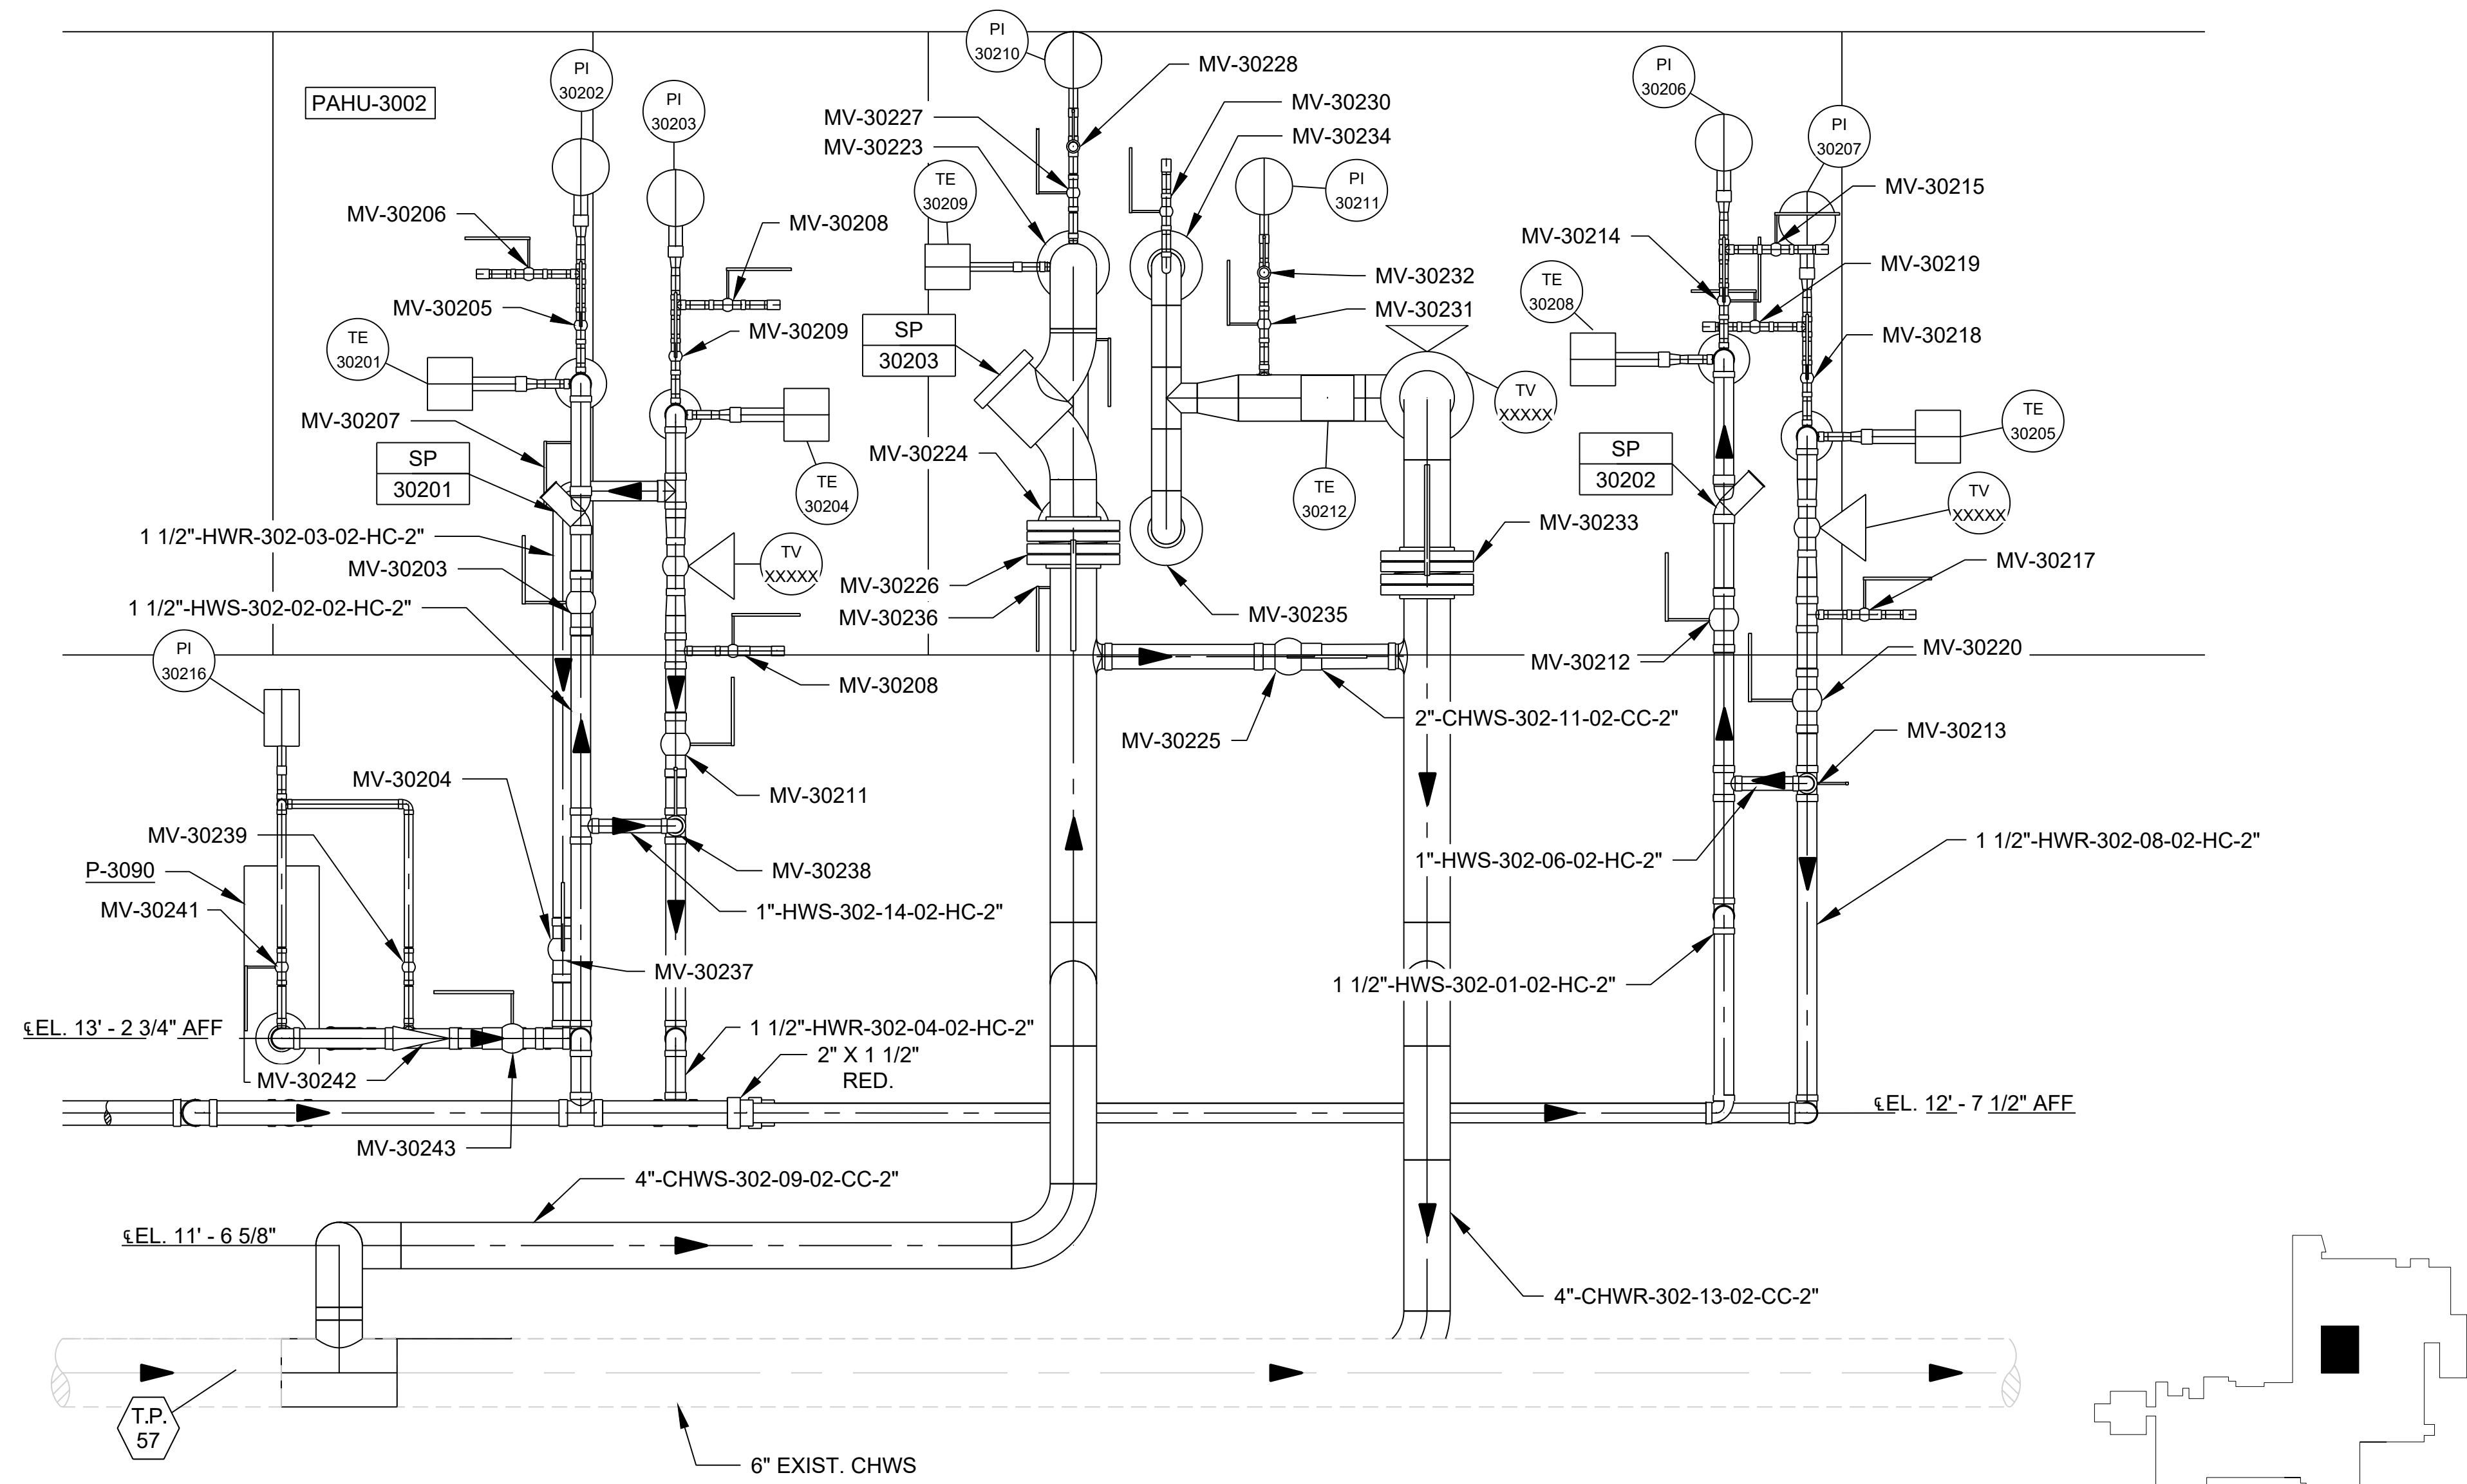

A3 ROOM 510 AIR HANDLING UNIT ELEVATION VIEW
1" = 1'-0"

SHEET NOTES:

1. SEE PIPING LINE LIST ON DMXXX FOR MATERIALS OF CONSTRUCTION.
2. SEE EQUIPMENT LIST ON DMXXX FOR EQUIPMENT RELATED TO THIS PROJECT.
3. SEE MANUAL VALVE LIST ON DMXXX FOR VALVE/DAMPER SELECTION AND SPECIFICATION.
4. ALL DIMENSIONS SHOWN ARE FIELD MEASURED. CONTRACTOR TO VERIFY BEFORE INSTALLATION.
5. REFERENCE SHEET DM600 FOR PIPE SUPPORT DETAILS.
6. ALL AZO EQUIPMENT IS BASED OFF 3/16 SUBMITTAL PROVIDED TO VANTIVE. ANY INFORMATION MISSING OR CLASHING WILL BE COORDINATED BY CONTRACTOR BEFORE INSTALLATION.

POND
3500 Parkway Lane
Suite 500
Peachtree Corners
Georgia 30092
Copyright © 2023 by Pond & Company. All rights reserved. No copying or duplication of these documents is allowed without the expressed written agreement of Pond & Company.

EOR/AOR SEAL

CONSULTANT

CLIENT INFORMATION

Vantive

PROJECT NAME

VANTIVE
TUBING
CLEAN ROOM

1900 AR-201
MOUNTAIN HOME,
ARKANSAS 72653

DRAWING ISSUE

DATE	DESCRIPTION	MARK
04/24/2026	ISSUED FOR BID. E.O. BID CLARIFICATIONS	A

DESIGNED BY: FCC
DRAWN BY: FCC
CHECKED BY: JC
SUBMITTED BY: CL
DATE: 04/24/2026
PROJECT # 1241011

SHEET TITLE

ROOM 510
AHU
PIPING PLANS

SHEET NUMBER

DM450
SHEET 1 OF 1
ORIGINAL SHEET SIZE:
30" X 42"

0 6" 1' 2' 3'
SCALE: 1" = 1'-0"

PLAN
NORTH
TRUE
NORTH

ISSUED FOR BID