


4/24/2026 3:32:00 PM Autodesk Docs/Baxter and Vantive Mountain Home/BAXTER_VANTIVE Mountain Home/BAXTER_VANTIVE Master Base File_MECH/ELEC/CP_V05.rvt

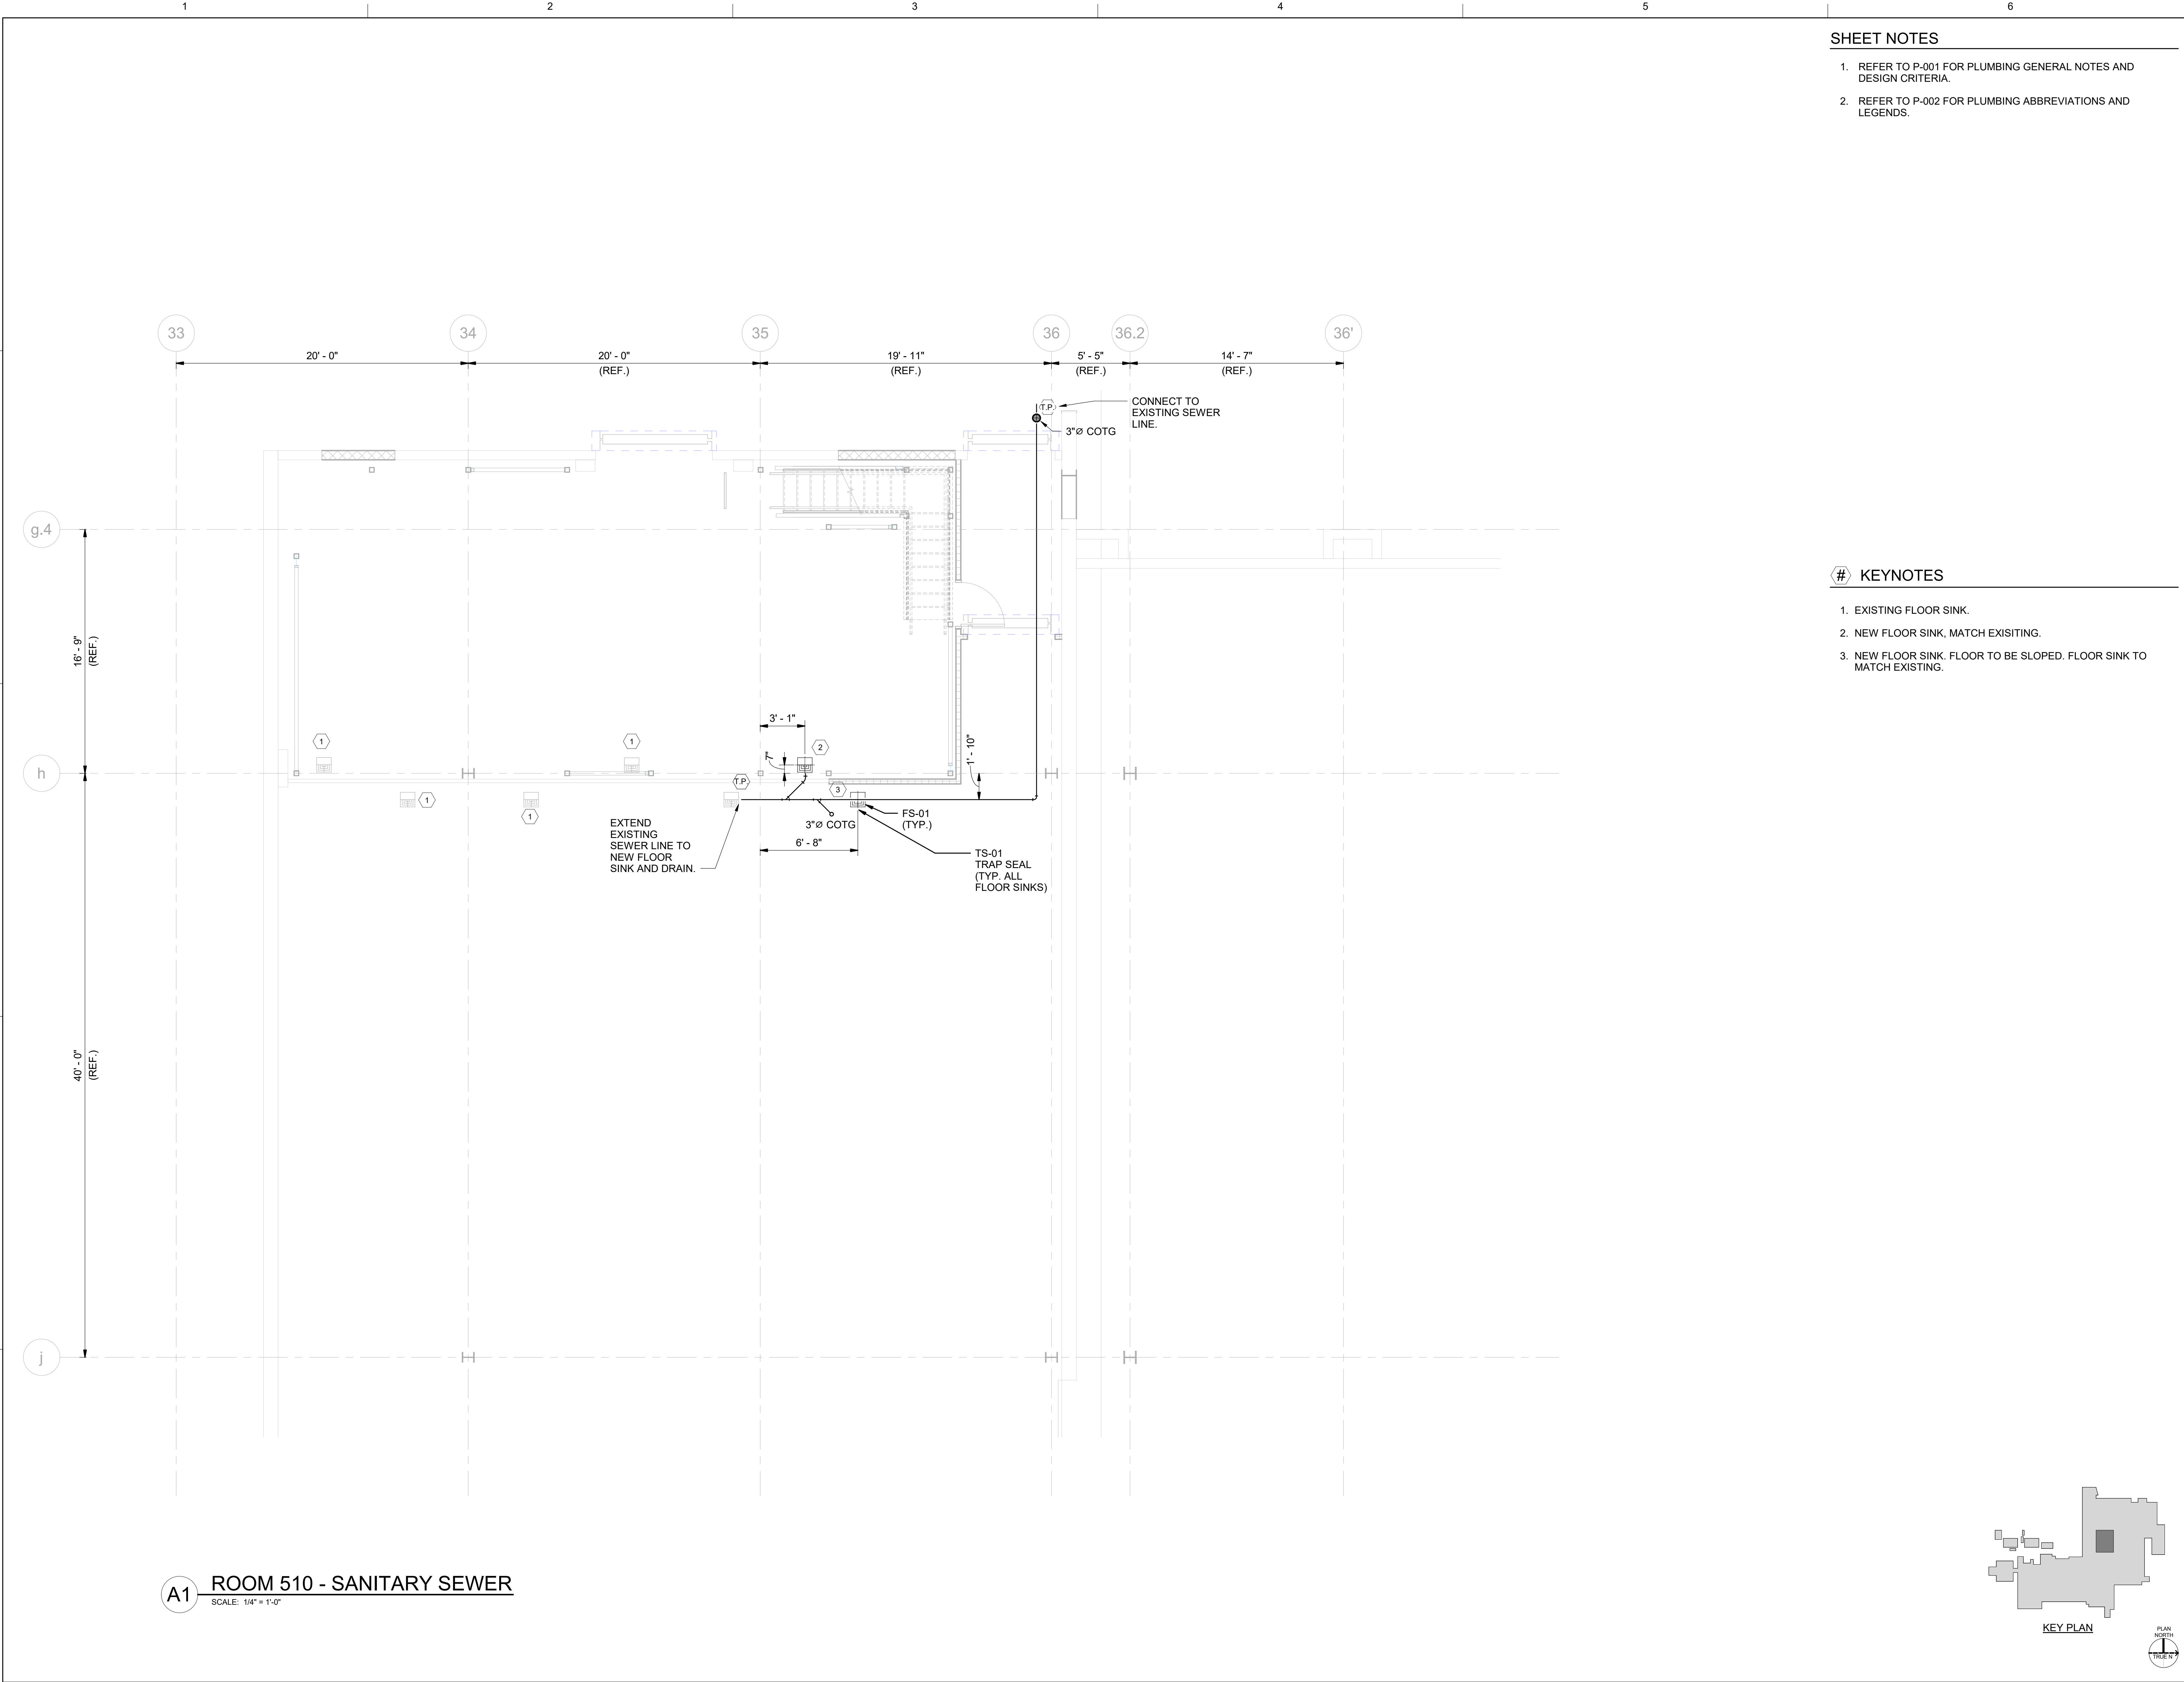

A1 ROOM 510 - SANITARY SEWER
SCALE: 1/4" = 1'-0"

SHEET NOTES

1. REFER TO P-001 FOR PLUMBING GENERAL NOTES AND DESIGN CRITERIA.
2. REFER TO P-002 FOR PLUMBING ABBREVIATIONS AND LEGENDS.

KEYNOTES

1. EXISTING FLOOR SINK.
2. NEW FLOOR SINK, MATCH EXSISTING.
3. NEW FLOOR SINK. FLOOR TO BE SLOPED. FLOOR SINK TO MATCH EXISTING.

POND
3500 Parkway Lane
Suite 500
Peachtree Corners
Georgia 30092
Copyright © 2024 by Pond & Company. All rights reserved. No copying or duplication of these documents is allowed without the expressed written agreement of Pond & Company.

EOR/AOR SEAL

COA SEAL

CLIENT INFORMATION



PROJECT NAME

**VANTIVE
TUBING
CLEAN ROOM**

1900 AR-201
MOUNTAIN HOME,
ARKANSAS 72653

DRAWING ISSUE

ISSUED FOR BID, EQ BID, ISSUED FOR APPROVAL	DESCRIPTION
04/24/2026	01/23/2026
DATE	DATE
B	A
MARK	MARK

DESIGNED BY: JC
DRAWN BY: JS
CHECKED BY: JC
SUBMITTED BY: CL
DATE: 04/24/2026
PROJECT #: 1241011


SHEET TITLE

**ROOM 510 -
PLUMBING PLAN**

SHEET NUMBER

P-100

ORIGINAL SHEET SIZE:
30" X 42"

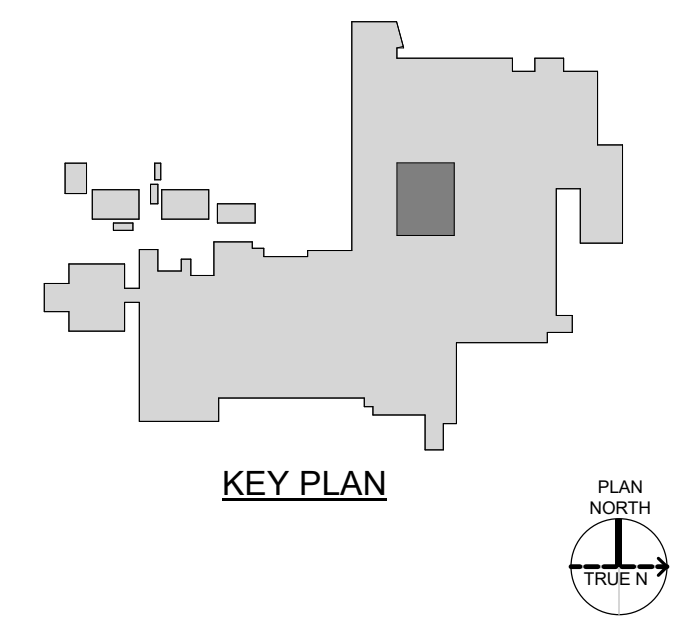

ISSUED FOR BID