
C:\Users

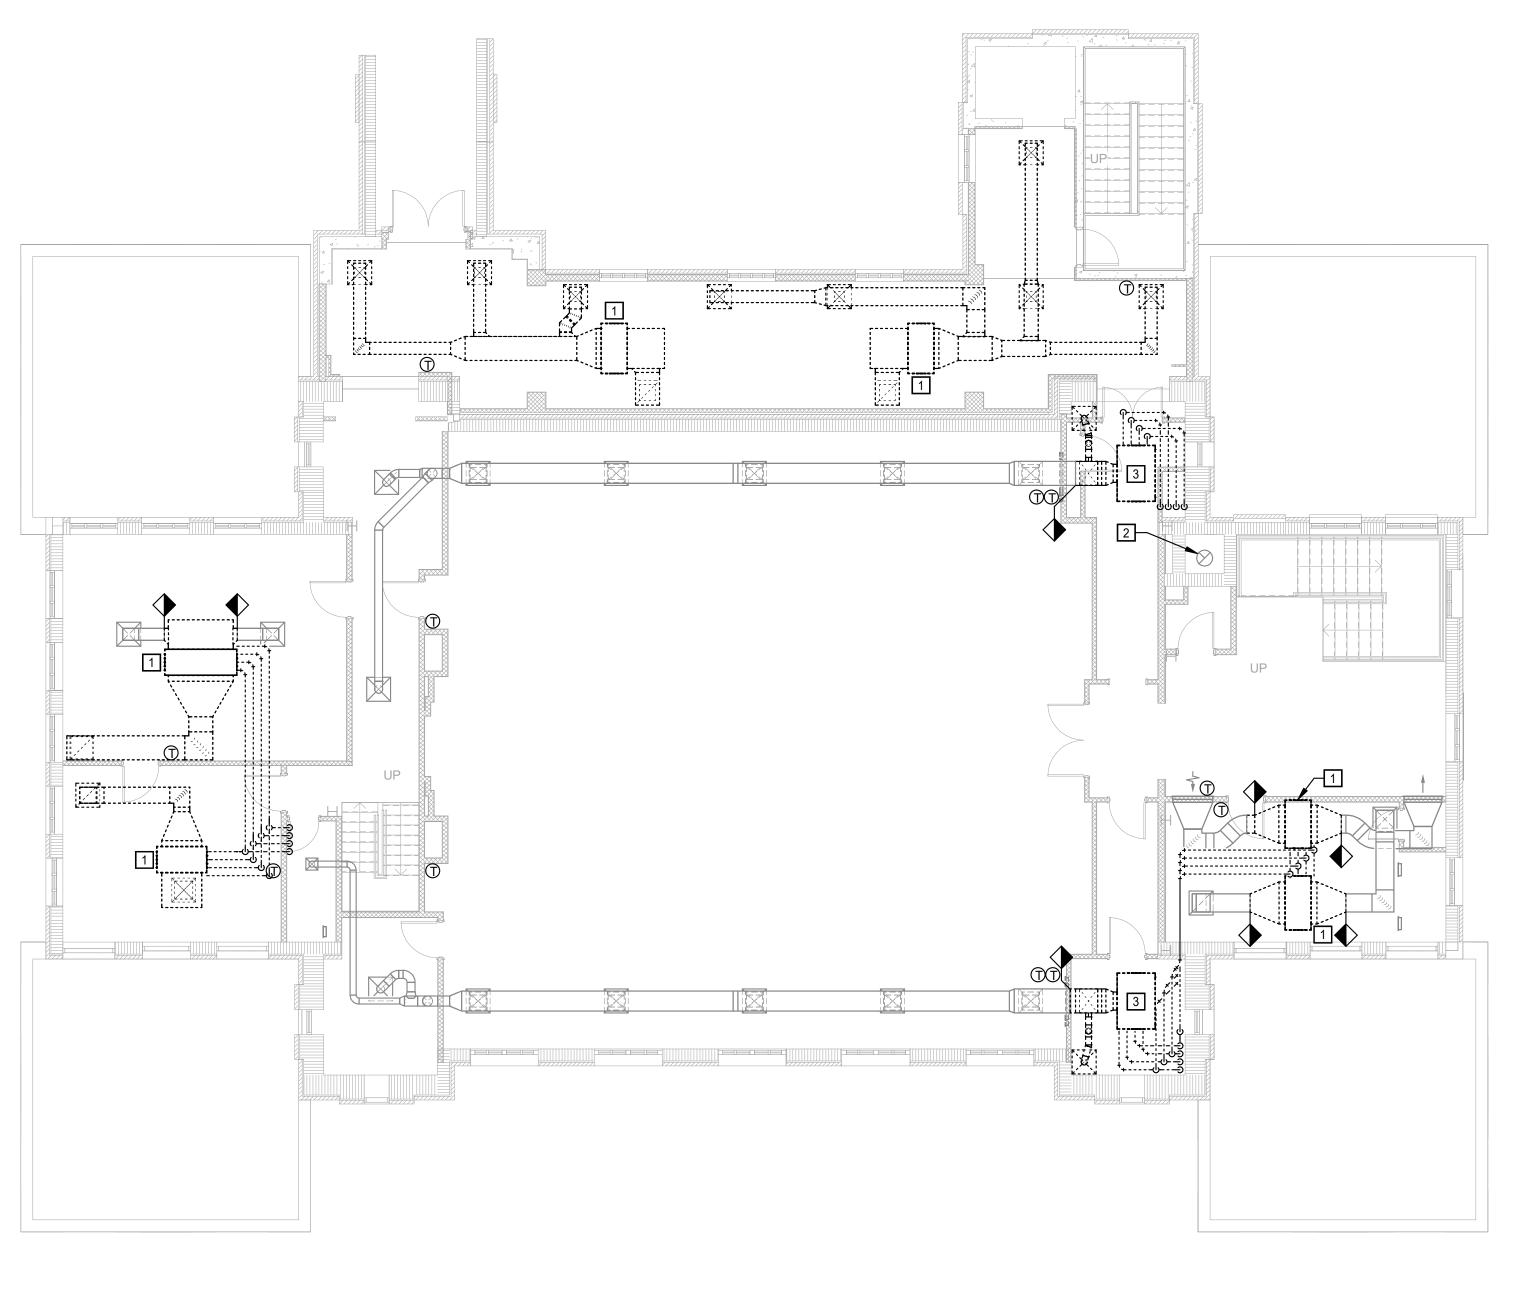

THIRD FLOOR DEMOLITION PLAN - HVAC SCALE: 1/8" = 1'-0"

HVAC GENERAL DEMOLITION NOTES


- 1. ALL LIGHTER SOLID LINES REPRESENT PIPING, DUCTWORK, EQUIPMENT, ETC. TO REMAIN.
- ALL DARKER DASHED LINES REPRESENT PIPING, DUCTWORK, EQUIPMENT, ETC. TO 2. BE REMOVED.
- FIELD VERIFY EXACT SIZE AND LOCATION OF ALL EXISTING ITEMS SHOWN ON THIS PLAN THAT ARE TO BE CONNECTED TO. 3.
- SEE ARCHITECTURAL PLANS FOR REMOVAL AND REPLACEMENT OF CEILINGS. 4.

HVAC KEYED DEMOLITION NOTES

- 1 DEMOLISH EXISTING FAN COIL UNIT AND ITS ASSOCIATED DUCTWORK, AIR DEVICES, PIPING, CONTROLS, ETC. COMPLETELY TO POINT INDICATED. DEMOLISH EXISTING CONDENSATE DRAIN PIPING THAT IS ROUTED TO SANITARY SEWER DRAIN, DO NOT DEMOLISH SECTIONS THAT ARE SERVING PLUMBING FIXTURES. DEMOLITION PHASING MAY BE REQUIRED TO FULLY ACCOMPLISH PROJECT REQUIREMENTS.
- 2 EXISTING BOILER FLUE TO BE CAPPED AND ABANDONED.
- 3 DEMOLISH EXISTING BLOWER COIL UNIT (LOCATED HIGH ABOVE CEILING) AND ITS ASSOCIATED DUCTWORK, AIR DEVICES, PIPING, CONTROLS, ETC. COMPLETELY TO POINT INDICATED. DEMOLISH EXISTING CONDENSATE DRAIN PIPING THAT IS ROUTED TO SANITARY SEWER DRAIN, DO NOT DEMOLISH SECTIONS THAT ARE SERVING PLUMBING FIXTURES. DEMOLITION PHASING MAY BE REQUIRED TO FULLY ACCOMPLISH PROJECT REQUIREMENTS.



m

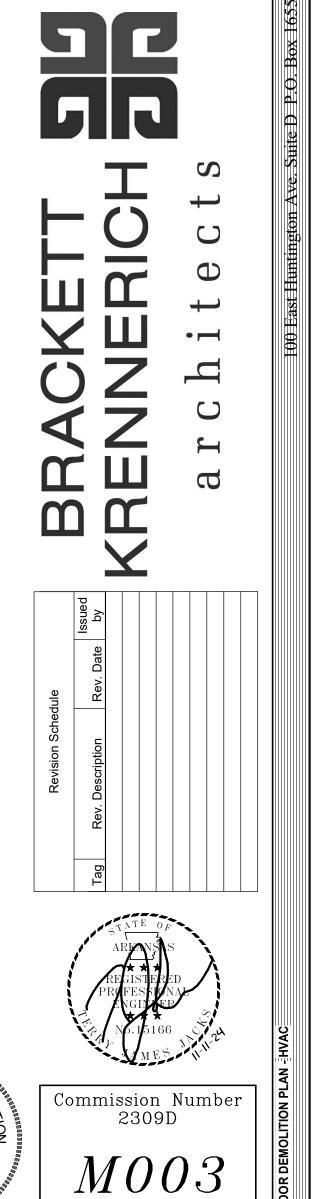

Date: November 11, 2024

티폰

