


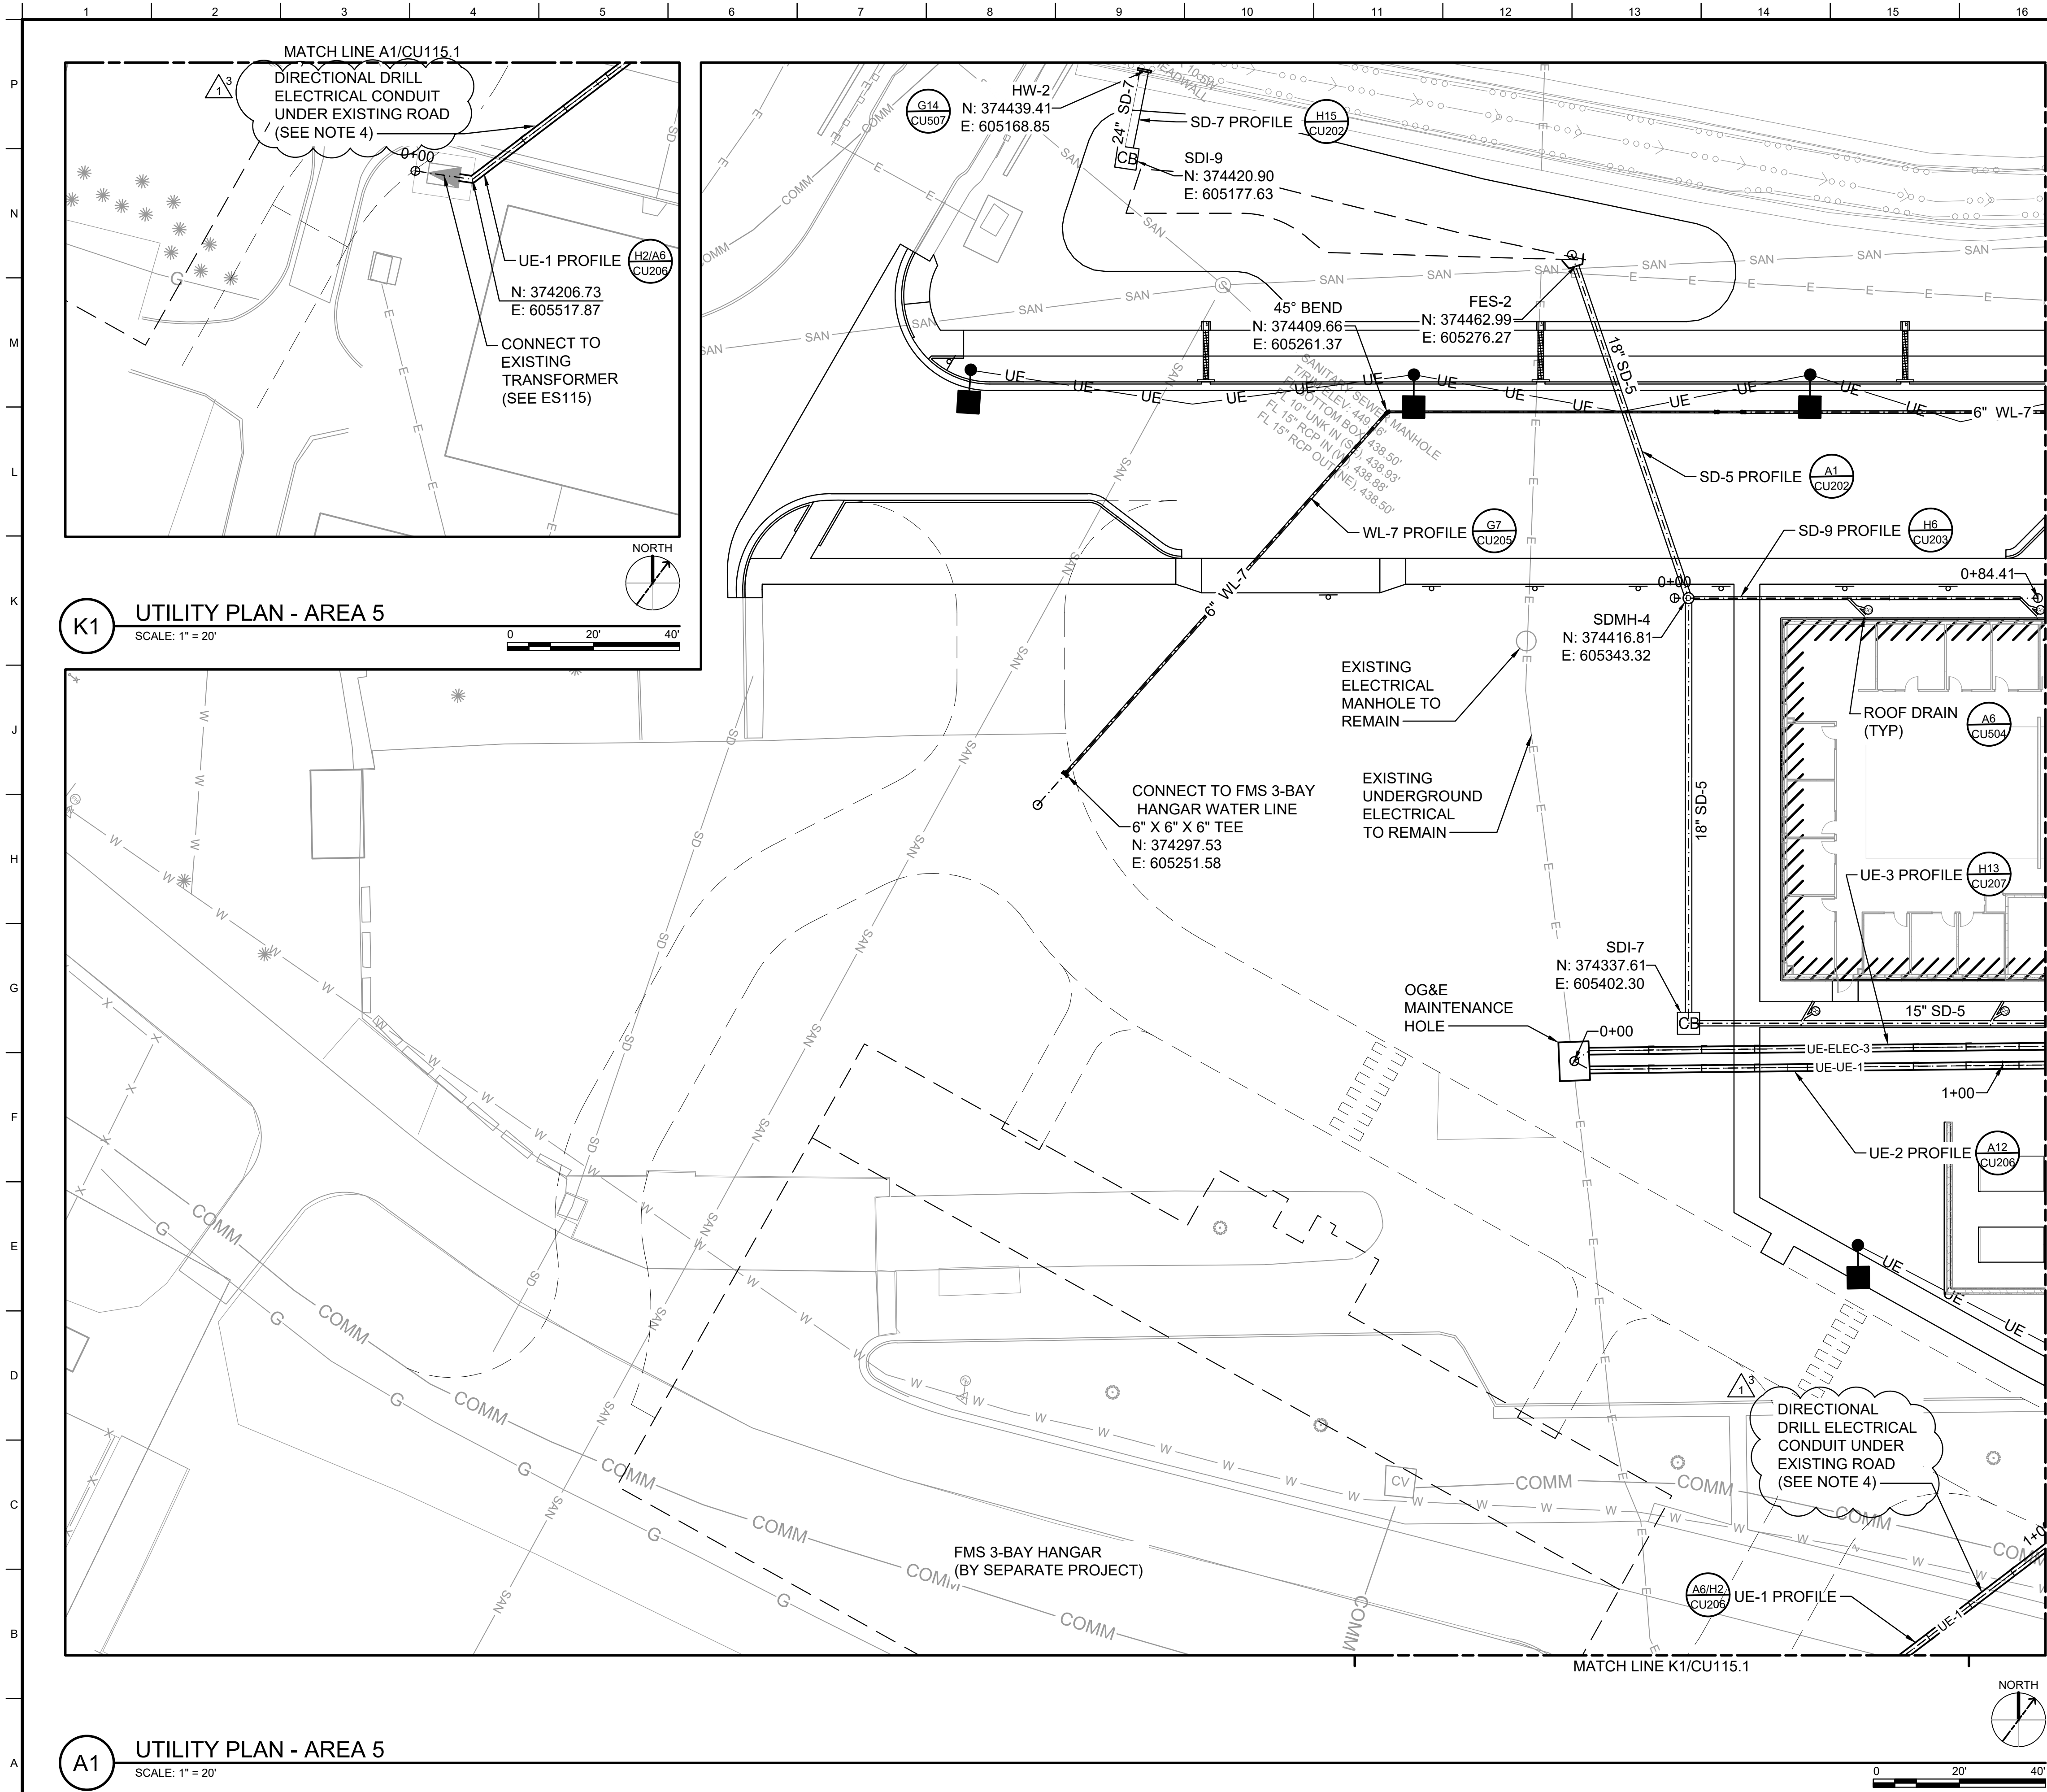

GENERAL SHEET NOTES

- SEE UTILITY NOTES ON C-002, SEE NORTHING AND EASTING POINT TABLE ON CU601.
- SEE MECHANICAL DRAWINGS FOR CONTINUATION OF UTILITY LINES AT THE BUILDING CONNECTIONS.
- SEE ELECTRICAL DRAWINGS FOR ELECTRICAL AND COMMUNICATIONS WORK.
- DIRECTIONAL DRILL ELECTRICAL CONDUIT UNDER EXISTING ROAD IN ACCORDANCE WITH SPECIFICATIONS SECTION 33 05 07.13.

LEGEND

WL-1	WATER
UE-1	UNDERGROUND ELECTRICAL - PRIMARY FEED
COM-1	COMMUNICATIONS
SS-1	SANITARY SEWER
D	UNDERDRAIN
SD-1	STORM DRAIN
⊙	FIRE HYDRANT
⋈	VALVE
⊙	CLEANOUT
⊙	SANITARY SEWER MANHOLE
⊙	COMMUNICATIONS MANHOLE
⬇	TRANSFORMER
CB	CATCH BASIN
⌒	FLARED END SECTION
■	LIGHT POLE
W	EXISTING WATER
---E---	EXISTING UNDERGROUND ELECTRICAL - PRIMARY FEED
---G---	EXISTING COMMUNICATIONS
---ES---	EXISTING UNDERGROUND ELECTRICAL - SECONDARY FEED
SAN	EXISTING SANITARY SEWER
SD	EXISTING STORM DRAIN
⊙	STORM DRAIN MANHOLE

KEY PLAN

DESIGNED BY: R. DONNELLY
DRAWN BY: W. J. DONNELLY
CHECKED BY: R. BARUTH
SUBMITTED BY: B. STREIBIN
FILE NAME: 16543620111-16.dwg
ANSI D

ISSUE DATE: JUL 2025
#1012524F007
CONTRACT NO.: W912524F007

US ARMY CORPS OF ENGINEERS
LITTLE ROCK DISTRICT
LITTLE ROCK, ARKANSAS

BURNS AND McDONNELL
9400 WARD PARKWAY
KANSAS CITY, MO. 64114
165436

STATE OF ARKANSAS
LICENSED PROFESSIONAL ENGINEER
No. 22394
W. J. DONNELLY
1/5/2026

US Army Corps of Engineers ®

DATE	DESCRIPTION	MARK
JAN 2026	AM002 - REMOVED CATHODIC PROTECTION READY-TO-ADVERTISE (RTA) SUBMITTAL	1
JUL 2025		0

DESIGNED BY: R. DONNELLY
DRAWN BY: W. J. DONNELLY
CHECKED BY: R. BARUTH
SUBMITTED BY: B. STREIBIN
FILE NAME: 16543620111-16.dwg
ANSI D

ISSUE DATE: JUL 2025
#1012524F007
CONTRACT NO.: W912524F007

US ARMY CORPS OF ENGINEERS
LITTLE ROCK DISTRICT
LITTLE ROCK, ARKANSAS

BURNS AND McDONNELL
9400 WARD PARKWAY
KANSAS CITY, MO. 64114
165436

F-35: SPECIAL ACCESS PROGRAM FACILITY
EBBING AIR NATIONAL GUARD BASE (ANGB), FORT SMITH, ARKANSAS

UTILITY PLAN - AREA 5

SHEET ID

CU115.1

READY-TO-ADVERTISE (RTA) SUBMITTAL