

Northwest Arkansas Sheet Metal, Inc.

PO Box 1660 – 136 Kelley Drive

Rogers, AR 72757

Phone: (479) 636-4500 Fax: (479) 631-0037

VA Logistics B-1

Architect: Harrell


Mechanical Engineer: Harrell

Mechanical Contractor: CSUSA


Submitted for:

Division 01 33 23 1.2K


Section 23 – HVAC Duct As-Built Drawings

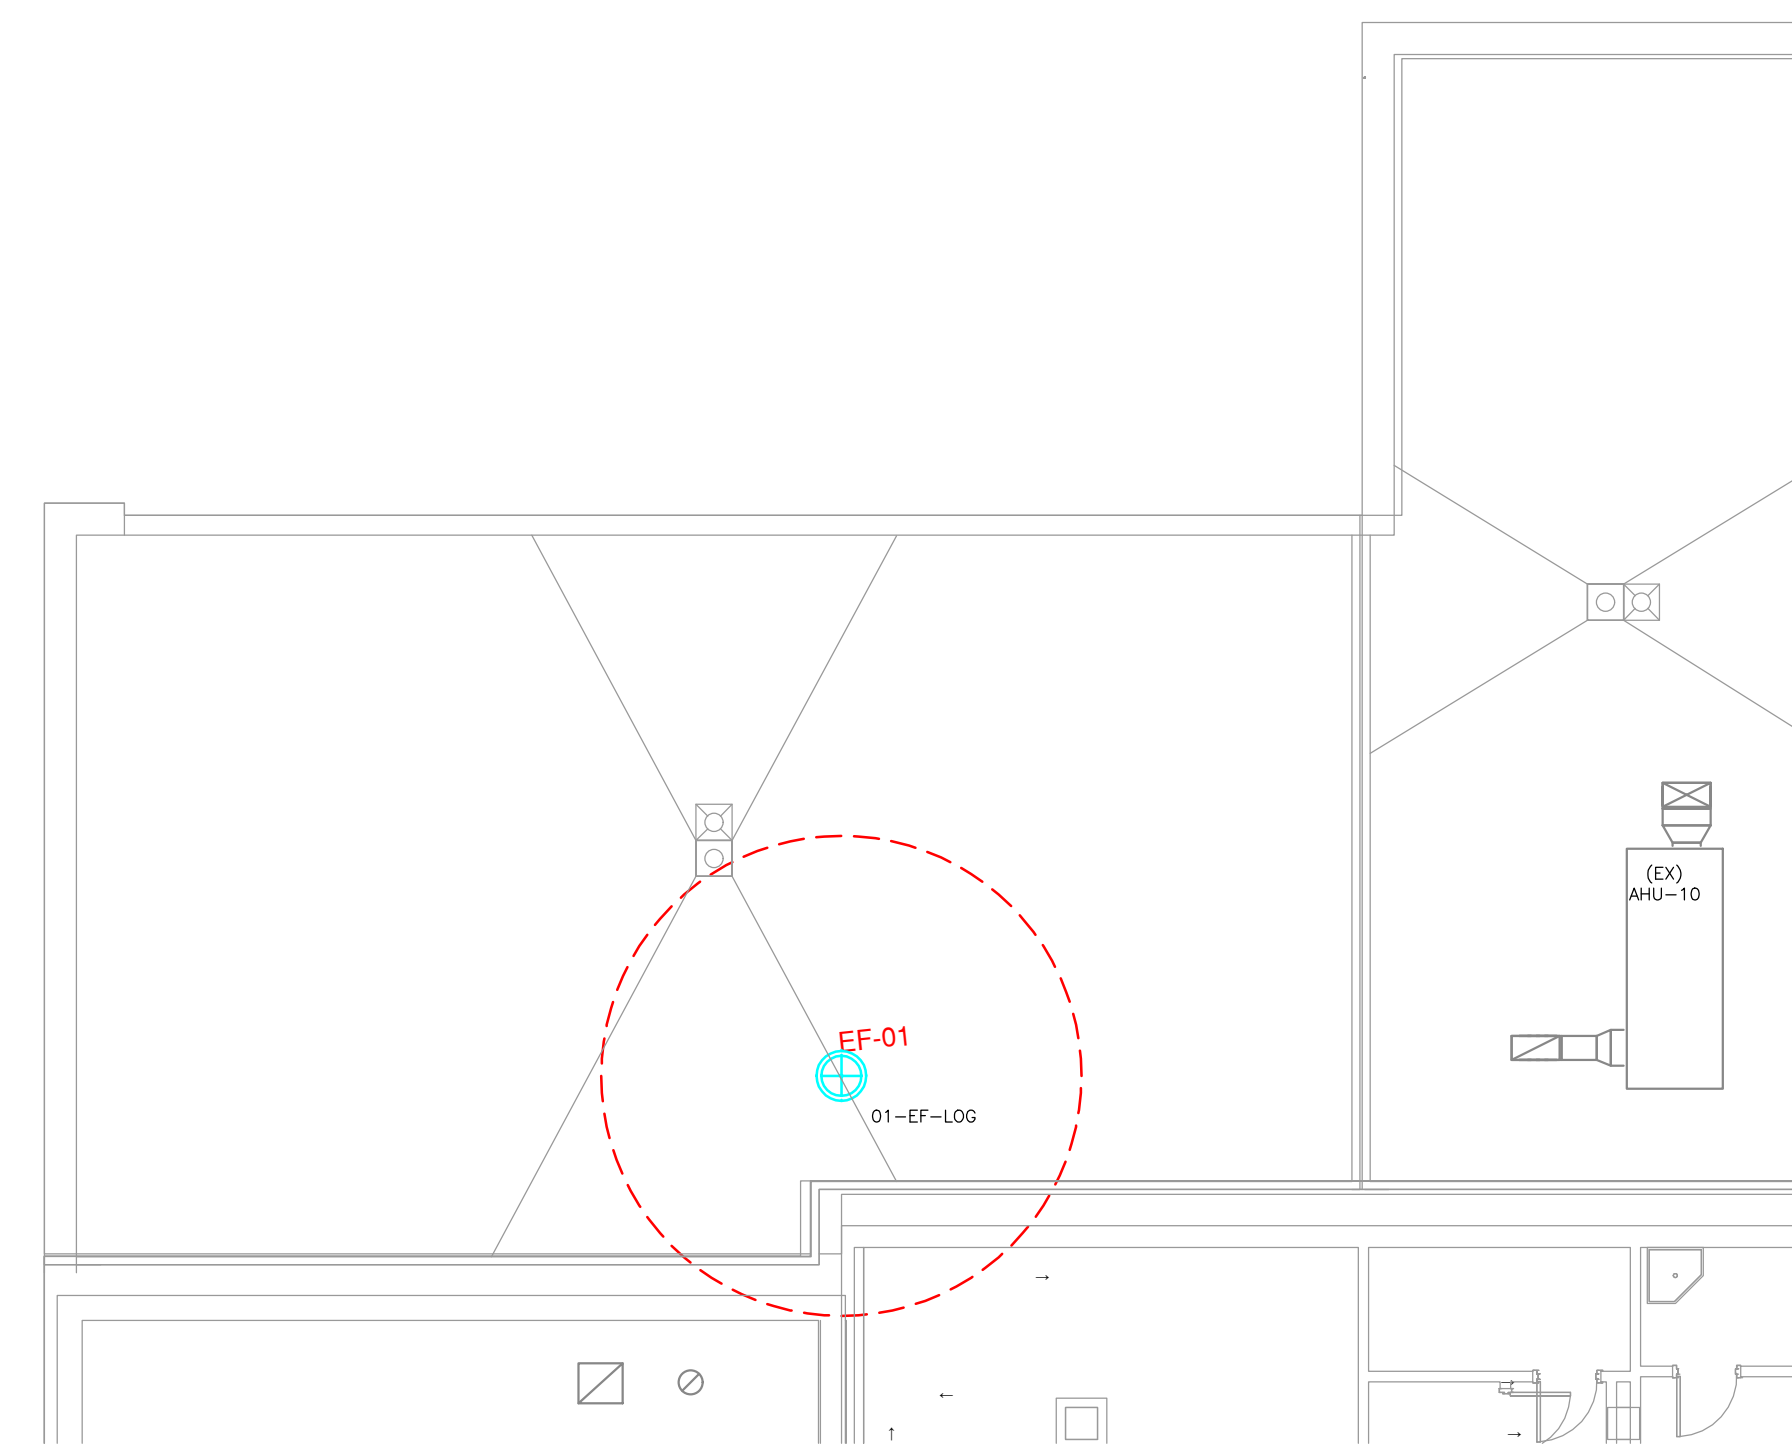


LOADING DUCT ROOF DUCTWORK PLAN
SCALE: 1/8" = 1'-0"

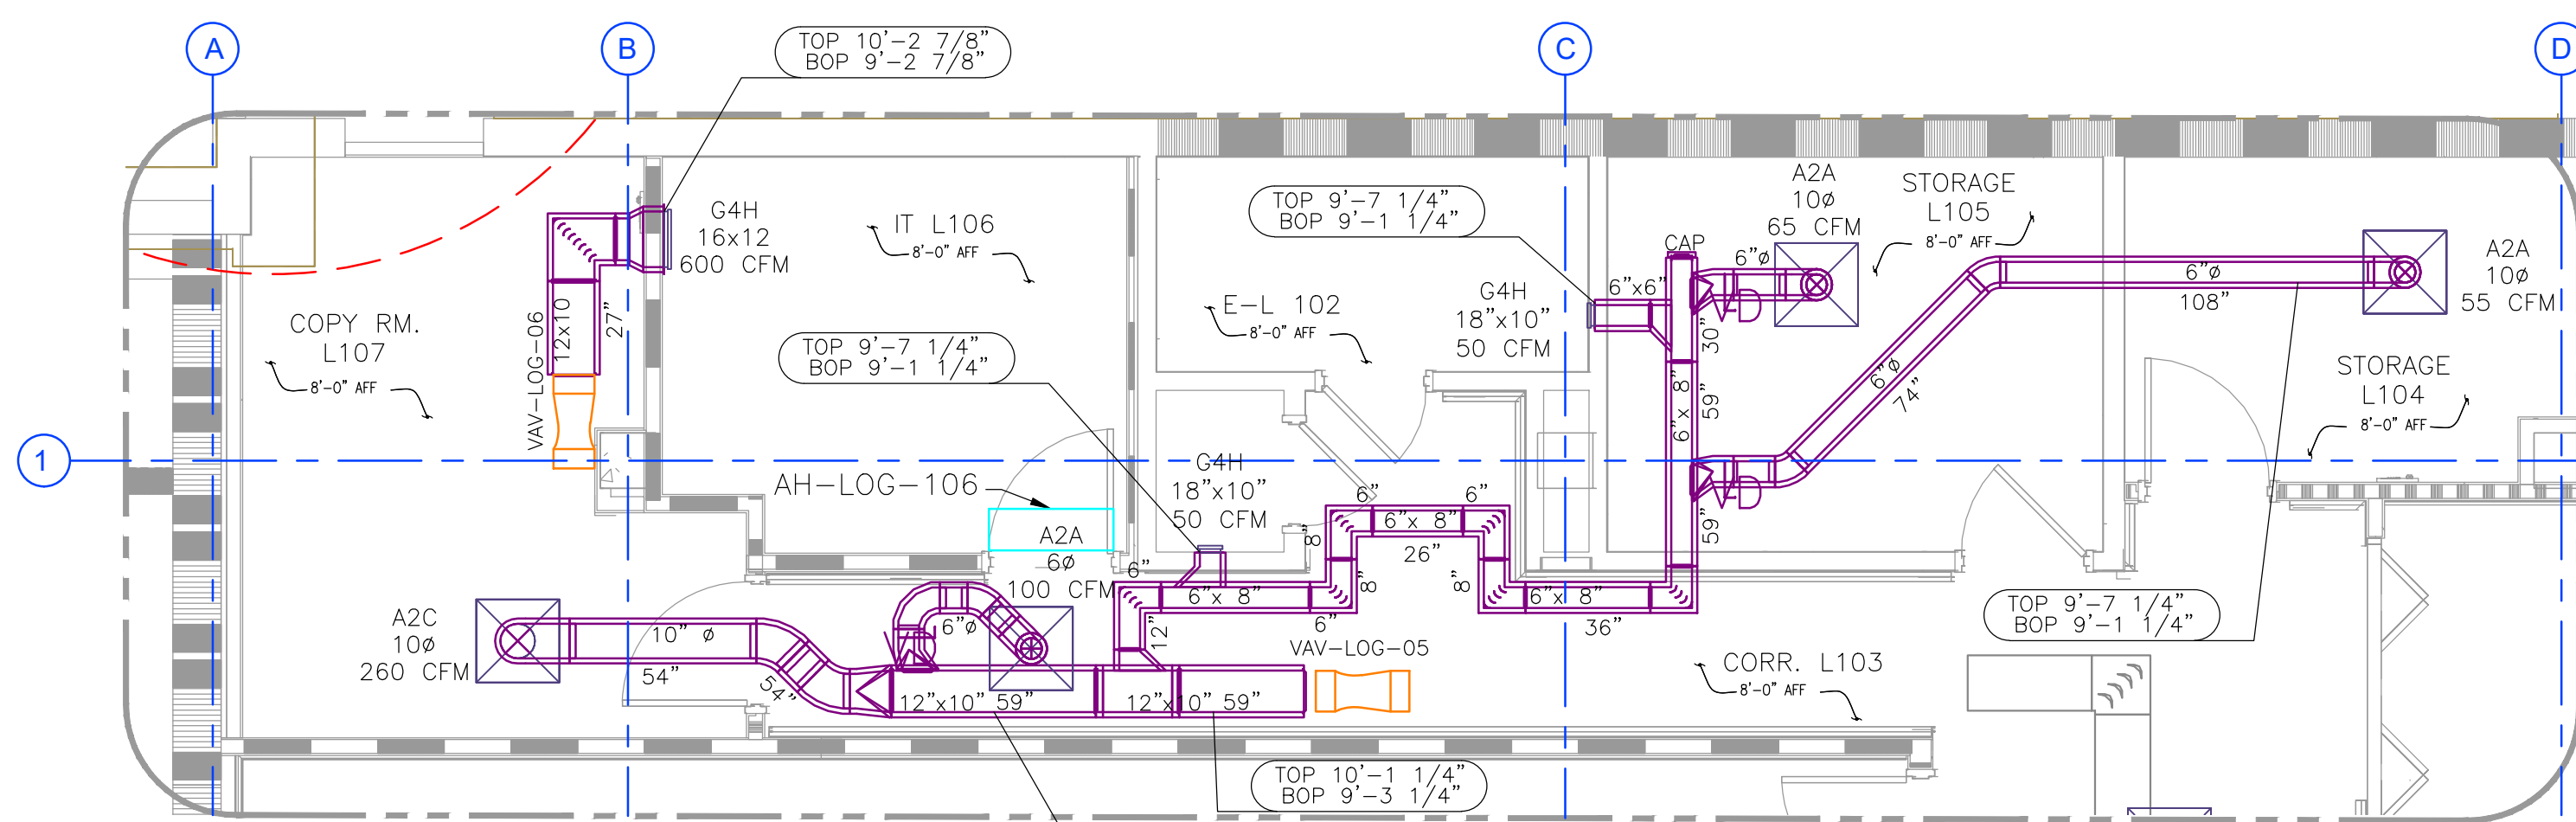


A LOW PSI SUPPLY DUCT
MH.101A SCALE: 1/4" = 1'-0"

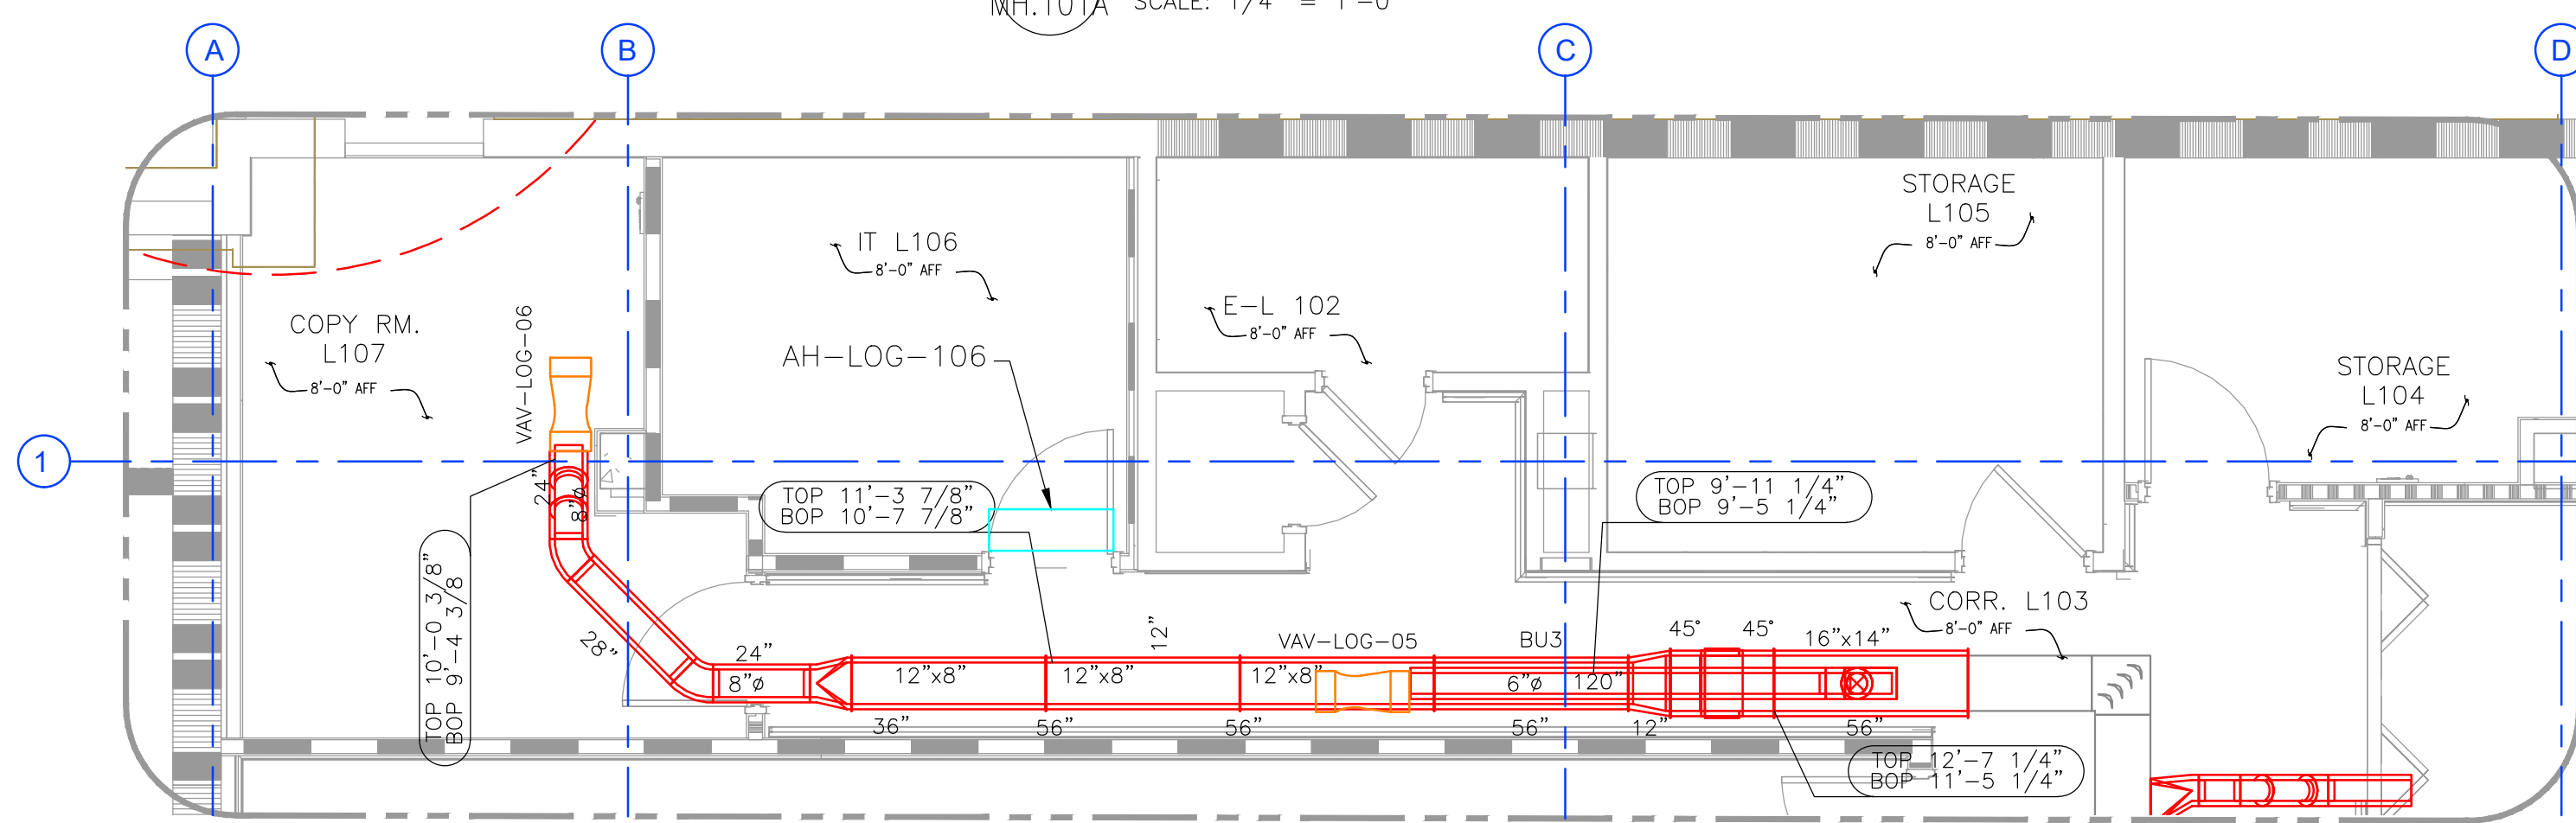


B LOW PSI SUPPLY DUCT
MH.101A SCALE: 1/4" = 1'-0"

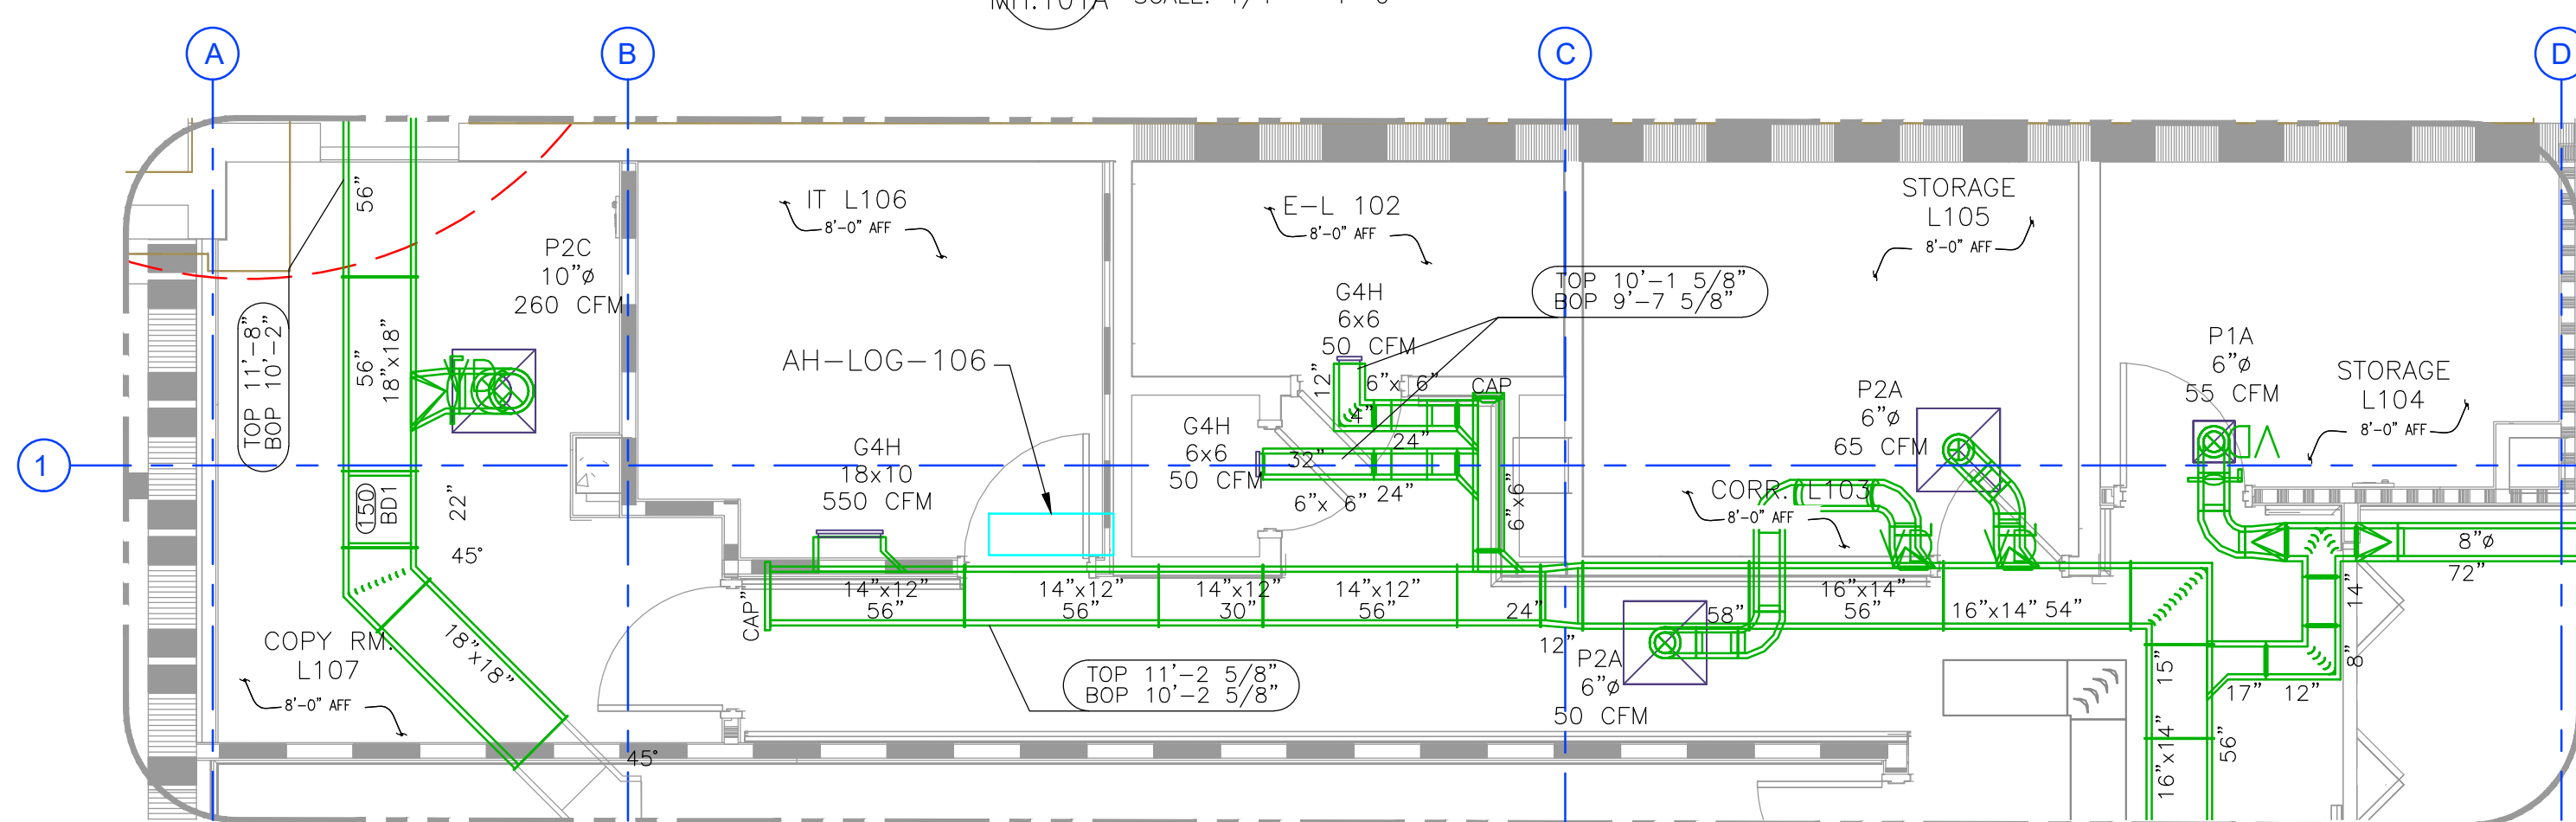

C LOW PSI SUPPLY DUCT
MH.101A SCALE: 1/4" = 1'-0"

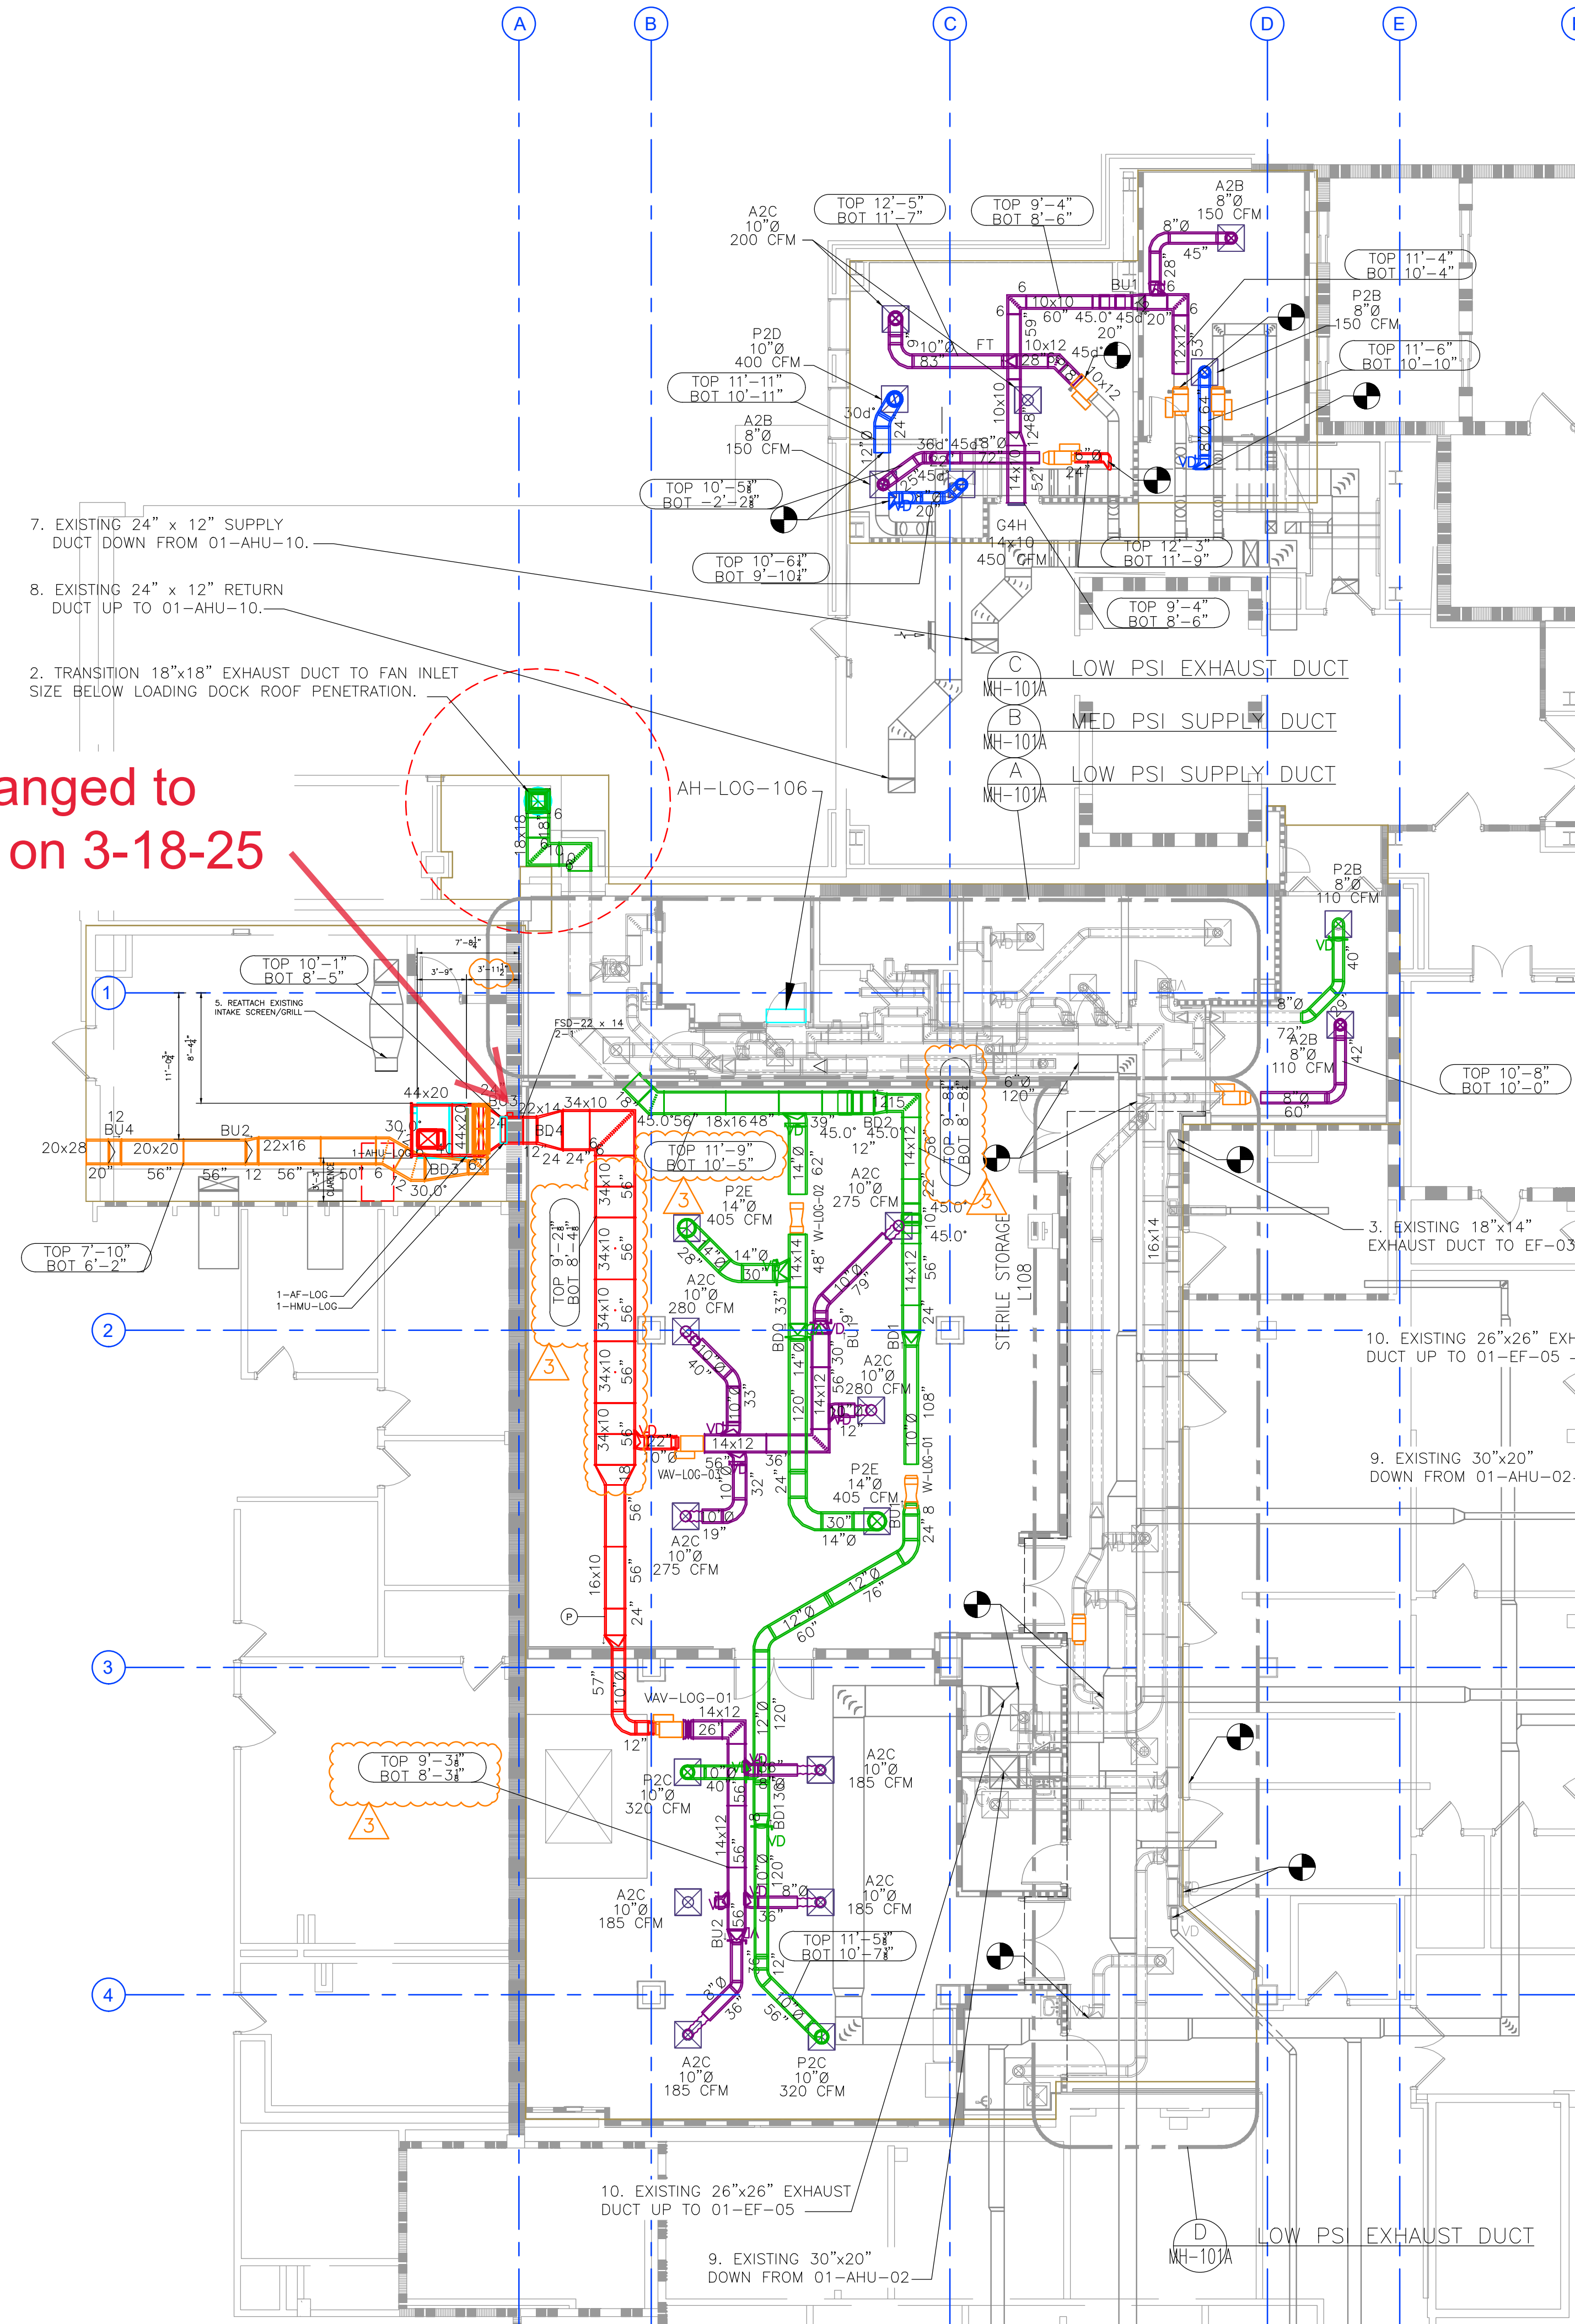

FIRST FLOOR DUCTWORK PLAN
SCALE: 1/8" = 1'-0"

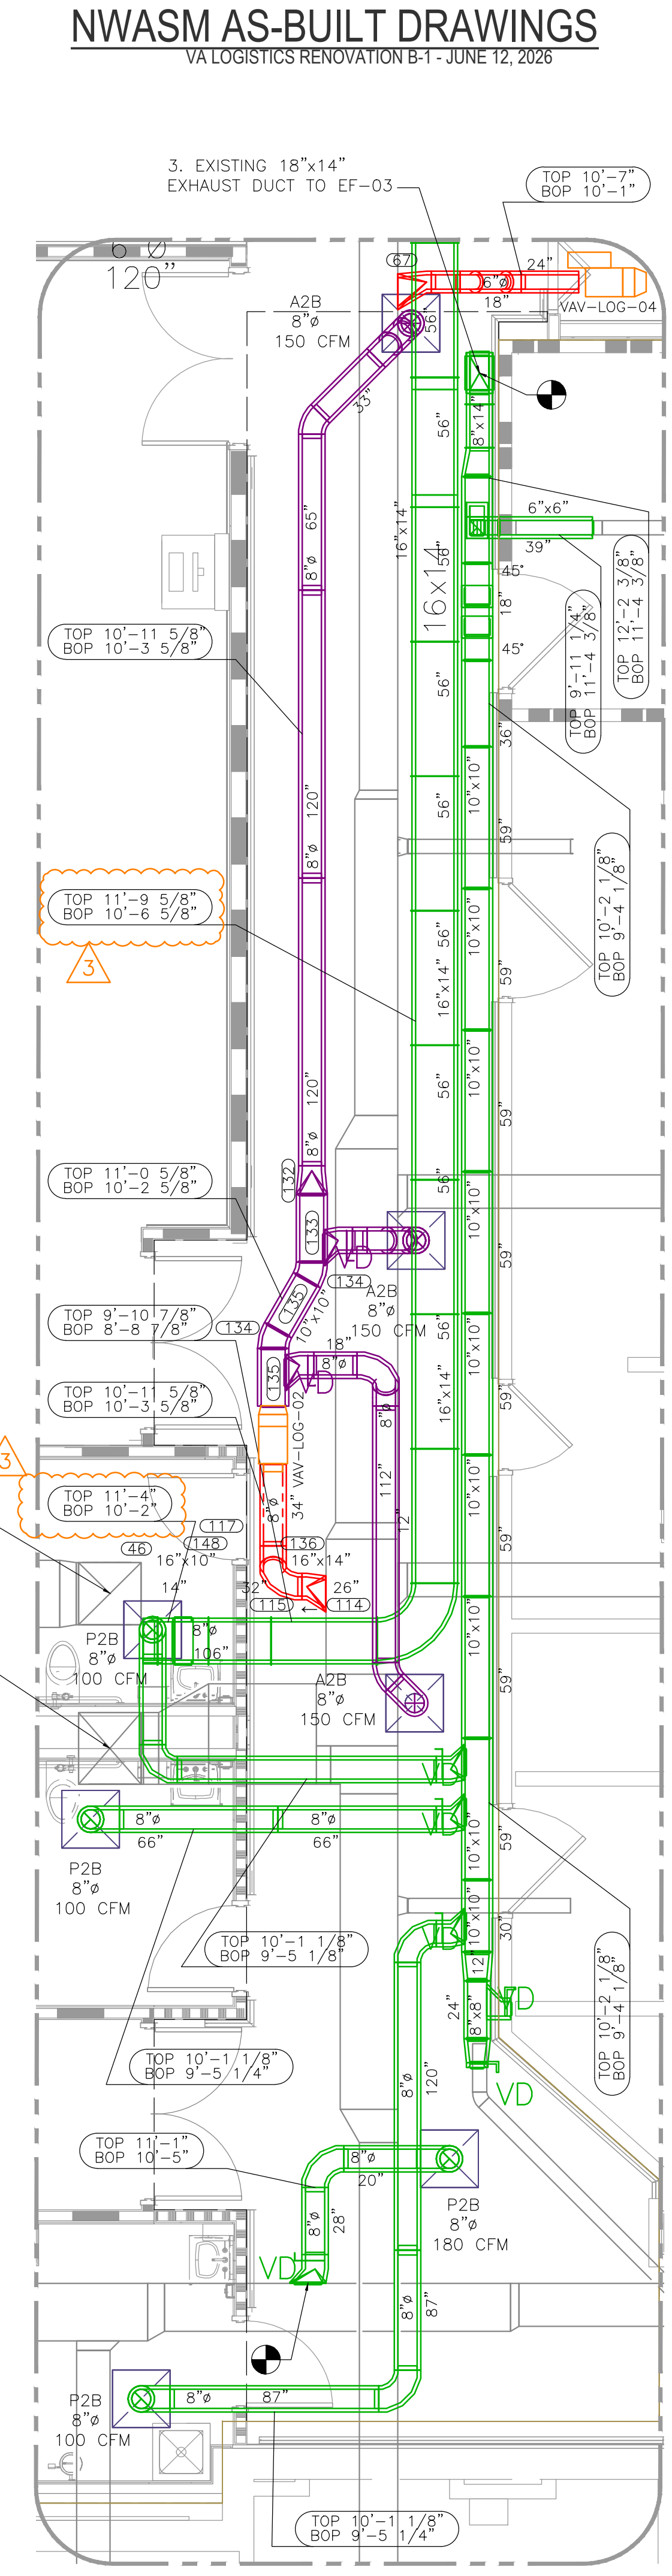

D LOW PSI EXHAUST DUCT
MH.101A SCALE: 1/4" = 1'-0"

FD changed to
28x10 on 3-18-25

